



Village of Hinsdale
19 E. Chicago Avenue
Hinsdale, IL 60521-3489
(630)789-7000
Village Website: www.villageofhinsdale.org

PUBLIC SERVICES UTILITY PERMIT APPLICATION - Permit Fee of \$100.00

Date of Application: 2/17/2022 Permit No: ComEd - 0047 Permit Expiration Date: ~~03/31/2022~~ 06/30/22 ADP

Utility Company Information:

Company Name: Commonwealth Edison (ComEd)
Address: 1 Lincoln Center
City, State, Zip: Oakbrook Terrace, IL, 60181
Contact Person: John Cassidy
Phone Number: 630-437-2140
Email Address: john.cassidy@comed.com
Cell Number: 630-437-2140
Project/Work Order Number: 16547542-6P220601

Contractor Information:

Company Name: ComEd
Address: _____
City, State, Zip: _____
Contact Person: _____
Phone Number: _____
Email Address: _____
Cell Number: _____

PROJECT LOCATION: 541 E 7th St; 330 S County Line Rd

Description of work covered under this permit: _____

Location 6 (466073-040) Pole Replacement w/ 45'/2 pole approx. 1' to the east of existing pole location & aligned with existing pole line.

Location 7 (465122-245) Pole Replacement w/ 45'/H1 pole approx. 1' to the north of existing pole location & aligned with existing pole line.

Start Date: ~~2/2/2022~~ 3/14/22 ADP Completion Date: ~~2/25/2022~~ 4/20/22

Site Plan/Details/Specifications (3 sets) included with application?

☒ YES

☐ NO

Currently registered as a Utility Contractor with the Village of Hinsdale?

☒ YES

☐ NO

Engineer Estimate of Cost included with application?

☐ YES

☒ NO

Type of Utility: ☒ ComEd ☐ Nicor ☐ Comcast ☐ Water ☐ Sewer
☐ Communications: ☐ Fiber Optic ☐ Wireless ☐ Other: _____

Applicant Information:

Print Name: Mark Febonio OBO ComEd Phone Number: 312-995-0230

Company: HBK Engineering Email Address: mfebONIO@hbKengineering.com

Signature: HBK - Mark Febonio Digitally signed by HBK - Mark Febonio
Date: 2021.07.29 15:02:03 -0500 Date: 7/29/2021

ALL CONSTRUCTION SHALL BE DONE IN ACCORDANCE WITH THE LATEST EDITION IN EFFECT ON THE DATE OF PERMIT APPLICATION OF THE FOLLOWING: STANDARD SPECIFICATIONS FOR ROAD AND BRIDGE CONSTRUCTION & SUPPLEMENTAL SPECIFICATIONS AND RECURRING SPECIAL PROVISIONS BY THE ILLINOIS DEPARTMENT OF TRANSPORTATION, ILLINOIS MANUAL ON UNIFORM TRAFFIC CONTROL DEVICES FOR STREETS AND HIGHWAYS, STANDARD SPECIFICATIONS FOR WATER AND SEWER MAIN CONSTRUCTION IN ILLINOIS, AND THE VILLAGE OF HINSDALE SUBDIVISION ORDINANCES (Ord. 02007-73, 11-6-2007) AND ENGINEERING STANDARDS.

Village Use Only

Permit Approved: ☒ YES ☐ NO


Conditions for Approval/Reasons for Denial: RESTORE RAIN GARDEN TO MEET THE ATTACHED DESIGN STANDARDS. RESTORE ALL DISTURBED AREAS WITHIN 14 DAYS OF COMPLETION. NOTIFY LOCAL RESIDENTS 48 HOURS PRIOR TO START.

Approved By:  A. Diaz Date: 02-18-22


FEEDERS: W3603 12 KV (PAGE 4 OF 4)

REFER TO C7033 FOR NEW POLE INSTALLATION
LABEL ALL EQUIPMENT PER C7493
SOME EQUIPMENT HIDDEN FOR CLARITY
DRAWING NOT TO SCALE
CONTACT JULIE 48HRS PRIOR TO CONSTRUCTION AT (800) 892-0123
MOUNT CONTROL CABINET PER C7500
FOREIGN ATTACHMENT TRANSFER REQUIRED

Permit Type	Project Name	Office	Designer	Location - Reason for Work	Work Order #
MUNICIPALITY	0000292985	HBK ENGINEERING	M. HADACEK	541 E 7TH ST	16547542
Permit Number	SR #	JWA #	Phone #	FEJA VOLTAGE OPTIMIZATION - 6P220601 - W3603	Schedule Group
PENDING	05102942	N/A	312-253-1800		PMD
Joint Work Contact	SER/CWA #	Phone RO #	PD #	Town or Township	QS/Block
N/A	N/A	N/A	6P220601	HINSDALE	466073
Date Issued: 01/26/2022 - REV 2	Contingent WO #s		Completed By:	Date:	
			17140172		
0.0 48.1 96.1 FT	Page 8 of 10	Verified By:	Date:		

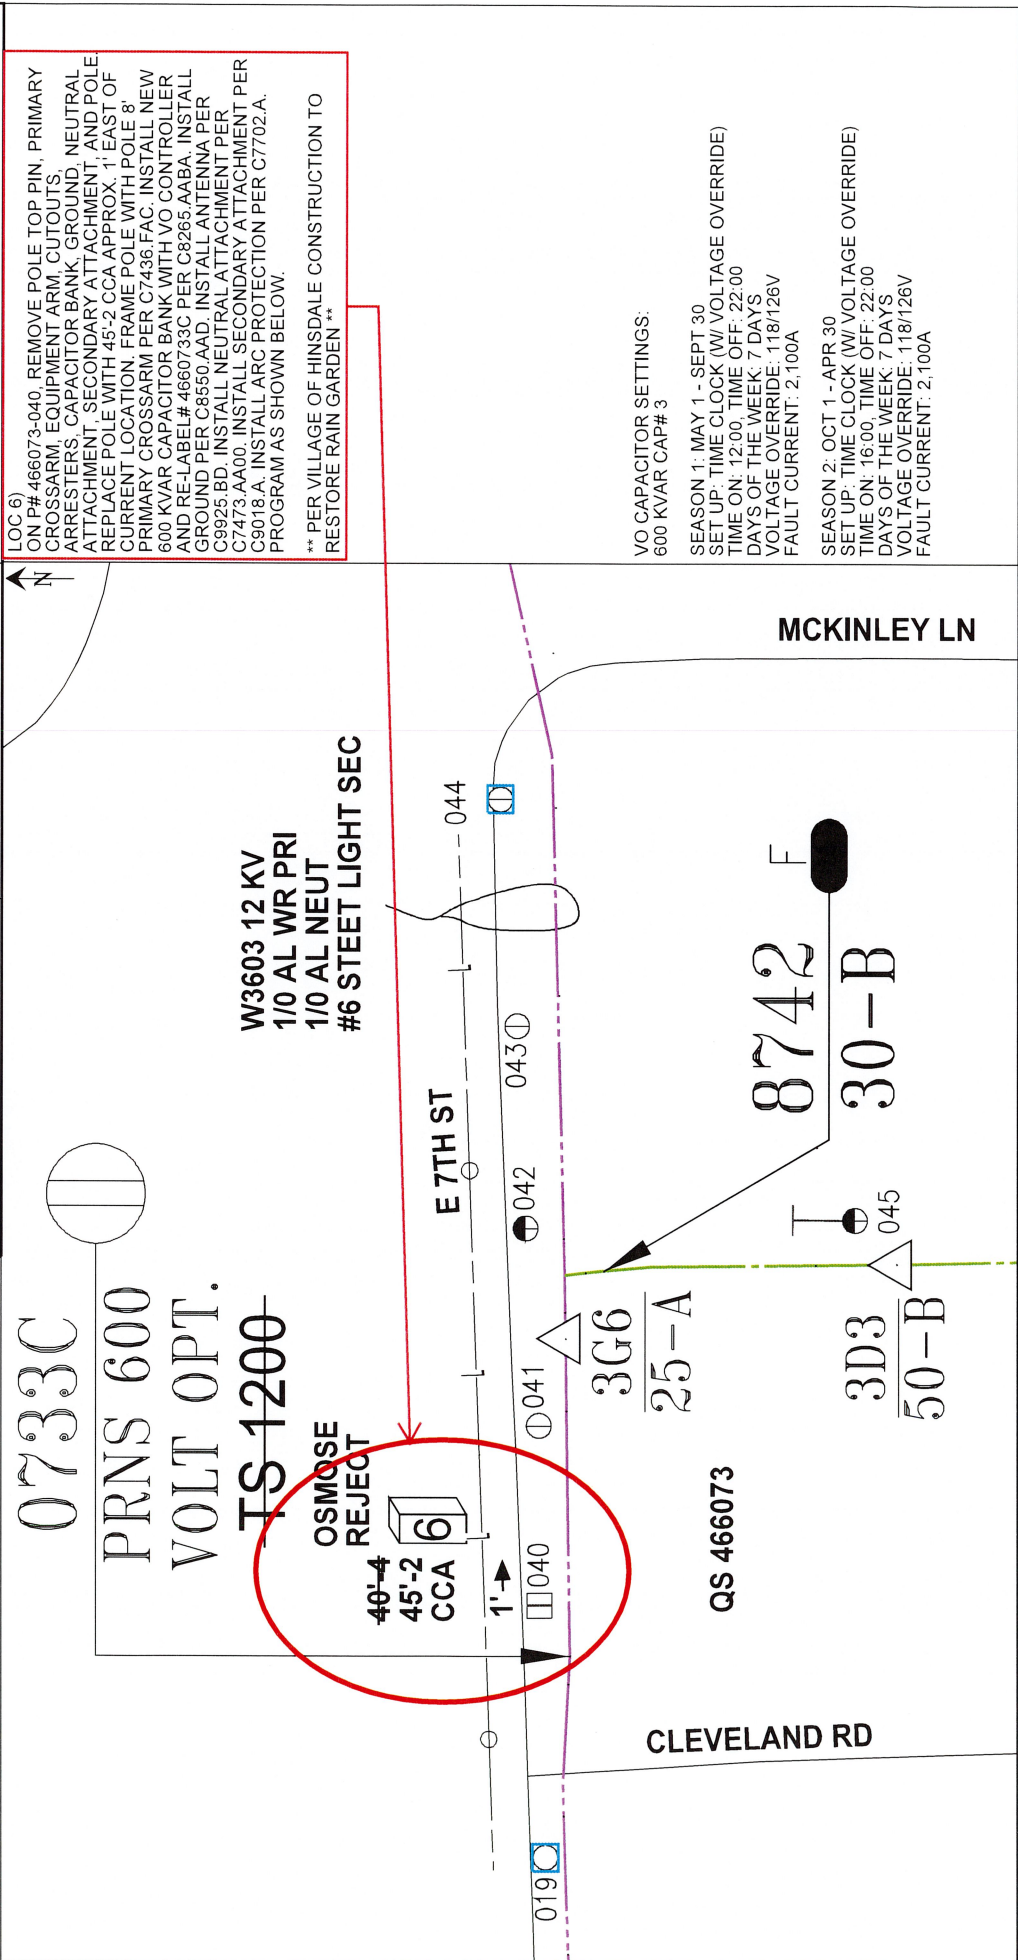

CONTACT JULIE 48HRS PRIOR TO CON:
MOUNT CONTROL CABINET PER C7500

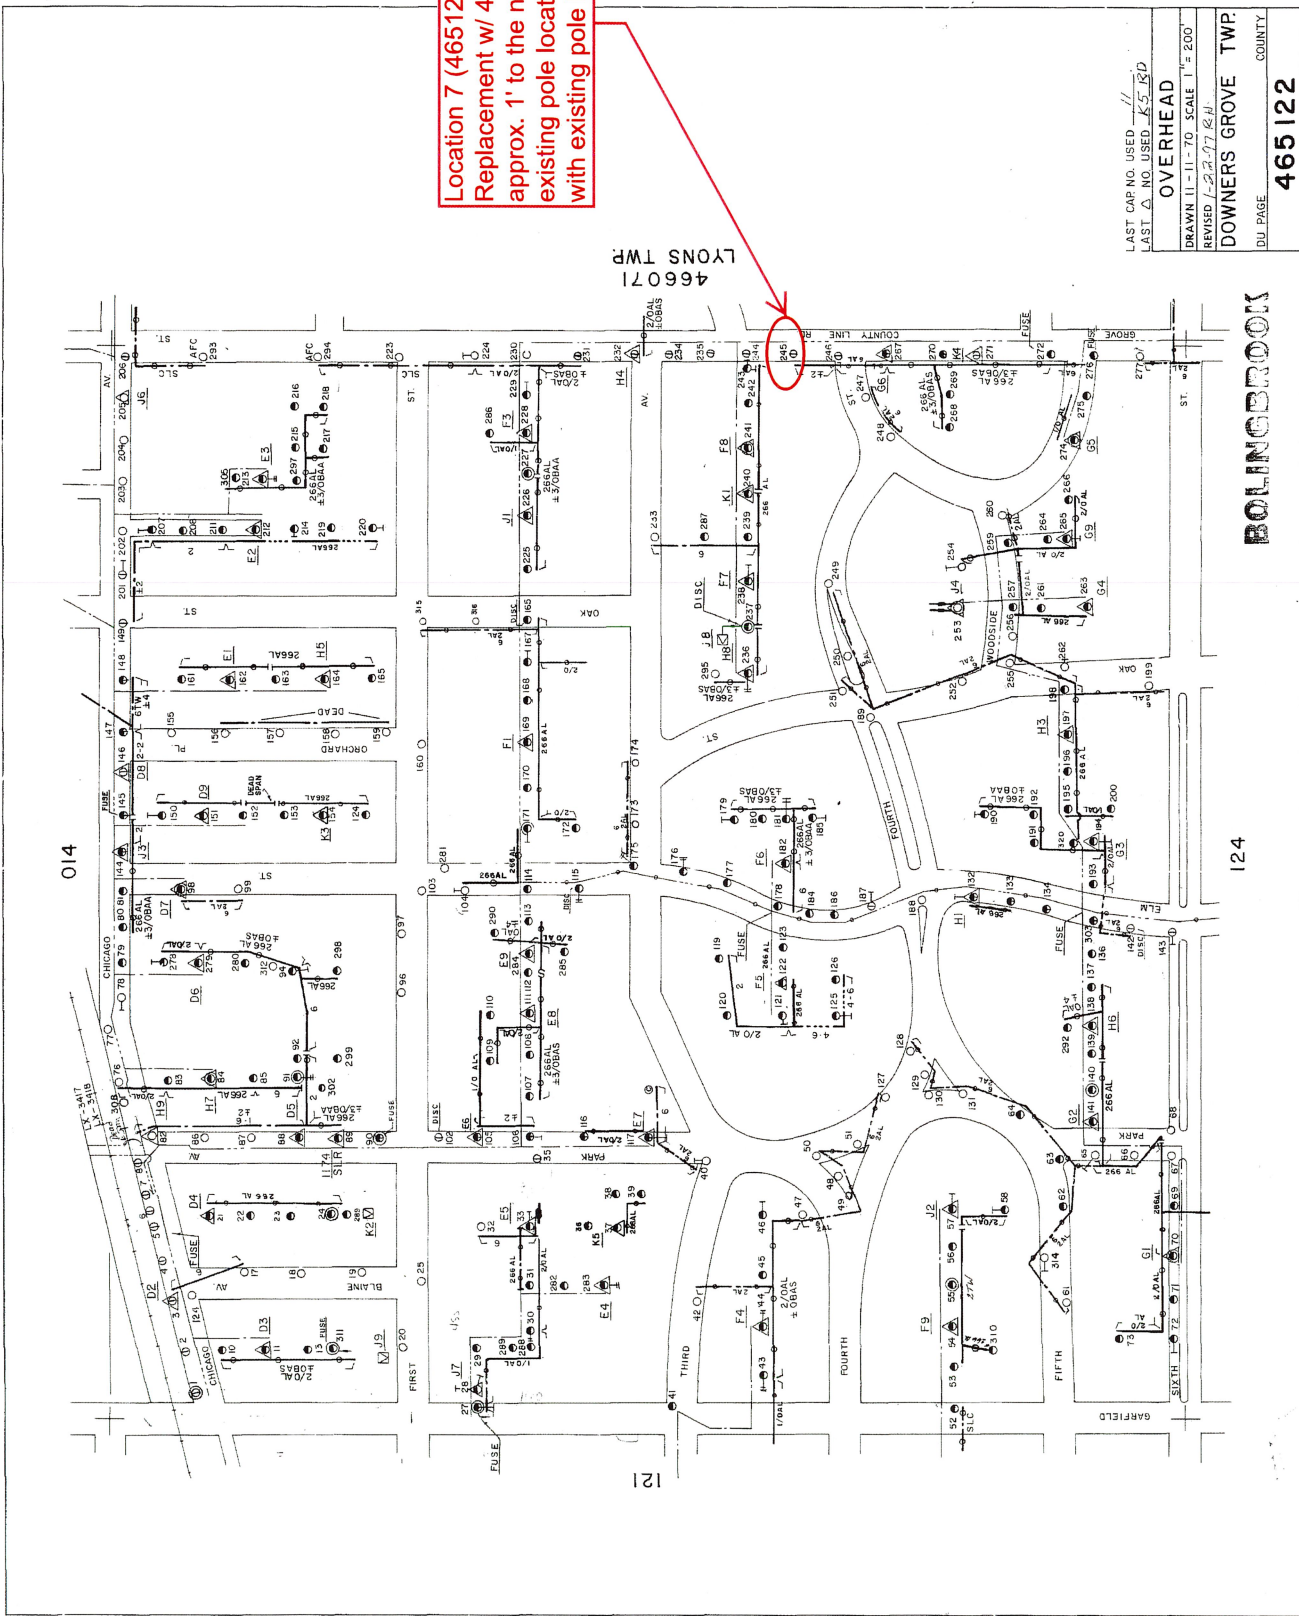

Location 7 (465122-245) Pole Replacement w/ 45/H1 pole approx. 1' to the north of existing pole location & aligned with existing pole line.


466071
LYONS TWP

LAST CAP NO. USED	11
LAST NO. USED	45.13D
OVERHEAD	
DRAWN 11-11-70	SCALE 1" = 200'
REVISED 1-23-77 & H	
DOWNERS GROVE TWP.	
DJ PAGE	COUNTY
465122	

C. E. Co. #641703 3-45

Location 6 (466073-040) Pole
Replacement w/ 45'12 pole
approx. 1' to the east of
existing pole location & aligned
with existing pole line.

DOWNERS GROVE TWP.
465124

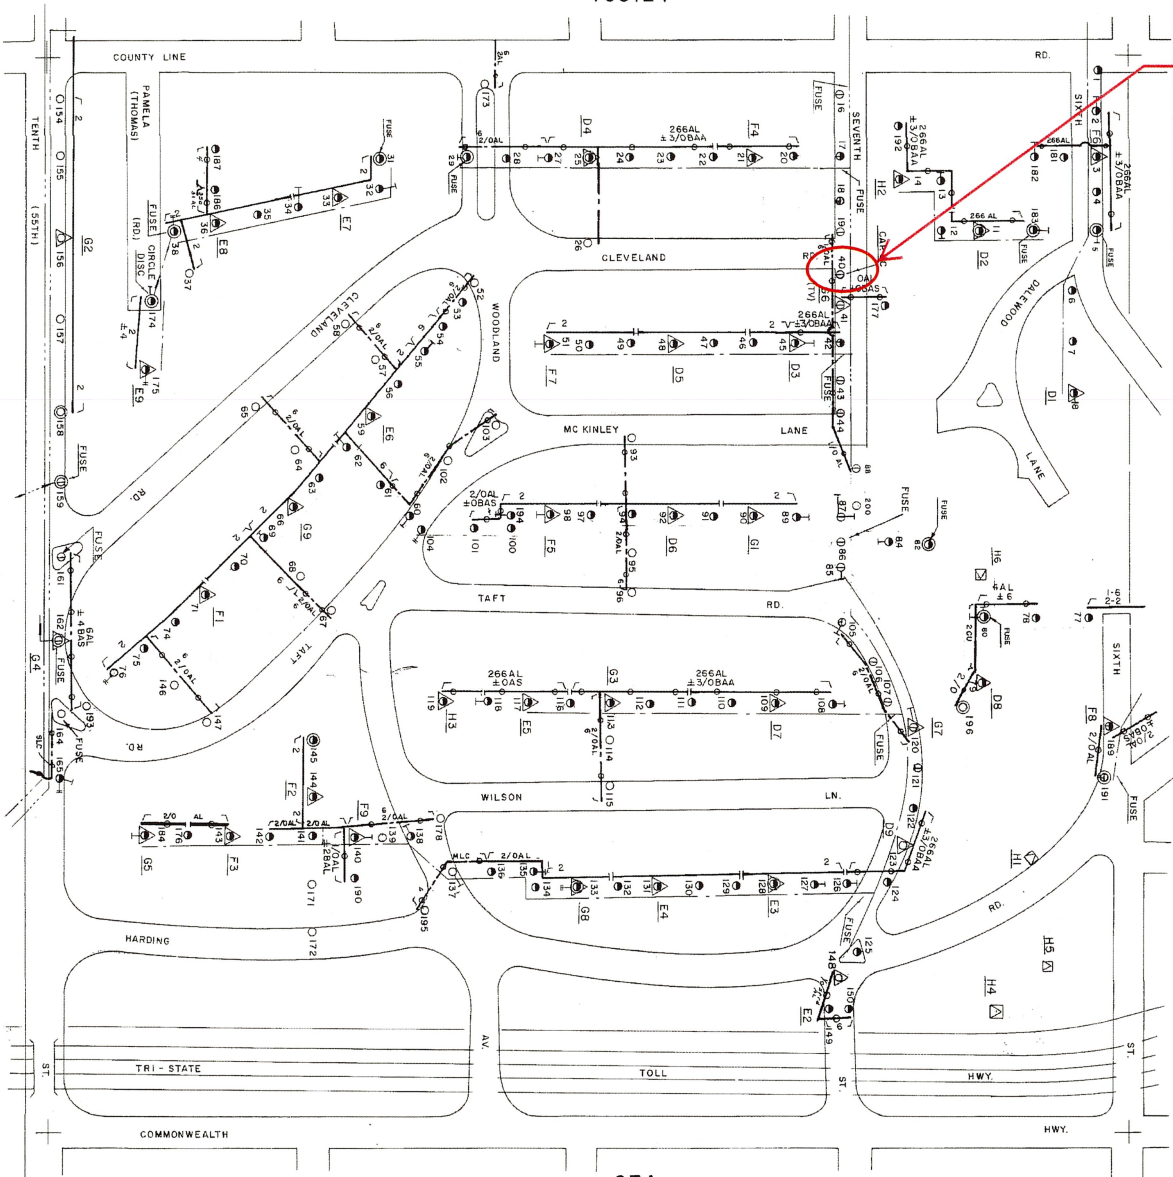

181


071


074

BOLNERSBROOK


BK

LAST CAP NO USED 30 - S.S.
LAST NO USED 115
OVERHEAD
DRAWN 5-25-71 SCALE 1" = 200'
REVISED 5/2/76
LYONS
TWP.
COUNTY
466073




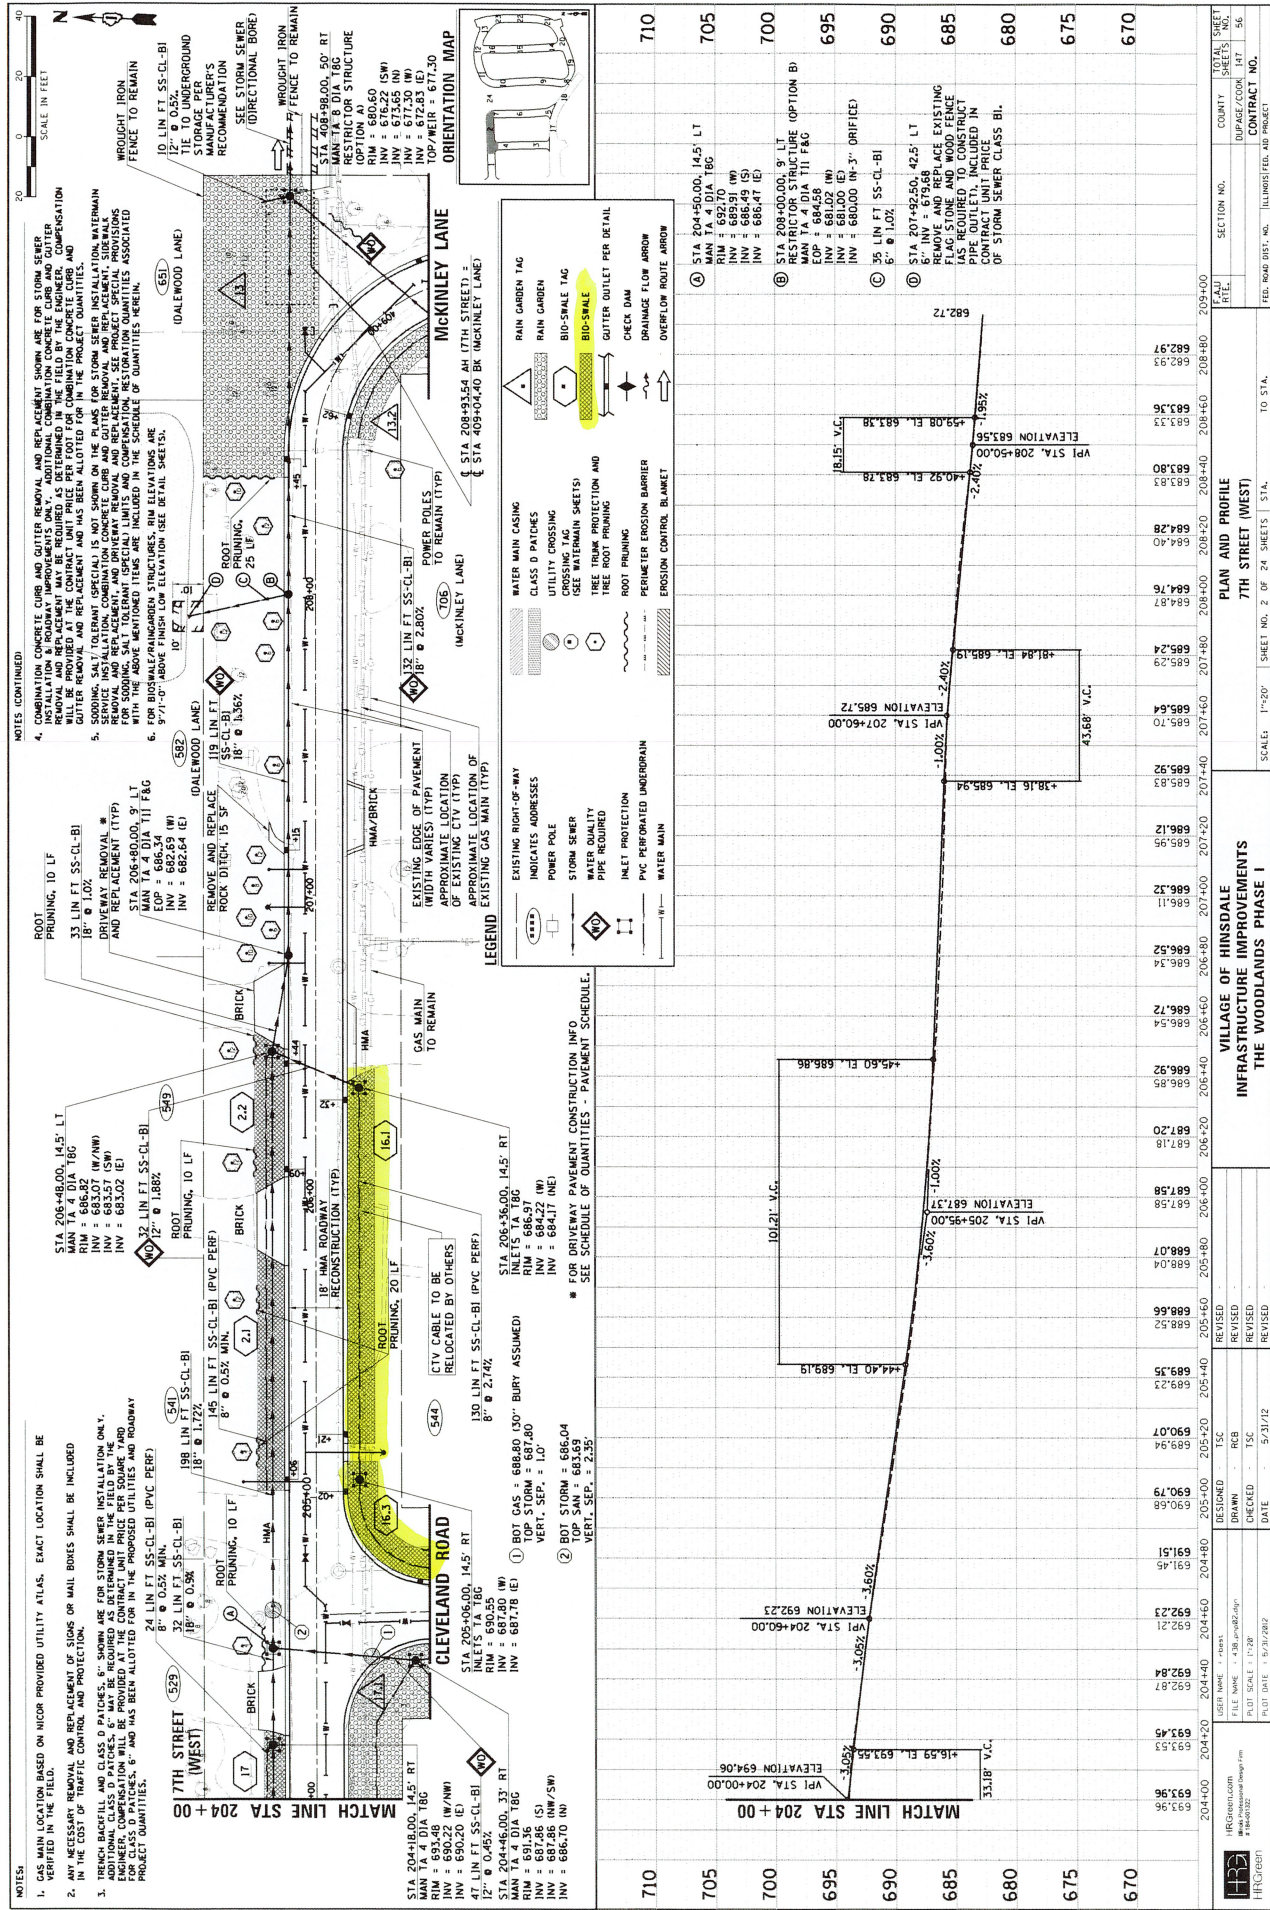


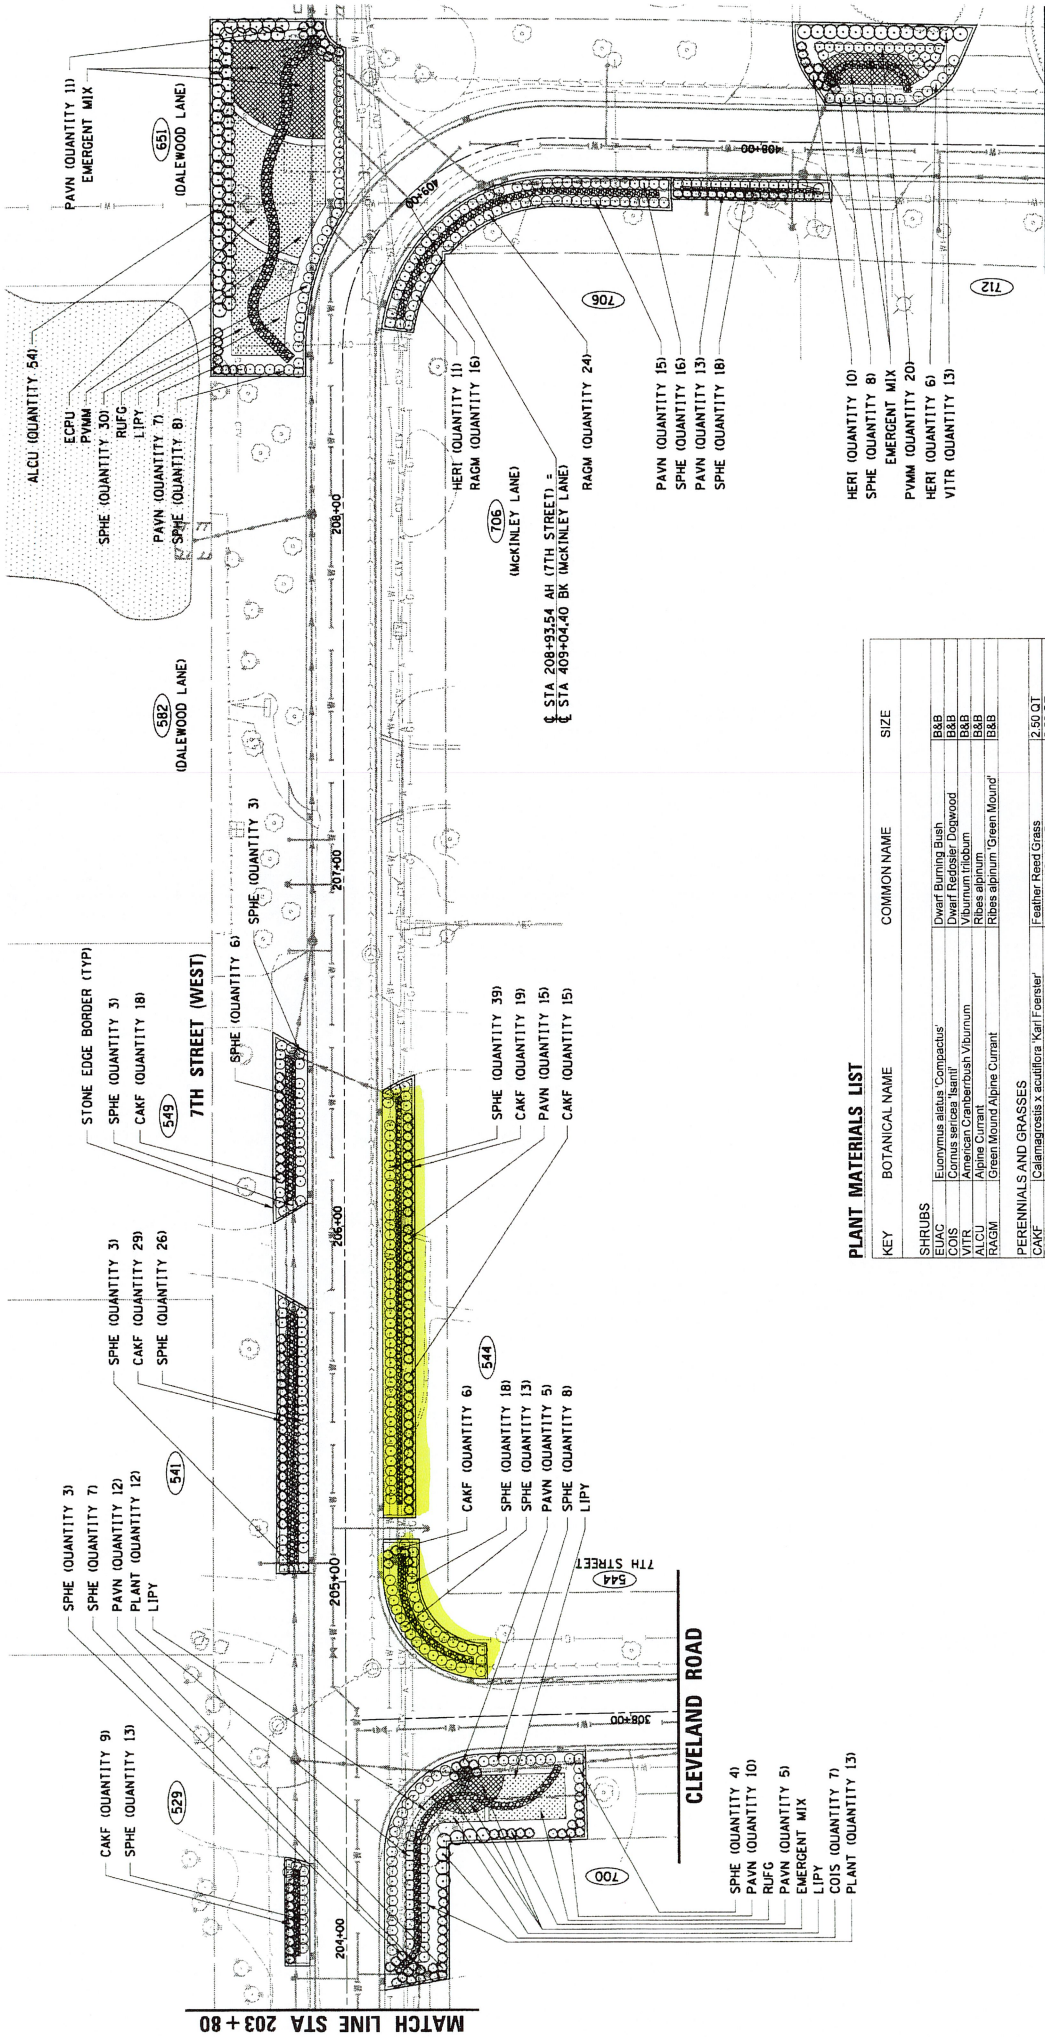

KEY	BOTANICAL NAME	COMMON NAME	SIZE
SHRUBS			
EUAC	<i>Eucornia alata</i> 'Compactus'	Dwarf Burning Bush	B&B
COIS	<i>Cornus sericea</i> 'Isanti'	Dwarf Redosier Dogwood	B&B
ALVU	<i>American Crabapple</i> 'Viburnum	Red Dogwood	B&B
ALCU	<i>Alnus</i>	Ribes alpinum 'Green Mound'	B&B
RAGM	<i>Green Mound Alpine Currant</i>		
PERENNIALS AND GRASSES			
CAAF	<i>Calliandragrostis x acutifolia</i> 'Karl Foerster'	Feather Reed Grass	2.50 QT
PAVN	<i>Panicum virgatum</i> 'Northwind'	Northwind Switch Grass	2.50 QT
ALDE	<i>Alum ornatum</i>	Nodding Onion	plug
HERI	<i>Heuchera</i> 'Richardsonii'	Pearle Alumroot	2.50 QT or 2.75 QT
ALUM	<i>Alum</i>	Black Alumroot	2.50 QT
PWMM	<i>Polemonium x virginica</i> 'Miss Manners'	Overland Plant 'Miss Manners'	2.50 QT
LIFY	<i>Liatris pycnostachya</i>	Prairie Blazingstar	plug
RUF6	<i>Rudbeckia fulgida</i> 'Goldsturm'	Black Eyed Susan	2.50 QT
SPHE	<i>Sporobolus heterophyllus</i>	Prairie Drossed	plug
ECPU	<i>Echinacea purpurea</i>	Purple Coneflower	plug
EMERGENT PLUG MIX			
PLUGMIX	<i>Alum ornatum</i>	Nodding White Onion	plug
PLUGMIX	<i>Calliandragrostis x acutifolia</i> 'Karl Foerster'	Feather Reed Grass	plug
PLUGMIX	<i>Cornus sericea</i>	Common Fox Sedge	plug
PLUG MIX	<i>Penstemon digitalis</i>	FogGlove Beardtongue	plug
NOTES:			
1.	Space all plugs 1' on center staggered in all Emergent Plug Mix Areas		
2.	Space all plugs 1.5' on center staggered in the Mescic Planting Areas		
3.	All emergent native plugs must be native, no cultivars will be accepted.		

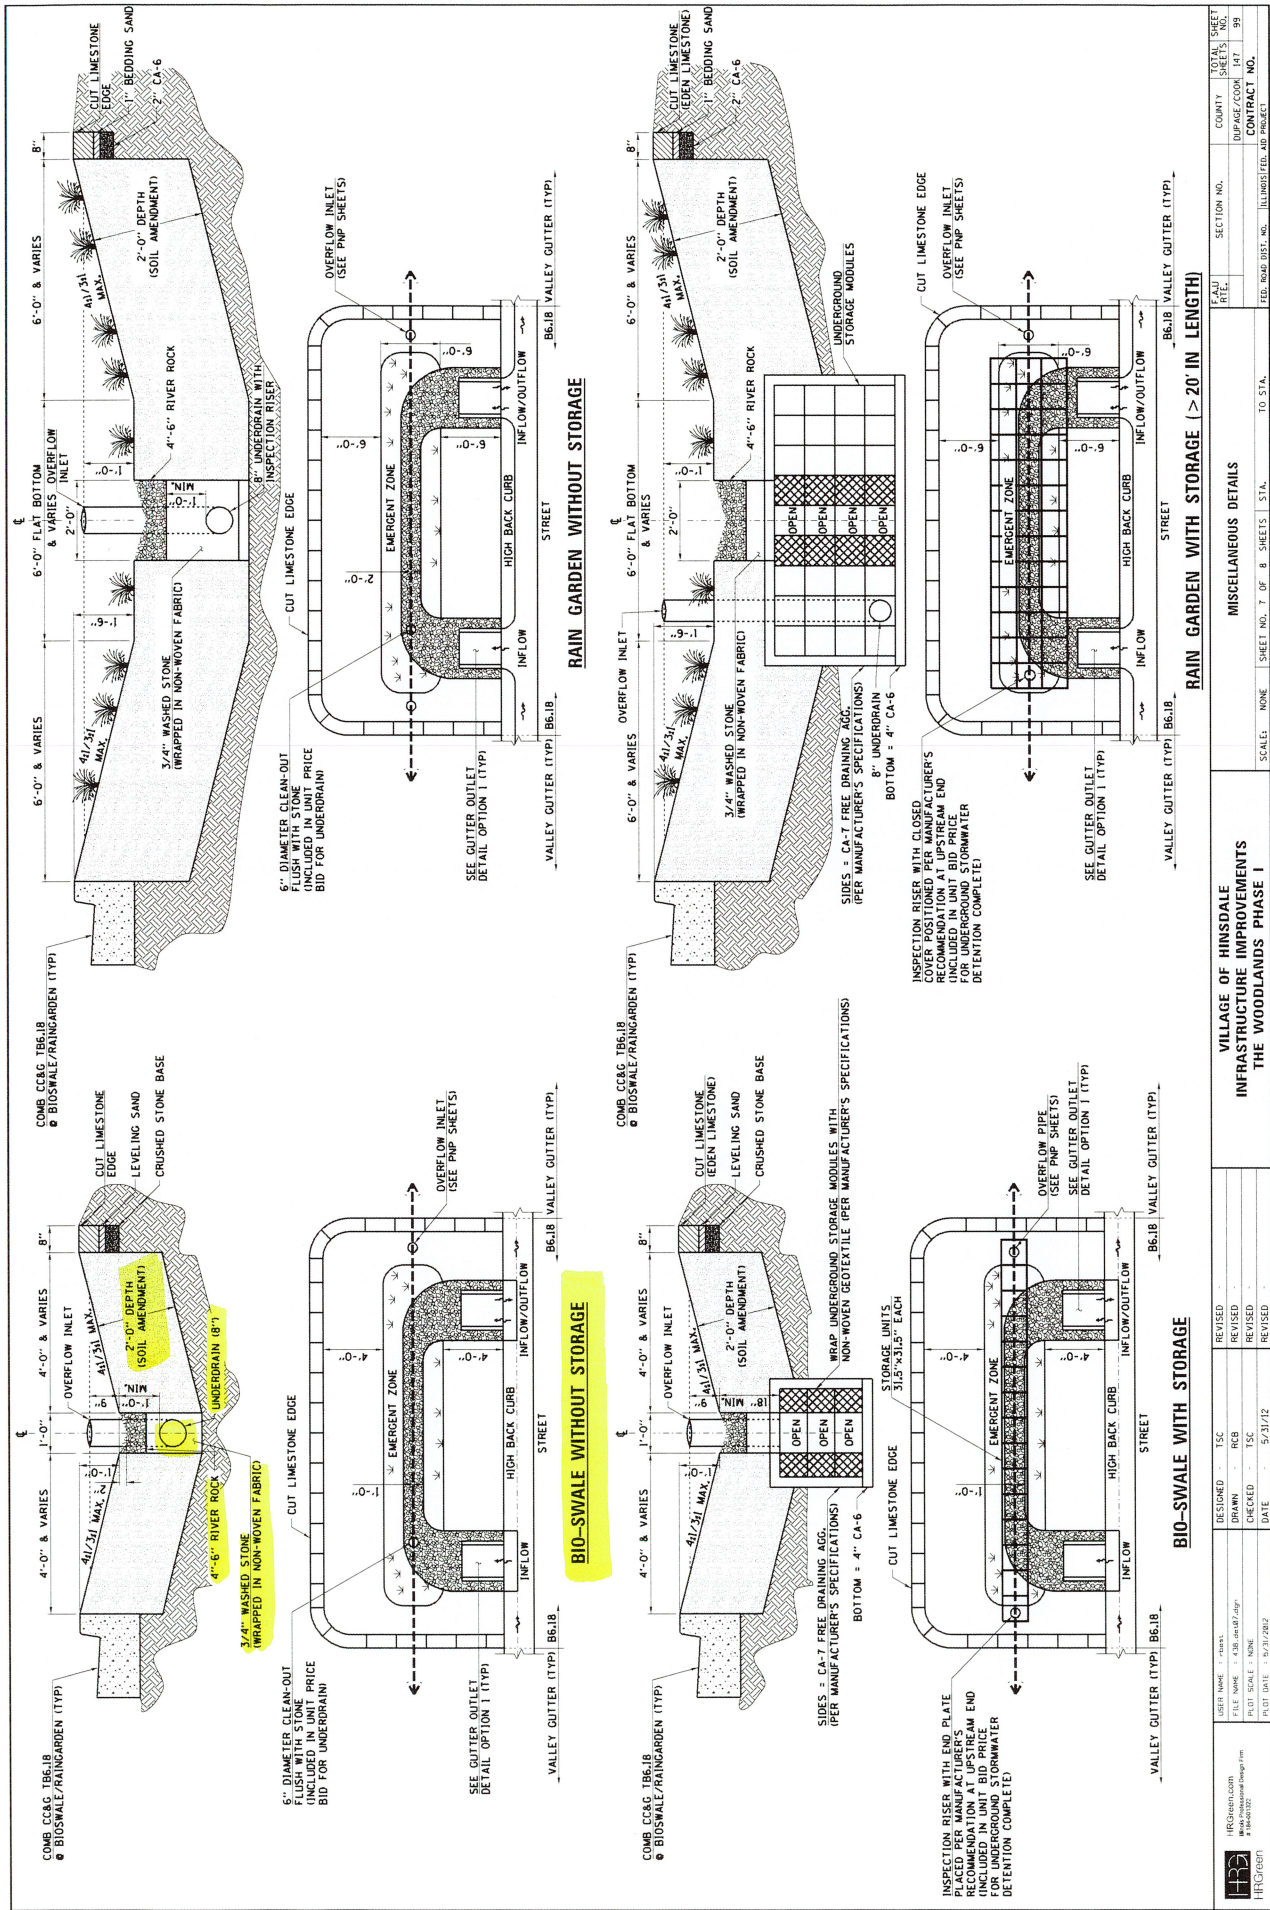

HEDGREEN HEDGREEN HEDGREEN USER NAME: - HEDGREEN FILE NAME: - 030_0427.dwg PLOT SCALE: - NONE PLOT DATE: - 5/31/2022 DESIGNED: - TSC DRAWN: - HGB CHECKED: - TSC DATE: - 5/31/2022		VILLAGE OF HINSDALE INFRASTRUCTURE IMPROVEMENTS THE WOODLANDS PHASE I		MISCELLANEOUS DETAILS		COUNTY: - DUPAGE/COOK: - 59 SHEET NO.: - CONTRACT NO.: -	
FEED ROAD DIST. NO.: - ILLUSTRATED AND PROJECTED: -		SCALE: NONE SHEET NO. 7 OF 8 SHEETS: 51A. TO STA.:					

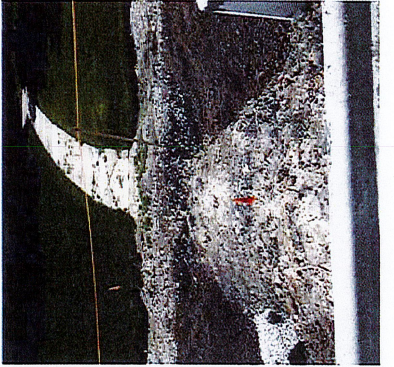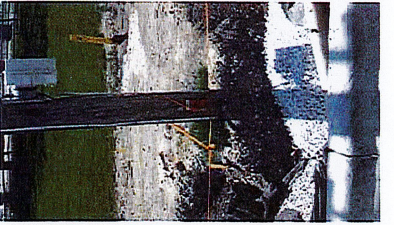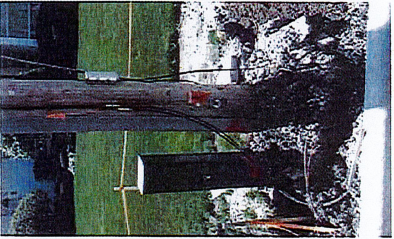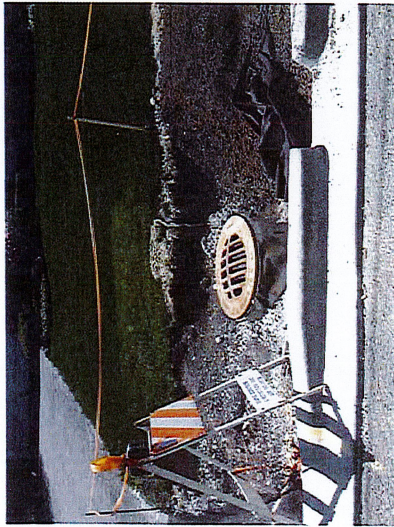

RG 16.1- 7th st (west)-

RG 16.3- 7th st (west)
@Cleveland-

