

Village of Hinsdale 19 E. Chicago Avenue Hinsdale, IL 60521-3489 (630)789-7000


Village Website: www.villageofhinsdale.org

PUBLIC SERVICES UTILITY PERMIT APPLICATION

Date of Application: 1-6-23 Permit No Comcast : 005	Permit Expiration Date: <u> </u>			
<u>Utility Company Information</u> :	Contractor Information:			
Company Name: Comcast Cable Address: 856 Technology Way City, State, Zip: Libertyville, IL Contact Person: Phillip Jones Phone Number: 630.688.7432 Email Address: phillip jones@comcast.com Cell Number: 630.688.7432 Project/Work Order Number: RSS-JB1307296RP	Company Name: RS Service Systems Address: 38 Forestwood Dr City, State, Zip: Romeoville, IL Contact Person: Jason Jost Phone Number: 815.293.9393 Email Address: jasonj@rs-services.com Cell Number: 815.405.1810			
PROJECT LOCATION: 831 W 8th Street				
Description of work covered under this permit: Install replacement C underground by directional bore in same location as existing damaged cable. Permit to include road bore underneath S Stough Street	ATV coax cable along 8th Street between 831 and 819 W 8th Street			
Start Date: ASAP	Completion Date:			
Site Plan/Details/Specifications (3 sets) included with application Certificate of Insurance included with application?	n? O YES O NO O YES O NO			
Type of Utility: ☐ ComEd ☐ Nicor ☑ Communications: ☐ Fiber Optic ☐	Comcast Water Sewer Wireless Other:			
Applicant Information:				
Print Name: Olivia Carlin	Phone Number: 630.522.3024			
Company: ESPO Engineering	Email Address: ocarlin@espocorp.com			
Signature: Olivia Carlin	Date: 1/6/23			
ALL CONSTRUCTION SHALL BE DONE IN ACCORDANCE WITH THE LATES THE FOLLOWING: STANDARD SPECIFICATIONS FOR ROAD AND BRIDGE RECURRING SPECIAL PROVISIONS BY THE ILLINOIS DEPARTMENT OF TI CONTROL DEVICES FOR STREETS AND HIGHWAYS, STANDARD SPECIFI ILLINOIS, AND THE VILLAGE OF HINSDALE SUBDIVISION ORDINANCE AND	CONSTRUCTION & SUPPLEMENTAL SPECIFICATIONS AND RANSPORTATION, ILLINOIS MANUAL ON UNIFORM TRAFFIC CATIONS FOR WATER AND SEWER MAIN CONSTRUCTION IN			
Village Use Only				
Permit Approved: YES NO				
Conditions for Approval/Reasons for Denial: RESTORE ALL AFTER COMPLETION. NOTIFY ALL LOS	DISTURBED AREAS 14 DAYS CAL RESIDENTS 48 HOURS PKION			
Approved By: # Diaz	Date:			

VILLAGE OF HINSDALE PERMIT DRAWING 831 w 8TH ST HINSDALE, IL

SITE MAP

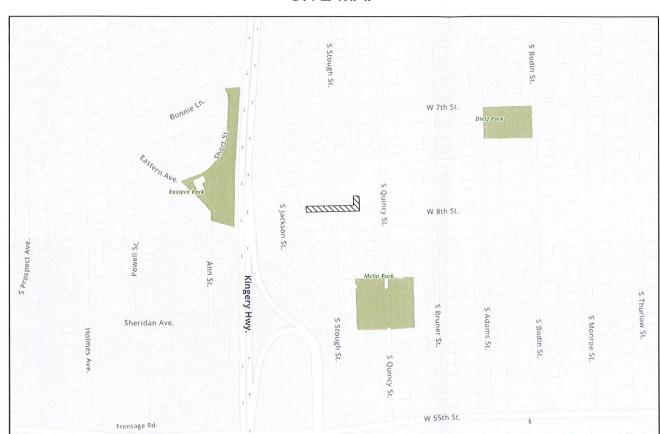

NOT TO SCALE

DUPAGE COUNTY DOWNERS TWP T38N R11E N.W.1/4 OF S.E.1/4 OF SEC.11

INDEX OF SHEETS

- 1. COVER SHEET
- 2. PLAN SHEET

PROJECT DESCRIPTION

PROPOSED INSTALLATION OF UNDERGROUND CABLE -2"Ø HDPE w/1-.625 COAX @ 36" MIN. DEPTH BY DIRECTIONAL BORING

PROJECT DETAIL

CABLE LENGTH (ft): 369

COMCAST COORD: ADAM BRADEN

LEGEND SYMBOLS TELEPHONE POLE × POWER POLE CATV POLE ▼ CATV VAULT P TELCO VAULT T TRAFFIC CONTROL VAULT □ CATV PED UNMARKED VAULT ☑ CATV LOCKBOX ☑ BORE/SPLICE PIT ⊕_{F,E}FIRE HYDRANT ☑ CATV POWER SUPPLY ⊕ CATCH BASIN 🔁 AIR CONDITIONER ⑤ SEWER DRAIN ☑ GENERATOR CULVERT PIPE @ WATER METER WATER VALVE UNMARKED MANHOLES +₩ GAS VALVE CATV MANHOLE ELECTRIC MANHOLE ▼ TELCO PED TRANSFORMER (1) TRAFFIC MANHOLE MAIL BOX TELEPHONE MANHOLE FIBER MARKER [Indicate Ownership) SEWER MANHOLE © GAS METER WATER MANHOLE S ROAD SIGN (Indicate Ownership e.g. DWC) R.R. X-ING GATE GAS MARKER (Indicate Ownership) C TREE RIGHT-OF-WAY MARKER ® BUSH ☼ STREET LIGHT ☼ TRAFFIC SIGNAL LIGHT E ELECTRIC VAULT/ PED/METER CENTER LINE - - - - - - - RIGHT-OF-WAY LINE ---- PROPERTY LINE — — — — UTILITY EASEMENT AFR AFR OVERHEAD CARLE —DB—DB—DB—DIRECTIONAL BORE CABLE -TR-TR-TR-TR-TRENCH CABLE - EX-EX-EX-EXISTING PIPE/CONDUIT HB HB HAND-BURY CABLE --->---> SANITARY SEWER — STORM SEWER MAIN — g — g — GAS MAIN — TEL — TEL — TELCO CABLE — E — E — BURIED ELECTRIC CABLE



THE INFORMATION IN THIS DRAWING FILE IS PROPRIETARY AND CONFIDENTIAL AND MAY NOT BE REPRODUCED OR TRANSMITTED BY WRITTEN PERMISSION FROM COMCAST.

RS SERVICE SYSTEMS, INC

JOB NO.:	RSS-JB1307296RP
PROJECT TITLE:	COMCAST U-GROUND
C	COMMUNICATION CABLE
	REPLACEMENT
LOCATION:	Ť
	831 W 8TH ST
	HINSDALE,IL
DRAWING NO.	DOG 104007000DD
DRAWING NO	RSS-JB1307296RP

ESPO ENGINEERING


ENG NUMBER: RSS-22-3851

DRAWN BY: IH DATE: 12/29/2022

ISSUED FOR PERMITTING

SCALE: N.T.S. **REVISIONS**

DATE	BY	DESCRIPTION
-	21	=
-	-	-
-	-	

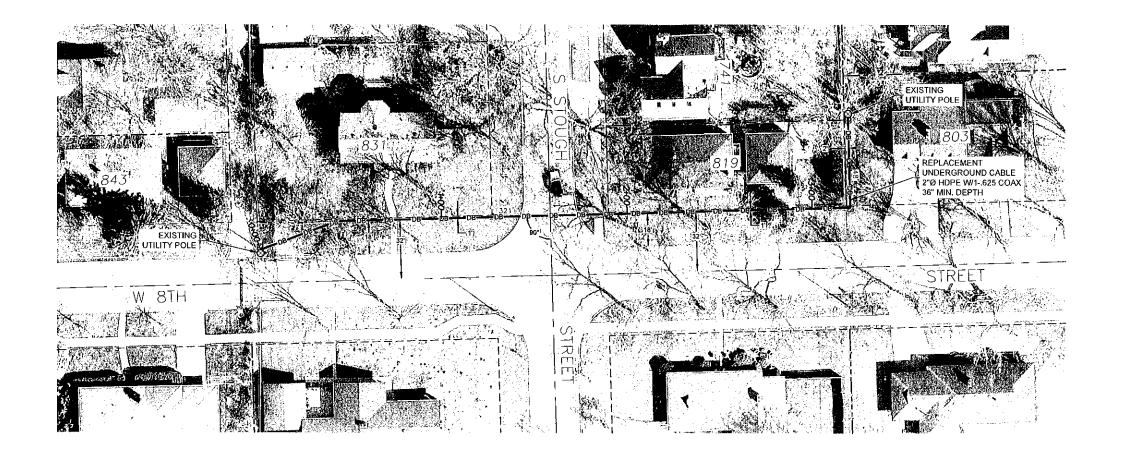

LEGEND

SYMBOLS CATV POLE EXF SERVICE RISER CATV VAULT → GUY AND ANCHOR ■ TELCO VAULT ■ TRAFFIC CONTROL VAULT UNMARKED VAULT □ CATV PED ☑ CATV LOCKBOX ☑ BORE/SPLICE PIT Op FIRE HYDRANT ☑ CATV POWER SUPPLY ⑤ SEWER DRAIN ☐ GENERATOR WATER VALVE UNMARKED MANHOLES ⊕ GAS VALVE ☑ CATV MANHOLE ☑ TELCO PED ELECTRIC MANHOLE ■ TRANSFORMER ☐ TRAFFIC MANHOLE TRANSFORMER TRANSFORMER MAIL BOX TRANSFORMER TRANSFOR (Indicate Ownership) 8 RIGHT-OF-WAY MARKER (Bench Mark) TREE ® BUSH ☼ STREET LIGHT ☼ TRAFFIC SIGNAL LIGHT ■ ELECTRIC VAULT/ PED/METER CENTER LINE ----- --- --- --- CENTER LINE ---- PROPERTY LINE — — — UTILITY EASEMENT ——AER——AER—— OVERHEAD CABLE DB-DB-DB-DB-DIRECTIONAL BORE CABLE TR—TR—TR— TRENCH CABLE - EX- EX- EX- EXISTING PIPE/CONDUIT HB HB HAND-BURY CABLE -->--> SANITARY SEWER ->----- STORM SEWER MAIN

(comcast

THE INFORMATION IN THIS DRAWING FILE IS PROPRIETARY AND CONFIDENTIAL AND MAY NOT BE REPRODUCED OR TRANSMITTED BY ANY MEANS OF CONVEYANCE WITHOUT WRITTEN PERMISSION FROM COMCAST.

RS SERVICE SYSTEMS, INC 38 FORESTWOOD DR. ROMEOVILLE, IL 60446 (815) 293-9393

JOB NO.:	RSS-JB1307296RP
PROJECT TITLE	: COMCAST U-GROUND
	COMMUNICATION CABLE
	REPLACEMENT
LOCATION	·
LUCATION	
LOCATION	
	831 W 8TH ST
	831 W 8TH ST
DRAWING NO.	831 W 8TH ST HINSDALE,IL

ESPO ENGINEERING

630,789,2525 www.especorp.com

ENG NUMBER: RSS-22-3851

DRAWN BY: IH

DATE: 12/29/2022

ISSUED FOR PERMITTING SCALE: 1"=50"

