

WASTEWATER TREATMENT PLANT IMPROVEMENTS - PRE DESIGN REPORT



© 2007, City of Sutherlin

CITY OF SUTHERLIN DOUGLAS COUNTY, OREGON

PROJECT NO. 146.38


MAY 2016

ENGINEER:



THE DYER PARTNERSHIP
ENGINEERS & PLANNERS, INC.
1330 Teakwood Avenue / Coos Bay, Oregon 97420
(541) 269-0732 / WWW.DYERPART.COM

THIS PROJECT IS FUNDED BY THE OREGON DEPARTMENT OF
ENVIRONMENTAL QUALITY CLEAN WATER STATE REVOLVING
FUND AGREEMENT NO. R89540

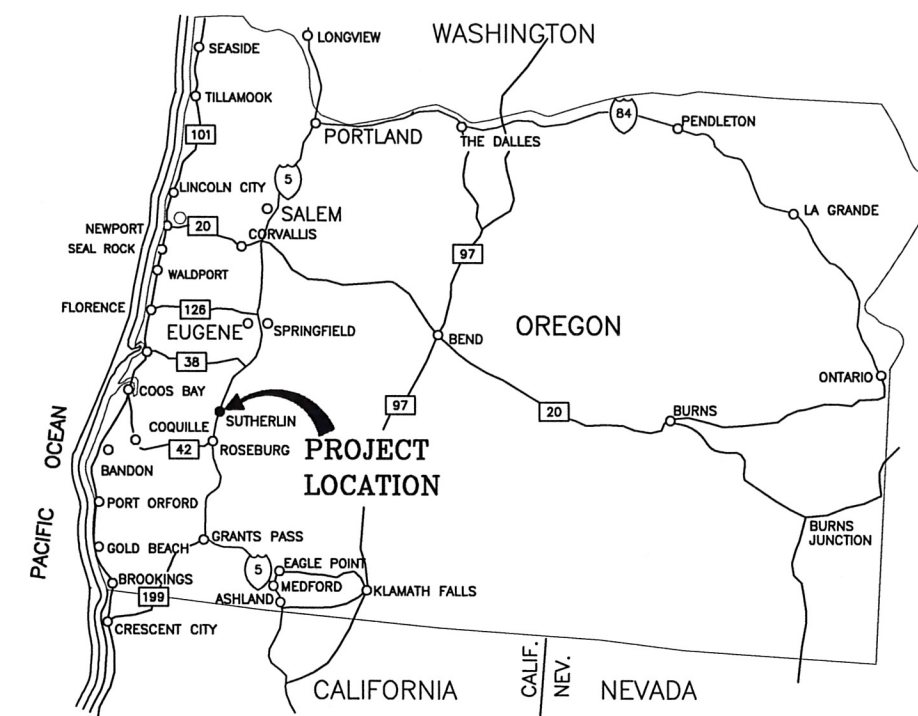

LOCATION MAP
NOT TO SCALE



\\dyer\dyer-part\A\projects\146 Sutherland\146.38 WWTF Pre-Design Report\dwg\PRE-DESIGN\GENERAL\G1 DWG INDEX.dwg, 3/22/2016 9:24:32 AM PLOT DATE May 5, 2016

DWG #.	SHT. #	DESCRIPTION
GENERAL		
G1	1	INDEX TO DRAWINGS
G2	2	VICINITY MAP
G3	3	ABBREVIATIONS, GENERAL NOTES, AND LEGEND
G4	4	DESIGN DATA
G5	5	DESIGN DATA CONT.
G6	6	OVERALL HYDRAULIC PROFILE- LIQUID STREAM
G7	7	HYDRAULIC PROFILE
G8	8	HYDRAULIC PROFILE
G9	9	HYDRAULIC PROFILE

PROCESS

P1	10	STANDARD SYMBOLS
P2	11	GENERAL PROCESS DIAGRAM - LIQUID STREAM
P3	12	GENERAL PROCESS DIAGRAM - WASTE STREAM
P4	13	MAIN CONTROL PANEL
P600	14	INFLUENT SCREENING FACILITY
P700	15	INFLUENT PUMP STATION
P800	16	HEADWORKS
P900	17	SBR
P901	18	SBR BLOWERS
PI000	19	TERTIARY FILTERS
PI100	20	ULTRAVIOLET DISINFECTION
PI200	21	EFFLUENT DISPOSAL - REUSE
PI300	22	BIOSOLIDS TREATMENT
PI301	23	BIOSOLIDS TREATMENT BLOWERS
PI302	24	EFFLUENT DISPOSAL - SLUDGE DEWATERING

DEMOLITION

DI00	25	EXISTING SITE
D200	26	EXISTING FILTER BUILDING
D300	27	EXISTING OPERATIONS BUILDING
DI300	28	EXISTING TREATMENT PLANT

DWG #.	SHT. #	DESCRIPTION
CIVIL		
CI00	29	NEW WWTP SITE PLAN
CI01	30	NEW SITE GRADING PLAN
CI02	31	NEW YARD PIPING SITE PLAN
ARCHITECTUAL		
A210	32	BIOSOLIDS STORAGE FACILITY
A400	33	CONTROL BUILDING - FLOOR PLAN
A401	34	CONTROL BUILDING - ELEVATIONS
A500	35	SHOP BUILDING - FLOOR PLAN
A501	36	SHOP BUILDING - SECTIONS & ELEVATIONS

SCREENING FACILITY

M600	37	INFLUENT SCREEN PLAN AND SECTIONS
S600	38	INFLUENT SCREEN STAIRCASE DETAIL

INFLUENT PUMP STATION

M700	39	MECHANICAL PLAN AND ELEVATION VIEW
------	----	------------------------------------

HEADWORKS

M800	40	MECHANICAL-UPPER PLAN VIEW
M801	41	MECHANICAL- LOWER PLAN VIEW
M802	42	MECHANICAL- TYPICAL SECTION
M803	43	MECHANICAL- TYPICAL SECTION
S800	44	STRUCTURAL- UPPER PLAN VIEW
S801	45	STRUCTURAL- LOWER PLAN VIEW
S802	46	STRUCTURAL- TYPICAL SECTION
S803	47	STRUCTURAL- TYPICAL SECTION

DWG #.	SHT. #	DESCRIPTION
SBR		
M900	48	MECHANICAL-PLAN VIEW
M901	49	MECHANICAL- SECTION
M902	50	MECHANICAL- SECTION
S900	51	STRUCTURAL- PLAN VIEW
S901	52	STRUCTURAL- SECTION
S902	53	STRUCTURAL- SECTION

TERTIARY FILTER

MI000	54	MECHANICAL- PLAN VIEW
MI001	55	MECHANICAL- SECTION
MI002	56	MECHANICAL- SECTION
SI000	57	STRUCTURAL- PLAN VIEW
SI001	58	STRUCTURAL- SECTION
SI002	59	STRUCTURAL- SECTION

UV DISINFECTION

MI100	60	MECHANICAL - PLAN VIEW
MI101	61	MECHANICAL - TYPICAL SECTION
SI100	62	STRUCTURAL - PLAN VIEW

BIOSOLIDS TREATMENT

MI300	63	EXISTING DIGESTER - REHABILATION
MI301	64	OUTER TANKS - SECTION VIEWS
MI302	65	CENTER TANK SECTION VIEWS
MI303	66	CENTER TANK - SECTION VIEW
MI310	67	SLUDGE DEWATERING - PLAN VIEW

EVERETT AVE. PUMP STATION

DI400	68	DEMOLITION- PLAN VIEW
MI400	69	MECHANICAL- PLAN VIEW
MI401	70	MECHANICAL- TYPICAL SECTION



<u>DESIGNED:</u> _____	<u>DRAWN:</u> _____	<u>REVISIONS</u>				
		<u>REVISED</u>	<u>DESCRIPTION</u>	<u>SUBMIT.</u>	<u>APPR'D.</u>	<u>DATE</u>
<u>APPROVED BY:</u> _____ <u>DATE:</u> _____						



THE DYER PARTNERSHIP
ENGINEERS & PLANNERS, INC.
1330 TEAKWOOD AVENUE
COOS BAY, OREGON 97420
TELEPHONE: (541) 269-0732
www.dyerpart.com

LINE IS 1 INCH
AT FULL SCALE
IF NOT 1-INCH - SCALE ACCORDINGLY

**WASTEWATER TREATMENT PLANT IMPROVEMENTS
CITY OF SUTHERLIN**


**GENERAL
INDEX TO DRAWINGS**

PROJECT NO. 146.38	DRAWING NO. G1
DATE MAY 2016	SHEET NO. 1 OF 70

\\dye\dyer-part\A\projects\146 Sutherlin\146.38 WWTF Pre-Design Report\dwg\PRE-DESIGN\GENERAL\G2 VICINITY MAP.dwg, 11/30/2015 3:25:40 PM PLOT DATE May 5, 2016



SUTHERLIN WWTP VICINITY MAP
SCALE: 1" = 500'

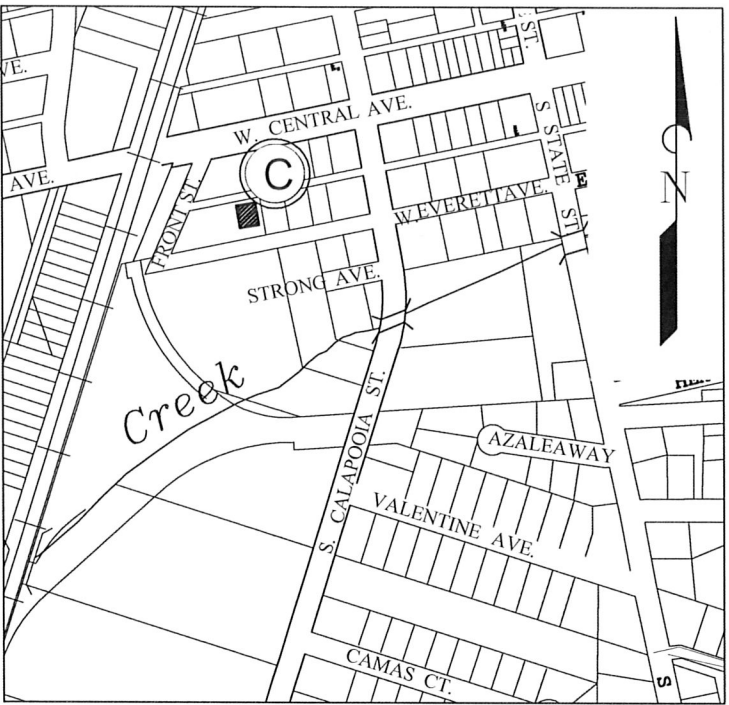

EVERETT AVE. PUMP STATION VICINITY MAP
SCALE: 1" = 500'

- (A) WWTP IMPROVEMENTS
- (B) FORDS POND
- (C) EVERETT AVE. PUMP STATION



DESIGNED: _____		DRAWN: _____		REVISIONS				
				REVISED	DESCRIPTION	SUBMIT.	APPR'D.	DATE



THE DYER PARTNERSHIP
ENGINEERS & PLANNERS, INC.
1330 TEAKWOOD AVENUE
COOS BAY, OREGON 97420
TELEPHONE: (541) 269-0732
www.dyerpart.com

LINE IS 1 INCH
AT FULL SCALE
IF NOT 1-INCH - SCALE ACCORDINGLY

WASTEWATER TREATMENT PLANT IMPROVEMENTS
CITY OF SUTHERLIN

GENERAL
VICINITY MAP

PROJECT NO. 146.38	DRAWING NO. G2
DATE MAY 2016	SHEET NO. 2 OF 70

\\dyer\dyer-part\A\Projects\146 Sutherland\146.38 WWTF Pre-Design Report\dwg\PRE-DESIGN\GENERAL\03 ABR-SYM-LEGEND.dwg, 5/3/2016 9:04:57 AM PLOT DATE May 5, 2016

ABBREVIATIONS

A	AIR	LF	LINEAR FEET
AB	ANCHOR BOLT	LG	LONG
AC	ASPHALTIC CONCRETE	LPT	LOWPOINT
ADPTR	ADAPTER	LT	LEFT
AGG	AGGREGATE	LWL	LOW WATER LEVEL
AL	ALUMINUM		
APPROX	APPROXIMATE	MATL	MATERIAL
ARV	AIR RELEASE VALVE	MAX	MAXIMUM
AUX	AUXILIARY	MECH	MECHANICAL
BKFL	BACKFILL	MFR	MANUFACTURER
BLDG	BUILDING	MH	MANHOLE
BM	BENCH MARK	MIN	MINIMUM
BWL	BOTTOM WATER LEVEL	MJ	MECHANICAL JOINT
C		MSTR	MASTER
	CONDUIT	NPW	NON-POTABLE WATER
CARV		NTS	NOT TO SCALE
CB	CATCH BASIN	NIC	NOT IN CONTRACT
	CAST IRON		
CFM	CUBIC FEET PER MINUTE	OC	ON CENTER
CL	CHLORINE	OD	OUTSIDE DIAMETER
CMP	CORRUGATED METAL PIPE	OF	OVERFLOW
CMU	CONCRETE MASONRY UNIT		
CNTRL	CONTROL	P	PHASE (ELEC)/PUMP
CO	CLEAN OUT	PC	POINT OF CURVATURE
CONC	CONCRETE	PD	PUMPED DRAINAGE
CONN	CONNECTION	PE	PLAIN END
CONST	CONSTRUCTION	PERF	PERFORATED
CONT	CONTINUOUS	PI	POWER INPUT
CORP	CORPORATION	PL	PLATE
CPLG	COUPLING	POL	POLYMER
CTR	CENTER	PV	PLUG VALVE
CUL	CULVERT	PM	PRESSURE MAIN
		P/P	POWER POLE/UTILITY POLE
		PRESS.	PRESSURE
D	DRAIN	P/S	PUMPING STATION
DB	DIGESTED BIOSOLIDS	PS	PIPE SUPPORT
DET	DETAIL	PSF	POUNDS PER SQUARE FOOT
DI	DUCTILE IRON	PSI	POUNDS PER SQUARE INCH
DIA	DIAMETER	PST	PRESSATE
DIM	DIMENSION	PVC	POLYVINYL CHLORIDE
DIP	DUCTILE IRON PIPE	PVMT	PAVEMENT
DR	DRAIN		
DS	DIGESTED SLUDGE	R	RADIUS
DWG	DRAWING	RAS	RETURN ACTIVATED SLUDGE
		RCL	RECLAIMED WATER
EA	EACH	RDCR	REDUCER
EFF	EFFLUENT	REINF	REINFORCING
EL/ELEV	ELEVATION	REQ'D	REQUIRED
ELB	ELBOW	ROW	RIGHT OF WAY
ELEC	ELECTRICAL	RS	RAW SEWAGE
EOP	EDGE OF PAVEMENT	RT	RIGHT
EW	EACH WAY	RW	REUSE WATER
EXIST'G	EXISTING		
EXT	EXTERIOR	SA	SERVICE AIR
		SCH	SCHEDULE
FCA	FLANGE COUPLING ADAPTER	SD	SANITARY DRAIN
FD	FLOOR DRAIN	SE	SECONDARY EFFLUENT
FE	FINAL EFFLUENT	SEC	SECTION
FF	FINISH FLOOR	SHWL	STORM HIGH WATER LEVEL
FG	FINISH GRADE	SN	SUPERNATANT
FH	FIRE HYDRANT	SPEC	SPECIFICATIONS
FL	FLOWLINE	SS	SQUARE
FLG	FLANGED	SSS	SANITARY SEWER
FM	FORCE MAIN	SST	STAINLESS STEEL
FO	FIBER OPTIC	STA	STATION
FOC	FACE OF CURB	STD	STORM DRAIN
FT	FEET	STL	STEEL
FTG	FOOTING	SUBM	SUBMERSION
		SOG	SLAB-ON-GRADE
G	GRIT	SVC	SERVICE
GALV	GALVANIZED	TBC	TOP BACK CURB
GIP	GALVANIZED IRON PIPE	TBM	TEMPORARY BENCH MARK
GND	GROUND (ELEC)	TCPLG	TRANSITION COUPLING
GPD,H,M		TD	TANK DRAIN
GV	GATE VALVE	TE	TERTIARY EFFLUENT
		TF	TERTIARY FILTER
HB	HOSE BIB	TOB	TOP OF BANK
HDPE	HIGH DENSITY POLYETHYLENE	TOE	TOE OF BANK
HORIZ	HORIZONTAL	TOF	TOP OF FOOTING
HP	HORSE POWER	TOW	TOP OF WALL
HPT	HIGH POINT	THD	THREADED
HT	HEIGHT	TRANS	TRANSITION
HW	HOT WATER	TS	TRANSFER SLUDGE
HWL	HIGH WATER LEVEL	TYP	TYPICAL
IE	INVERT ELEVATION	UON	UNLESS OTHERWISE NOTED
INT	INTERIOR		
INV	INVERT	V	VENT
		VLV	VALVE
JB	JUNCTION BOX	VAR	VARIES
LAT	LATERAL	W	CITY WATER POTABLE
L	LENGTH	WAS	WASTE ACTIVATED SLUDGE
		W/O	WITH
			WITHOUT
		YD	YARD
		(W)	WEST
		(E)	EAST
		(N)	NORTH
		(S)	SOUTH
		Ø	DIAMETER



GENERAL NOTES

1. VERTICAL DATUM BASED ON BM V495. (EL. = 445.49' - 1988 NAVD). [DOUGLAS COUNTY SURVEYOR'S OFFICE (DCSO) FILE #CS66/024 DATE 2000]
2. HORIZONTAL CONTROL IS SPC OREGON SOUTH @ NGS "UMPQUA NE BASE" N:642,917.20 E:4,168,902.82.
3. THE CONTRACTOR IS SPECIFICALLY CAUTIONED THAT THE LOCATION AND/OR ELEVATION OF EXISTING UTILITIES, AS SHOWN ON THESE PLANS, IS BASED ON FIELD LOCATES AND RECORDS OF THE VARIOUS UTILITY COMPANIES AND, WHERE POSSIBLE MEASUREMENTS IN THE FIELD. THE INFORMATION IS NOT TO BE RELIED UPON AS BEING EXACT OR COMPLETE. THE CONTRACTOR MUST CONTACT "ONE-CALL" AT 811. THE TELEPHONE NUMBER FOR THE OREGON UTILITY NOTIFICATION CENTER IS (503) 232-1987. FOR UTILITY LOCATES AT LEAST 48 HOURS BEFORE ANY EXCAVATION. PRIOR TO CONSTRUCTION, THE CONTRACTOR SHALL VERIFY PERTINENT LOCATIONS AND ELEVATIONS ESPECIALLY AT CONNECTIONS AND AT POTENTIAL UTILITY CONFLICTS.
4. THE OVERHEAD ELECTRIC LOCAL DISTRIBUTION SYSTEMS AND INDIVIDUAL SERVICE LINES ARE NOT SPECIFICALLY INDICATED ON THE DRAWINGS BUT DO EXIST ALONG THE PIPELINE ROUTES. THE CONTRACTOR SHALL EXERCISE CAUTION WHILE WORKING NEAR, OR UNDER, ALL ELECTRIC LINES.

CONTRACTORS NOTIFICATION REQUIREMENTS LAW


ATTENTION: OREGON LAW REQUIRES YOU TO FOLLOW RULES ADOPTED BY THE OREGON UTILITY NOTIFICATION CENTER. THOSE RULES ARE SET FORTH IN OAR-952-001-0090. YOU MAY OBTAIN COPIES OF THE RULES BY CALLING THE CENTER.

REFERENCE SYMBOLS

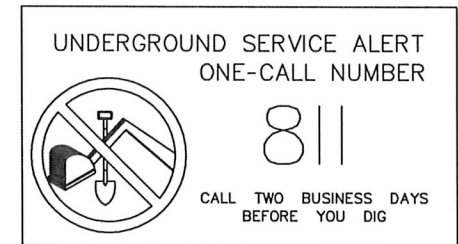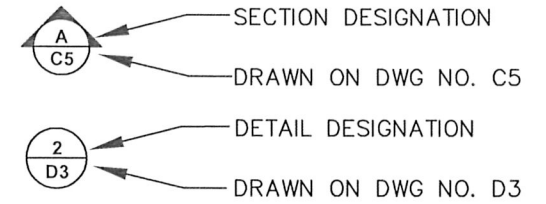


LEGEND


EXISTING

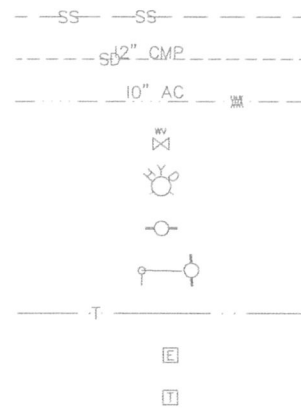

GRAVITY SEWERLINE
STORM DRAIN/ CULVERT
WATER LINE
WATER VALVE
FIRE HYDRANT
POWER POLE
POWER POLE W/GUY WIRE
UNDERGROUND TELEPHONE LINE
ELECTRICAL PEDESTAL
TELEPHONE PEDESTAL

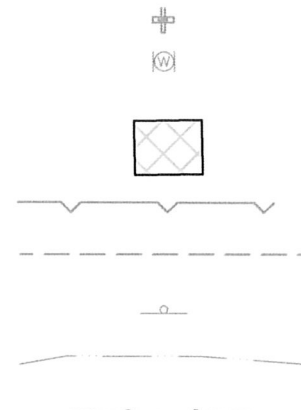

MAILBOX
WATER METER
BUILDING
EDGE A.C. PAVEMENT
EDGE OF GRAVEL
STREET SIGN
STREAM/DITCH
FENCE

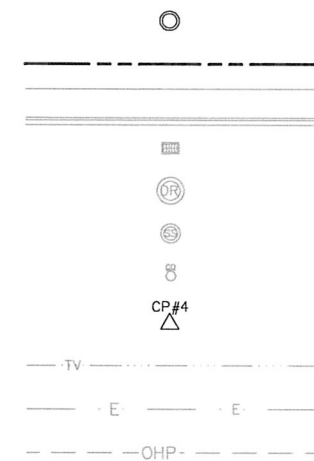

PROPERTY CORNER
PROPERTY LINE/ROW
SIDEWALK, CURB & GUTTER
CATCH BASIN
STORM DRAIN MANHOLE = DR
SANITARY SEWER MANHOLE = SS
SANITARY SEWER CLEANOUT
SURVEY CONTROL POINT
UNDERGROUND TELEVISION
UNDERGROUND ELECTRIC
OVERHEAD POWER LINE

NEW

LINES AND NOTATIONS USED TO IDENTIFY NEW CONSTRUCTION OR IMPROVEMENTS TO EXISTING FACILITIES VARY.

REFER TO SITE SPECIFIC PLAN DRAWING SHEETS FOR IDENTIFICATION OF NEW CONSTRUCTION AND/OR IMPROVEMENTS IN THAT PARTICULAR AREA.

DESIGNED:	DRAWN:	REVISIONS				
----	----	REVISED	DESCRIPTION	SUBMIT.	APPR'D.	DATE
APPROVED BY:						
DATE:						



THE DYER PARTNERSHIP
ENGINEERS & PLANNERS, INC.
1330 TEAKWOOD AVENUE
COOS BAY, OREGON 97420
TELEPHONE: (541) 269-0732
www.dyerpart.com

LINE IS 1 INCH
AT FULL SCALE
IF NOT 1-INCH - SCALE ACCORDINGLY

WASTEWATER TREATMENT PLANT IMPROVEMENTS CITY OF SUTHERLIN

GENERAL ABBREVIATIONS, GENERAL NOTES, AND LEGEND

PROJECT NO.	DRAWING NO.
146.38	G3
DATE	SHEET NO.
MAY 2016	3 OF 70



\\dver\dyer-port\AAprojects\46 Sutherlin\46.38 WWTF Pre-Design Report\dwg\PRE-DESIGN\GENERAL\G4 DESIGN DATA.dwg, 5/3/2016 10:19:28 AM PLOT DATE May 5, 2016

DESIGN DATA

DESIGN BASIS		
PARAMETER	YEAR	
	2012	2037
POPULATION	7905	12,100
WASTEWATER FLOWS, MGD		
BASE SEWAGE	0.617	0.72
BASE INFILTRATION	0.11	0.16
ADWF	0.72	0.88
AWWF	1.37	2.01
MMDWF ₁₀	1.23	1.80
MMWWF ₅	1.70	2.70
PEAK AVERAGE MONTH		
PEAK AVERAGE WEEK	2.94	4.07
PDAF ₅	5.57	7.00
PIF	7.30	8.80
WASTE WATER LOADS, LB/D		
BOD		
AVERAGE LOAD		2,154
MAXIMUM LOAD		3,222
TSS		
AVERAGE LOAD		2345
MAXIMUM LOAD		3,180
EFFLUENT QUALITY (MONTHLY AVERAGE)		
EPA RELIABILITY		
BOD ₅ (20°C)		
SUSPENDED SOLIDS		
NH ₃ -N		
TOTAL NITROGEN		
TOTAL PHOSPHOROUS		
(1) MAY 1 TO JUNE 30		
(2) JULY 1 TO OCTOBER 30		
(3) OCTOBER 16 TO OCTOBER 31		
(RIVER GAUGE ≥ 100 cfs)		
EPA		
RELIABILITY CLASS	I	

DESIGN BASIS CONTINUED					
NPDES PERMIT WASTE DISCHARGE LIMITATIONS					
JUNE 1 TO OCTOBER 31 - NO DISCHARGE OF WATERS OF THE STATE					
NOVEMBER 1 TO NOVEMBER 30 - WEEKLY AND DAILY LIMITS BASED ON STREAM FLOW IN CALAPOOYA CREEK					
PARAMETER	STREAM FLOW	AVERAGE EFFLUENT CONCENTRATIONS MONTHLY WEEKLY	MONTHLY AVERAGE LB/DAY	WEEKLY AVERAGE LB/DAY	DAILY MAXIMUM LBS
BOD ₅ ,TSS	<45 CFS	30 MG/L 45 MG/L	440	170	260
BOD ₅ ,TSS	45-60 CFS	30 MG/L 45 MG/L	440	320	480
BOD ₅ ,TSS	60-96 CFS	30 MG/L 45 MG/L	440	440	660
BOD ₅ ,TSS	>96 CFS	30 MG/L 45 MG/L	440	660	880
DECEMBER 1 TO MAY 31 - DISCHARGE IN MAY ALLOWED ONLY WHILE THE DAILY FLOW IN CALAPOOYA CREEK EXCEEDS 82 CFS					
PARAMETER		AVERAGE EFFLUENT CONCENTRATIONS MONTHLY WEEKLY	MONTHLY AVERAGE LB/DAY	WEEKLY AVERAGE LB/DAY	DAILY MAXIMUM LBS
BOD ₅		30 MG/L 45 MG/L	560	840	1,100
TSS		30 MG/L 45 MG/L	560	840	1,100
OTHER PARAMETERS (NOVEMBER-MAY)					
MINIMUM REMOVAL EFFICIENCY	85% FOR CBOD & TSS				
E. COLI BACTERIA ORGANISMS / 100ml	126 MONTHLY GEO. MEAN. NO SINGLE SAMPLE>406				
pH	6<pH<9				
AMMONIA. NITROGEN	SHALL NOT EXCEED 21 MG/L DAILY MAXIMUM AND 7.8 MG/L MONTHLY AVERAGE				
TOTAL CHLORINE RESIDUAL	SHALL NOT EXCEED 0.04 MG/L DAILY MAXIMUM AND 0.01 MG/L MONTHLY AVERAGE				

PROCESS AREA 600: INFLUENT SCREENING FACILITY		
<u>SCREENING</u>		
TYPE	SHAFTLESS SPIRAL SCREEN	
NUMBER	2	
OPENING SIZE	0.25 INCHES	
CAPACITY (EACH SCREEN)	6.0 MGD	
MOTOR HP	2.0	
NON-POTABLE WASH WATER	15 GPM @ 60 PSI (PER SCREEN)	
NON-POTABLE WATER SCREEN	250 MICRONS	
LEVEL SENSOR	ULTRA SONIC	
FREEZE PROTECTION	YES	
<u>BYPASS SCREENING</u>		
TYPE	HAND RAKED BAR SCREEN	
OPENINGS	1.0 INCH	
<u>INFLUENT SAMPLING</u>		
TYPE	TBD	
NUMBER	TBD	
<u>BYPASS SCREENING</u>		
TYPE	TBD	

PROCESS AREA 700: INFLUENT PUMP STATION	
<u>PUMP STATION</u>	
STATION TYPE	PENTAPLEX TRIPLE SUBMERSIBLE WINTER FLOW & DOUBLE SUBMERSIBLE SUMMER FLOW VARIABLE SPEED NON CLOG CENTRIFUGAL
PUMP TYPE	
DEPTH	20 FEET
SIZE	8 FEET x 14 FEET RECTANGULAR
VOLUME	2,240 CUFT
LEVEL CONTROL TYPE	PRESSURE TRANSDUCER W/ FLOAT BACKUP
OVERFLOW WET WELL ELEVATION	400.2 FEET
OVERFLOW DISCHARGE POINT	TBD
AVE. TIME TO OVERFLOW	12 MINUTES (AWWF)
AUXILIARY POWER	PLANT STANDBY GENERATOR
ALARM TELEMETRY	AUTODIALER
EPA CLASS	I
<u>WET WEATHER PUMP SYSTEM</u>	
TOTAL NUMBER OF PUMPS	3
PUMP HORSEPOWER	45 HP EACH
ONE PUMP OPERATING CAPACITY	4.2 MGD @ 43.7 FEET TDH
TWO PUMP OPERATING CAPACITY	7.76 MGD @ 47.9 FEET TDH
FIRM CAPACITY W/ 3 PUMPS	10.44 MGD @ 52.8 FEET TDH
OPERATING AVERAGE DETENTION TIME	5.2 MINUTES (AWWF)
<u>DRY WEATHER PUMP SYSTEM</u>	
TOTAL NUMBER OF PUMPS	2
PUMP HORSEPOWER	20 HP EACH
ONE PUMP OPERATING CAPACITY	1.81 MGD @ 46.2 FEET TDH
FIRM CAPACITY W/ 2 PUMPS	3.0 MGD @ 54 FEET TDH
OPERATING AVERAGE DETENTION TIME	13.9 MINUTES (ADWF)
<u>WET WEATHER FORCE MAIN</u>	
LENGTH	390 FEET
TYPE	18 INCH DI
PROFILE	CONTINUOUSLY ASCENDING
DISCHARGE	WWTP HEADWORKS
AIR RELEASE VALVES	YES
VACUUM RELEASE VALVES	YES
AVERAGE DETENTION TIME	5.0 MINUTES (AWWF)
SULFIDE CONTROL	NONE
<u>DRY WEATHER FORCE MAIN</u>	
LENGTH	390 FEET
TYPE	10 INCH DI
PROFILE	CONTINUOUSLY ASCENDING
DISCHARGE	WWTP HEADWORKS
AIR RELEASE VALVES	YES
VACUUM RELEASE VALVES	YES
AVERAGE DETENTION TIME	2.2 MINUTES (ADWF)
SULFIDE CONTROL	NONE
<u>ELEVATIONS</u>	
RIM ELEVATION	400.2 FEET
HIGH WATER LEVEL ALARM	397.0 FEET
8"Ø FM OUT I.E. (TYP. OF 2)	396.0 FEET
12"Ø FM OUT I.E. (TYP. OF 3)	396.0 FEET
27"Ø INLET I.E.	389.08
6"Ø INLET I.E. (TBD)	TBD
HWL ALARM	389.5 FEET
DRY WEATHER PUMP #1 ON	385.0 FEET
DRY WEATHER PUMP #2 ON	386.0 FEET
WET WEATHER PUMP #1 ON	387.0 FEET
WET WEATHER PUMP #2 ON	388.0 FEET
WET WEATHER PUMP #3 ON	389.0 FEET
ALL PUMPS OFF	382.0 FEET
LWL ALARM	381.5 FEET
BOTTOM OF WELL	380.0 FEET
*TWO 20-HP PUMPS SERVE AS A REDUNDANT BACKUP FOR ONE 45-HP PUMP	

PROCESS AREA 800: HEADWORKS		
<u>HAND RAKED BAR SCREEN (BYPASS)</u>		
TYPE	ONE INCH BAR SPACED SCREEN	
NUMBER	ONE	
CAPCAITY	9.0 MGD	
<u>GRIT REMOVAL</u>		
TYPE	VORTEX GRIT CONCENTRATOR	
NUMBER	ONE	
PEAK FLOW	9.0 MGD	
GRIT PUMP HP	TBD	
<u>GRIT CLASSIFIER</u>		
TYPE	SHAFTLESS CLASSIFIER	
NUMBER	ONE	
DRIVE HP	0.5 HP	
INCOMING FLOW RATE	250 GPM @ 6-8 PSI	
POUNDS PER HOUR	TBD	
<u>GRIT BASIN</u>		
VOLUME	TBD	
<u>FLOW SPLITTING TO SBR</u>		
TYPE	CONCRETE DROP BOX	
NUMBER	ONE	
OUTLET PIPE QUANTITY	FOUR	
OUTLET PIPE SIZE	12 INCH	
FLOW RANGE (PER OUTLET PIPE)	0.45 MGD TO 2.25 MGD	
<u>INFLUENT FLOW MEASUREMENT</u>		
TYPE	MAG METER	
NUMBER	FOUR	
SIZE	12 INCH	
FLOW RANGE	0.45 MGD TO 2.25 MGD	



DESIGNED:	DRAWN:	REVISIONS			
----	----	REVISED	DESCRIPTION	SUBMIT.	APPR'D.
APPROVED BY:					
DATE:					



THE DYER PARTNERSHIP
ENGINEERS & PLANNERS, INC.
1330 TEAKWOOD AVENUE
COOS BAY, OREGON 97420
TELEPHONE: (541) 269-0732
www.dyerport.com

LINE IS 1 INCH
AT FULL SCALE
IF NOT 1-INCH - SCALE ACCORDINGLY

WASTEWATER TREATMENT PLANT IMPROVEMENTS CITY OF SUTHERLIN		PROJECT NO. 146.38	DRAWING NO. G4
GENERAL DESIGN DATA		DATE MAY 2016	SHEET NO. 4 OF 70

\\dye\dyer-part\Aaprojects\146.38 WWTF Pre-Design Report\dwg\PRE-DESIGN\GENERAL\G5 DESIGN DATA CONT.dwg, 5/3/2016 10:26:49 AM PLOT DATE May 5, 2016

DESIGN DATA

PROCESS AREA 900: SEQUENCING BATCH REACTOR

SEQUENCING BATCH REACTOR

TYPE	CONTINUOUS FEED
NUMBER OF TANKS	FOUR
LENGTH	83.0 FEET EACH
WIDTH	38.0 FEET EACH
TOP WATER LEVEL	18.0 FEET EACH
BOTTOM WATER LEVEL	11.92 FEET EACH
TREATMENT CAPACITY	5.25 MGD (4.0HR NORMAL CYCLE)
TREATMENT CAPACITY	7.0 MGD (3.0HR STORM CYCLE)
FREE BOARD	2.50 FEET
FOOD TO MICROORGANISM RATIO	0.046 LBS BOD5/LB MLSS/DAY
SLUDGE VOLUME INDEX	150 ml/g
BIOSOLIDS PRODUCED	481 LBS/DAY/BASIN
NORMAL DECANT RATE	3,646 GPM
PEAK DECANT RATE	4,861 GPM
BASIN WORKING VOLUME	7,588 CUFT/BASIN
DECANTER DRAW DOWN	6.08 FEET
HYDRAULIC RETENTION TIME	0.61 DAYS

WASTE ACTIVATED SLUDGE (WAS) PUMP

WASTE SLUDGE PUMPS	CONSTANT SPEED, NON-CLOG
TYPE	CENTRIFUGAL SUBMERSIBLES
NUMBER	FOUR
HORSEPOWER	2.4
CAPACITY	110 GPM @ TBD TDH

WAS FLOWMETER

WAS FLOWMETER	1
TYPE	MAG
NUMBER	1
CAPACITY	0-250 GPM

MIXERS

TYPE	SUBMERSIBLE
NUMBER	TBD
HP	TBD

BLOWERS

TYPE	ROTARY POSITIVE DISP., VFD
NUMBER	THREE (TWO DUTY, ONE STANDBY)
CAPACITY	900 SCFM AT 8.0 PSIG
HORSEPOWER	75
DIFFUSERS	FINE BUBBLE
CONTROL	DO PROBE

DECANTER

TYPE	VARIABLE LEVEL
NUMBER	FOUR
LENGTH	30 FEET WEIR LENGTH
DECANTER DRIVE UNIT	3/4 HP
LEVEL CONTROL	PRESSURE TRANSDUCER/FLOATS

PROCESS AREA 1000: TERTIARY FILTER

TERTIARY FILTER

TYPE	ROTATING DISK FILTER
NUMBER	TWO
CAPACITY (EACH)	1.80 MGD
FILTER PERFORMANCE	>5 mg/L TSS EFFLUENT

PROCESS AREA 1100: ULTRAVIOLET DISINFECTION

ULTRAVIOLET DISINFECTION

TYPE	HORIZONTAL
NUMBER	ONE
CAPACITY	7.3 MGD
UV DOSAGE	30,000 WS/CM2
UV TRANSMITTANCE @ 254 NM	65%
EFFLUENT FECAL COLIFORM	2.2 MPN/100ml
REACTORS	1
BANKS PER REACTOR	2
LAMP RACKS PER BANK	5
LAMPS PER BANK	12
POWER CONSUMPTION	145 WATTS PER LAMP
UV INTENSITY METERS	2
LAMP CONTROL	FLOW PAGED DIMMING/SHUT OFF
ELECTRICAL	480VAC, 3 PHASE, 4 WIRE, 60 Hz
LAMP TYPE	LOW PRESSURE HIGH OUTPUT
LENGTH	64-INCHES
NUMBER:	120

HYPO CHLORIDE SYSTEM

STORAGE CAPACITY	6,100 GALS
METER PUMPS	(3) 8 GPH EACH
DOSE	2.8 mg/L

PROCESS AREA 1200: EFFLUENT DISPOSAL

OUTFALL TO CALAPOOYA CREEK

SIZE	27 INCH
LENGTH	3,200 FEET
METERING	MAGNETIC FLOW
DISCHARGE POINT	NEAR ROCHESTER BRIDGE
DISINFECTION	UV
MAXIMUM FLOW	7.0 MGD
CREEK FLOW MONITORING	OWRD STATION 14320700
MIN CREEK FLOW FOR DISCHARGE	82 CFS

IRRIGATION TANK PUMPS

TYPE	VERTICAL TURBINE, VFD
NUMBER	TWO
PUMP HP	TWO 50 HP, ONE 20HP
50 HP PUMP CAPACITY	1,200 GPM @ TBD TDH
20 HP PUMP CAPACITY	450 GPM @ TBD TDH
CONTROLS	PRESSURE TRANSDUCER W/ FLOAT
OVERFLOW DISCHARGE POINT	CALAPOOYA CREEK
AUXILIARY POWER	STANDBY DIESEL GENERATOR
ALARM TELEMETRY	SCADA

FORCE MAIN

NUMBER	1
LENGTH TO GOLF COURSE	6,250 FEET
LENGTH TO FORD'S POND	1,200 FEET
SIZE & TYPE	18 INCH DI
PROFILE	ASCENDING
DETENTION TIME	TBD
SULFIDE CONTROL	TBD

PROCESS AREA 1300: BIOSOLIDS TREATMENT

AEROBIC DIGESTER BASIN

IN/1S CAPACITY @ 13.5' SWD	95,900 GALLONS
2N/2S CAPACITY @ 13.5' SWD	191,900 GALLONS
3N/3S CAPACITY @ 13.5' SWD	95,900 GALLONS
4N/4S CAPACITY @ 13.5' SWD	139,900 GALLONS
DIGESTER FREE BOARD	2.0 FEET
BASIN IN/1S AIR REQUIREMENT	385 SCFM
BASIN 2N/2S AIR REQUIREMENT	770 SCFM
BASIN 3N/3S AIR REQUIREMENT	385 SCFM
BASIN 4N/4S AIR REQUIREMENT	561 SCFM
DECANTER TYPE	4 INCH TELESCOPING

BIOSOLIDS TRANSFER BASIN

BASIN VOLUME	37,310 GALLON
PUMP TYPE	SUBMERSIBLE NON-CLOG
NUMBER OF PUMPS	FOUR
TRANSFER PUMP CAPACITY	288 GPM @ 24.8 FEET TDH
TRANSFER PUMP HP	5
CONTROLS	PRESSURE TRANSDUCER W/ FLOAT
OVERFLOW DISCHARGE POINT	CALAPOOYA CREEK
AUXILIARY POWER	STANDBY DIESEL GENERATOR
ALARM TELEMETRY	SCADA

BIOSOLIDS BLOWERS

BLOWER TYPE	ROTARY POSITIVE DISPLACEMENT
SPEED	VARIABLE
NUMBER	FOUR
DECIBELS OUTSIDE OF ENCLOSURE	80 dB
INTERIOR DIGESTER BASIN POWER	3 @ 20 HP
INTERIOR DIGESTER	457 SCFM @ 4.9 PSI
EXTERIOR DIGESTER BASIN POWER	3 @ 50 HP
EXTERIOR DIGESTER	1,565 SCFM @ 5.0 PSI

BIOSOLIDS DEWATERING PRESS FEED PUMPS

PUMP TYPE	ROTARY LOBE
NUMBER OF PUMPS	TWO
CAPACITY BIOSOLIDS	150 GPM @ 25 FEET TDH
TRANSFER PUMP	
BIOSOLIDS TRANSFER PUMP HP	TBD

SCREW PRESS

TYPE	SCREW PRESS
NUMBER	ONE
CAPACITY	55 GPM @ 2% SOLIDS
SCREW PRESS MOTOR	5 HP
CAKE SOLIDS CONTENT	12% - 16%
SIZE	550 LBD/DAY (6.6 TONS/DAY)
POLYMER FEED CAPACITY	TBD
POLYMER FEED HP	TBD

PROCESS AREA 1400: EVERETT AVE. PUMP STATION

PUMP STATION

STATION TYPE	TRIPLEX SUBMERSIBLE
PUMP TYPE	NON CLOG CENTRIFUGAL, VFD
PUMP STATION FLOW 2037 ADWF	368 GPM
PUMP STATION FLOW 2037 AWWF	698 GPM
PUMP STATION FLOW 2037 PDAF	2,430 GPM
PUMP STATION FLOW 2037 PIF	3,055 GPM
TOTAL NUMBER OF PUMPS	3
ONE PUMP OPERATING CAPACITY	1,925 GPM @ 68 FEET TDH
TWO PUMP OPERATING CAPACITY	2,500 MGD @ 98 FEET TDH
PUMP HP	60 HP EACH
LEVEL CONTROL TYPE	PRESSURE TRANSDUCER W/ FLOAT BACKUP
OVERFLOW MANHOLE, ELEVATION	VALLEY COURT MH, 512 FEET
OVERFLOW DISCHARGE POINT	SUTHERLIN CREEK
AVE. TIME TO OVERFLOW	36 MIN. @ 2012 ADWF
AVE. TIME TO OVERFLOW	19 MIN. @ 2012 AWWF
AVE. TIME TO OVERFLOW	24 MIN. @ 2037 ADWF
AVE. TIME TO OVERFLOW	13 MIN. @ 2037 AWWF

AUXILIARY POWER

TYPE	STANDBY GENERATOR
OUTPUT	125 KW
FUEL	NATURAL GAS
ALARM TELEMETRY	SCADA
EPA CLASS	1

EXISTING FORCE MAIN

LENGTH	920 FEET
TYPE	10 INCH CAST IRON
PROFILE	CONTINUOUSLY ASCENDING
DISCHARGE	MH#M5, OAK ST.
AIR RELEASE VALVES	NONE
VACUUM RELEASE VALVES	NONE
AVERAGE DETENTION TIME	15.0 MIN. @ 2012 ADWF
AVERAGE DETENTION TIME	10.2 MIN. @ 2037 ADWF
SULFIDE CONTROL	NONE

PROPOSED FORCE MAIN

LENGTH	750 FEET EXISTING 10 INCH, 2,750 NEW 12 INCH
TYPE	EXIST. 10 IN. C.I., NEW 12 IN. D.I.
PROFILE	ASCENDING TO A HIGH POINT NEAR PINE ST. (522.03'), THEN DESCENDING TO A LOW POINT NEAR ASH ST. (517.39'), THEN ASCENDING TO A SECOND HIGH POINT AT MILLER ST. (525.14'), AND THEN DESCENDING DOWN MILLER ST. TO MANHOLE L5 (515.0').
DISCHARGE	MH#L5, MILLER ST.
AIR RELEASE VALVES	YES
VACUUM RELEASE VALVES	YES
AVERAGE DETENTION TIME	76.8 MIN. @ 2012 ADWF
AVERAGE DETENTION TIME	52.2 MIN. @ 2037 ADWF
AVERAGE PUMP CYCLE TIME	70.3 MIN @ 2012 ADWF
SULFIDE CONTROL	TBD

ELEVATIONS

TOP OF WETWELL	516.0 FEET
OVERFLOW ALARM	511.5 FEET
10"Ø FM OUT I.E.	512.0 FEET
GRAVITY SEWER	501.92 FEET
HWL ALARM	501.7 FEET
LAG PUMP ON	500.9 FEET
LEAD PUMP ON	499.9 FEET
ALL PUMPS OFF	496.9 FEET
LWL ALARM	496.4 FEET
BOTTOM OF WELL	495.0 FEET



DESIGNED:	DRAWN:	REVISIONS			
----	----	REVISED	DESCRIPTION	SUBMIT.	APPR'D.
APPROVED BY:	DATE:				



THE DYER PARTNERSHIP
ENGINEERS & PLANNERS, INC.
1330 TEAKWOOD AVENUE
COOS BAY, OREGON 97420
TELEPHONE: (541) 269-0732
www.dyerpart.com

LINE IS 1 INCH
AT FULL SCALE
IF NOT 1-INCH - SCALE ACCORDINGLY


WASTEWATER TREATMENT PLANT IMPROVEMENTS CITY OF SUTHERLIN

GENERAL DESIGN DATA CONT.

PROJECT NO.	DRAWING NO.
146.38	G5
DATE	SHEET NO.
MAY 2016	5 OF 70

PLOT DATE May 5, 2016

\\dye\dyer-part\A\projects\46 Sutherlin\46.38 WWTF Pre-Design Report\dwg\PRE-DESIGN\GENERAL\HYDRAULIC PROFILE.dwg, 5/3/2016 11:05:21 AM

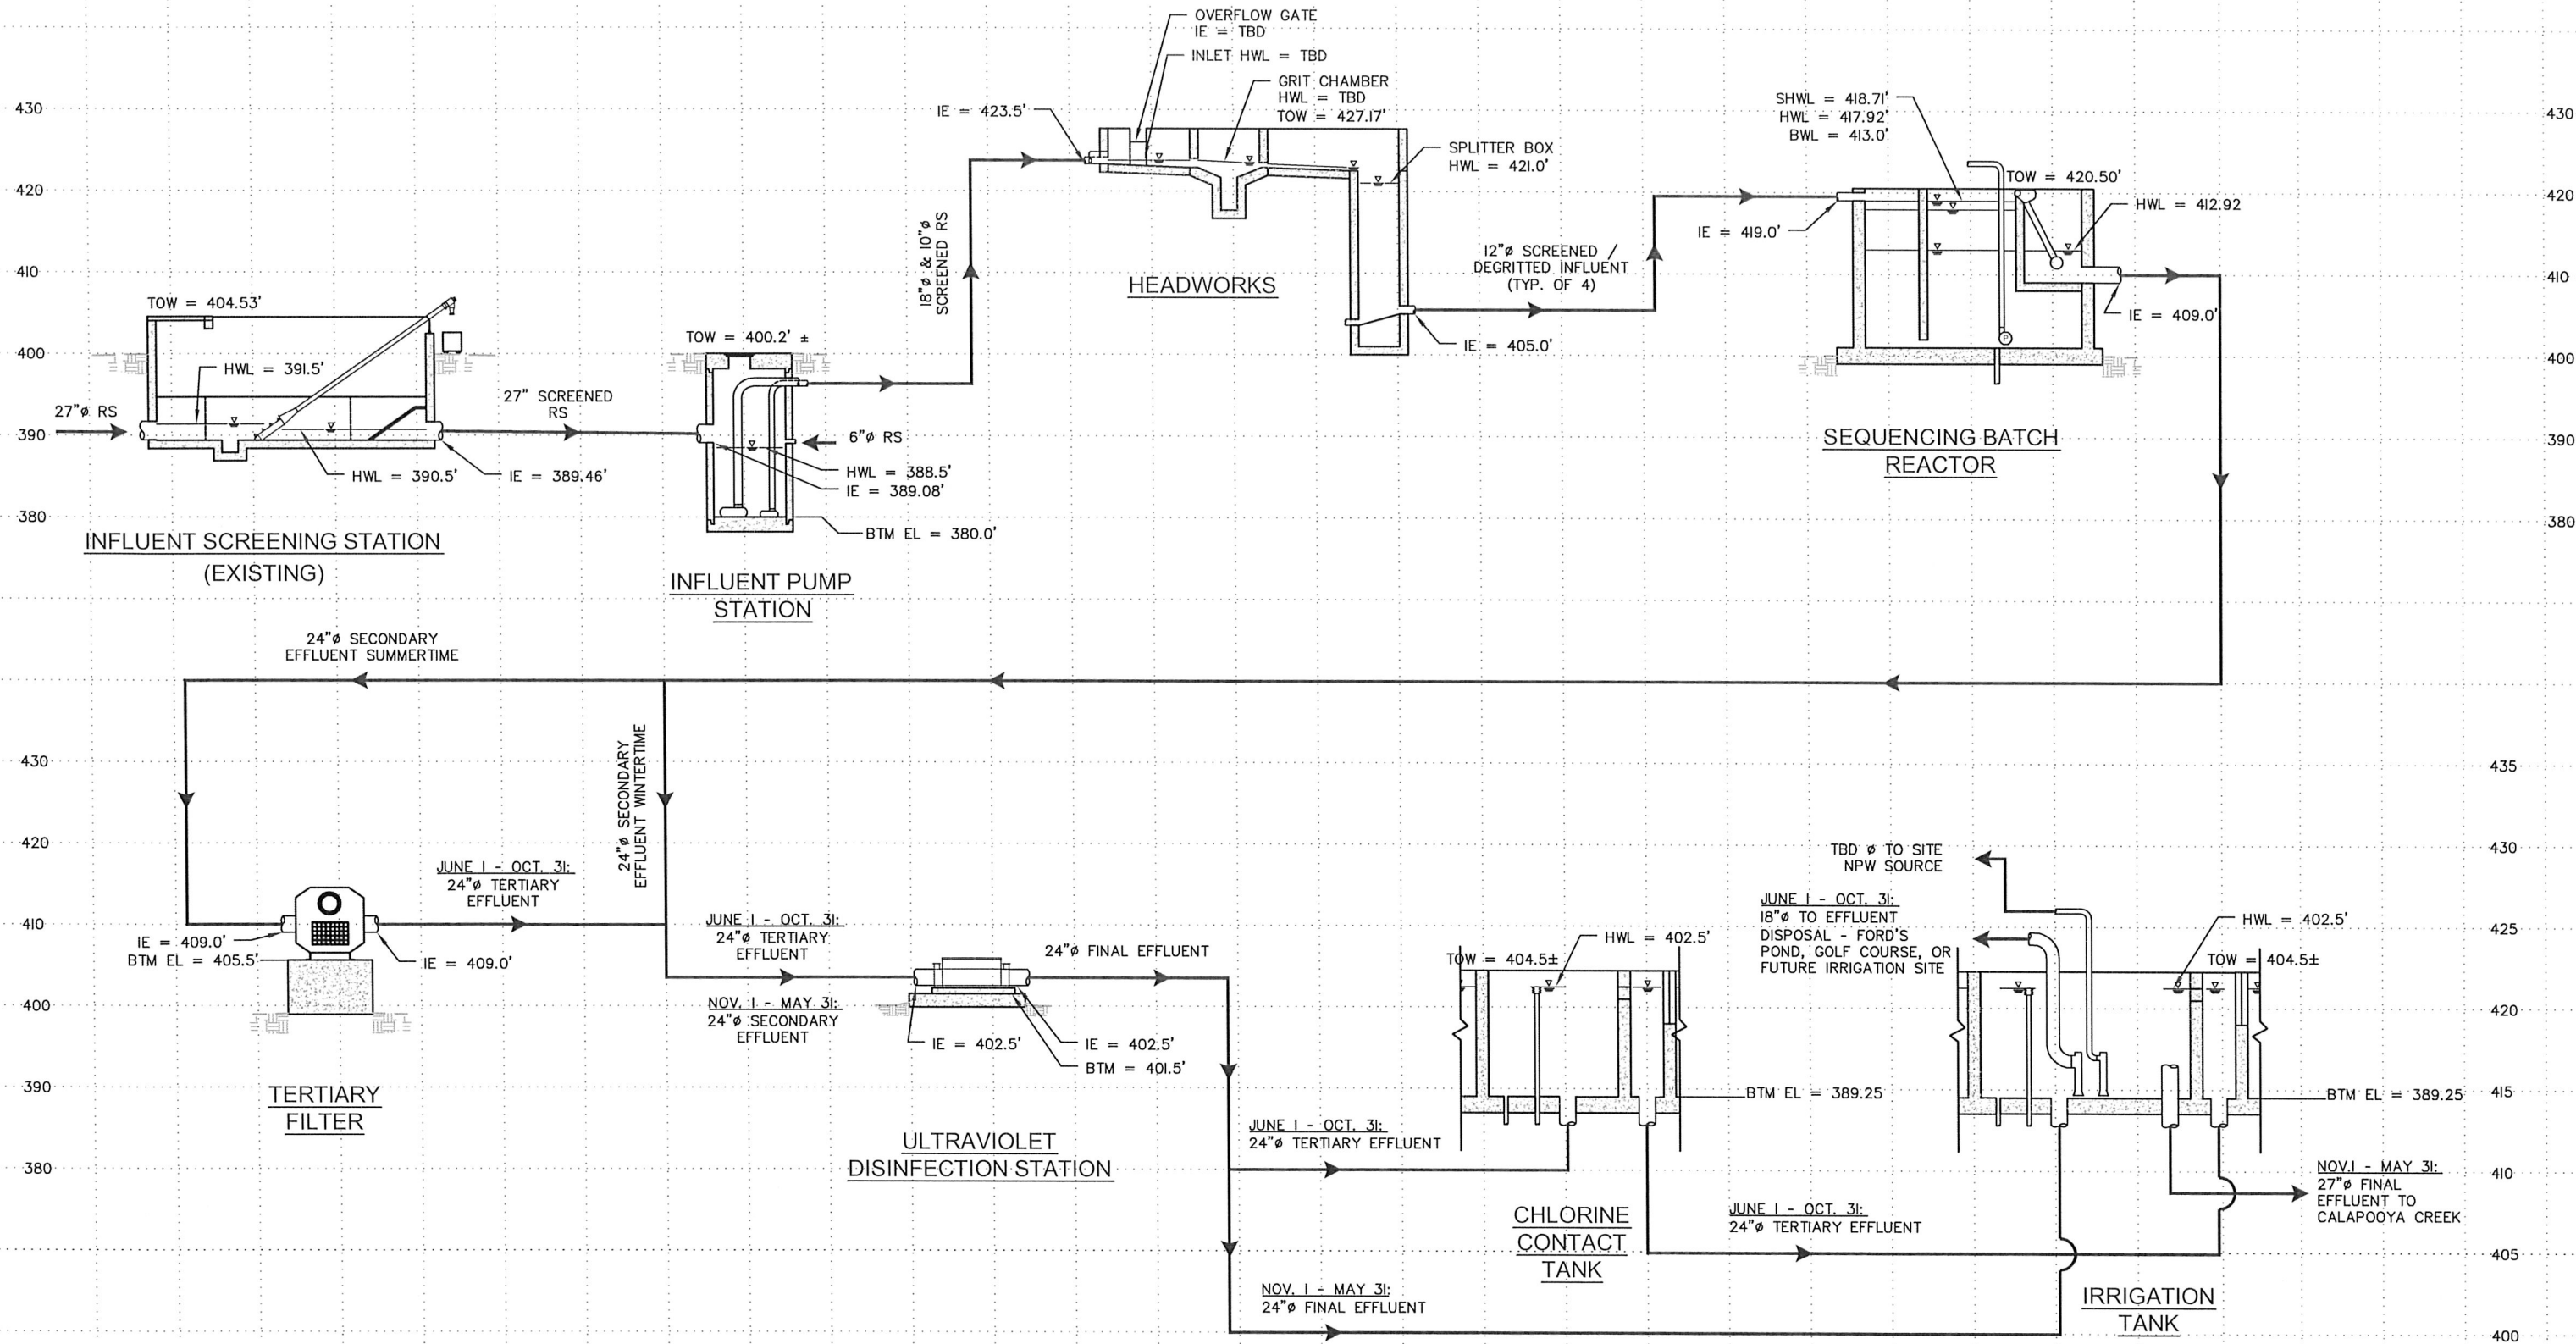

NOTE: FACILITIES LOCATED OUTSIDE 100YR FLOOD PLAIN.

DESIGNED:	DRAWN:
---	---
APPROVED BY:	
DATE:	

REVISIONS				
REVISED	DESCRIPTION	SUBMIT.	APPR'D.	DATE



THE DYER PARTNERSHIP
ENGINEERS & PLANNERS, INC.
1330 TEAKWOOD AVENUE
COOS BAY, OREGON 97420
TELEPHONE: (541) 269-0732
www.dyerpart.com

LINE IS 1 INCH
AT FULL SCALE
IF NOT 1-INCH - SCALE ACCORDINGLY

WASTEWATER TREATMENT PLANT IMPROVEMENTS
CITY OF SUTHERLIN


GENERAL
OVERALL HYDRAULIC PROFILE- LIQUID STREAM

PROJECT NO.	DRAWING NO.
146.38	G6
DATE	SHEET NO.
MAY 2016	6 OF 70


PLOT DATE May 5, 2016

\\dye\dyer-part\AAprojects\146 Sutherlin\46.38 WWTF Pre-Design Report\dwg\PRE-DESIGN GENERAL HYDRAULIC PROFILE.dwg, 5/3/2016 11:05:21 AM


INFLUENT SCREENING STATION (EXISTING)

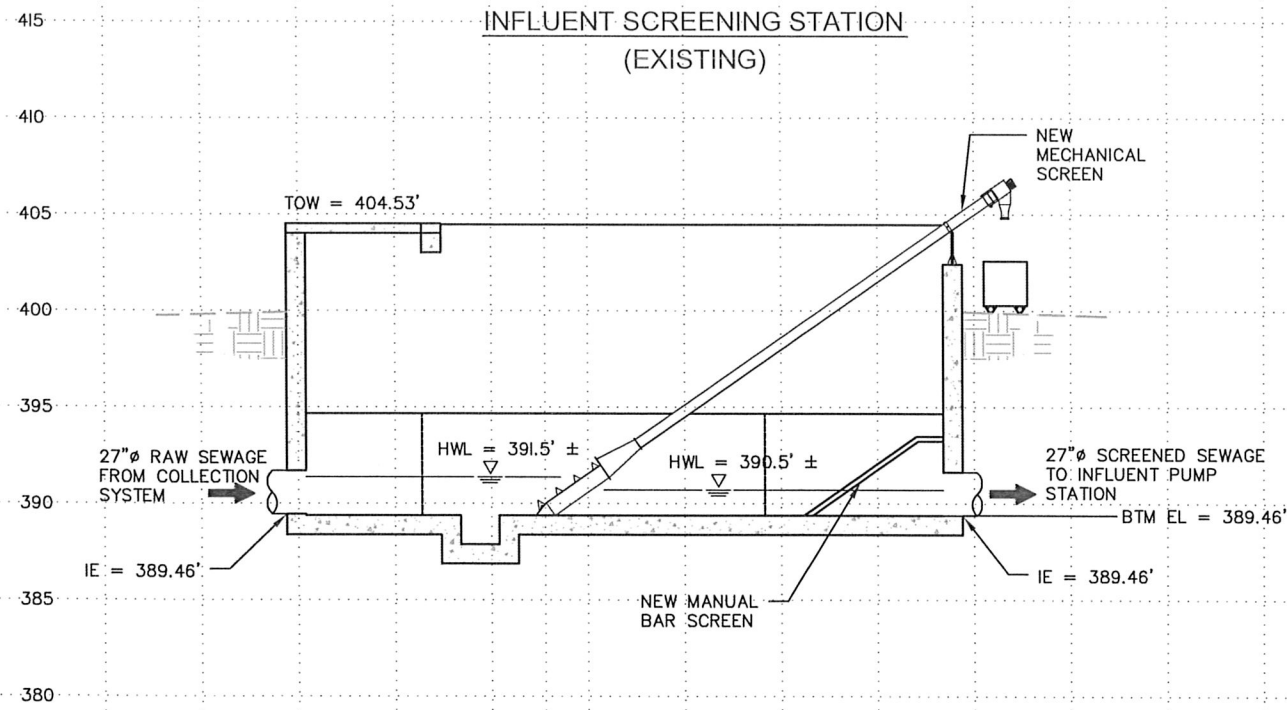


INFLUENT MAN HOLE (EXISTING)

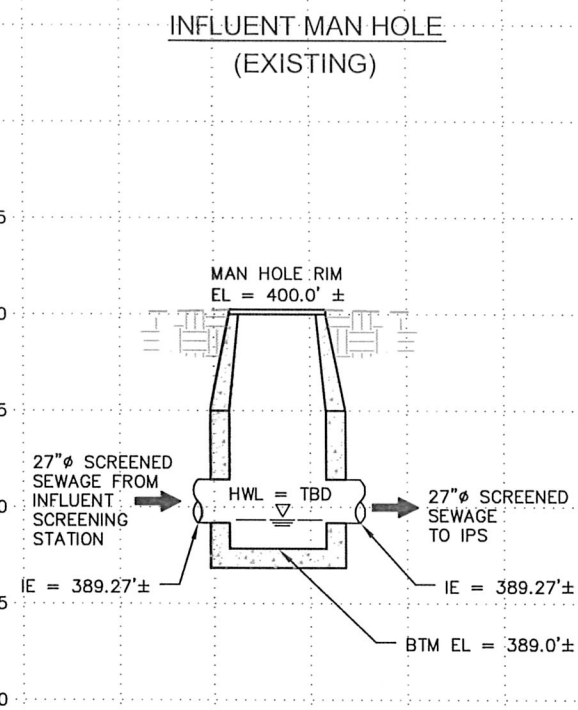


INFLUENT PUMP STATION

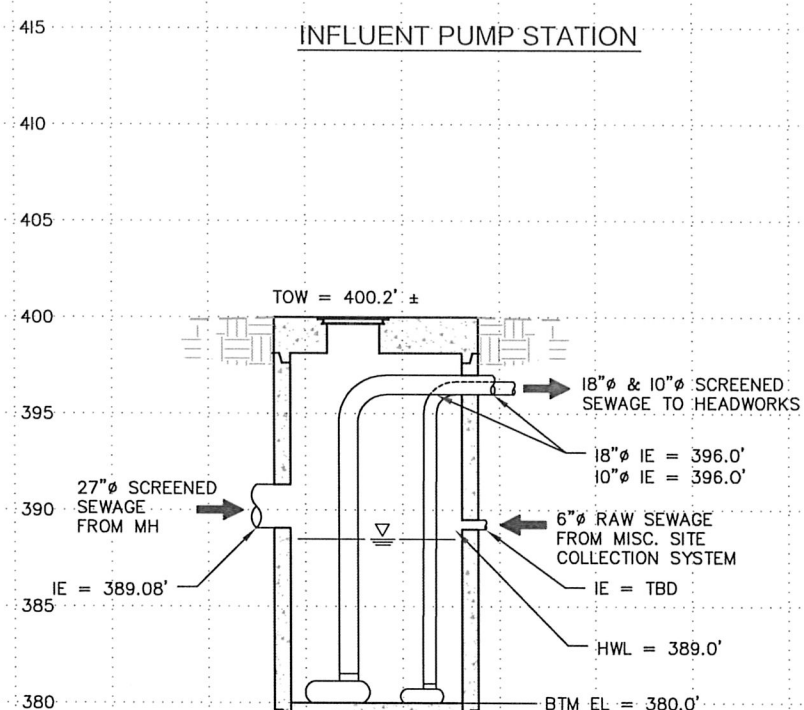

HEADWORKS

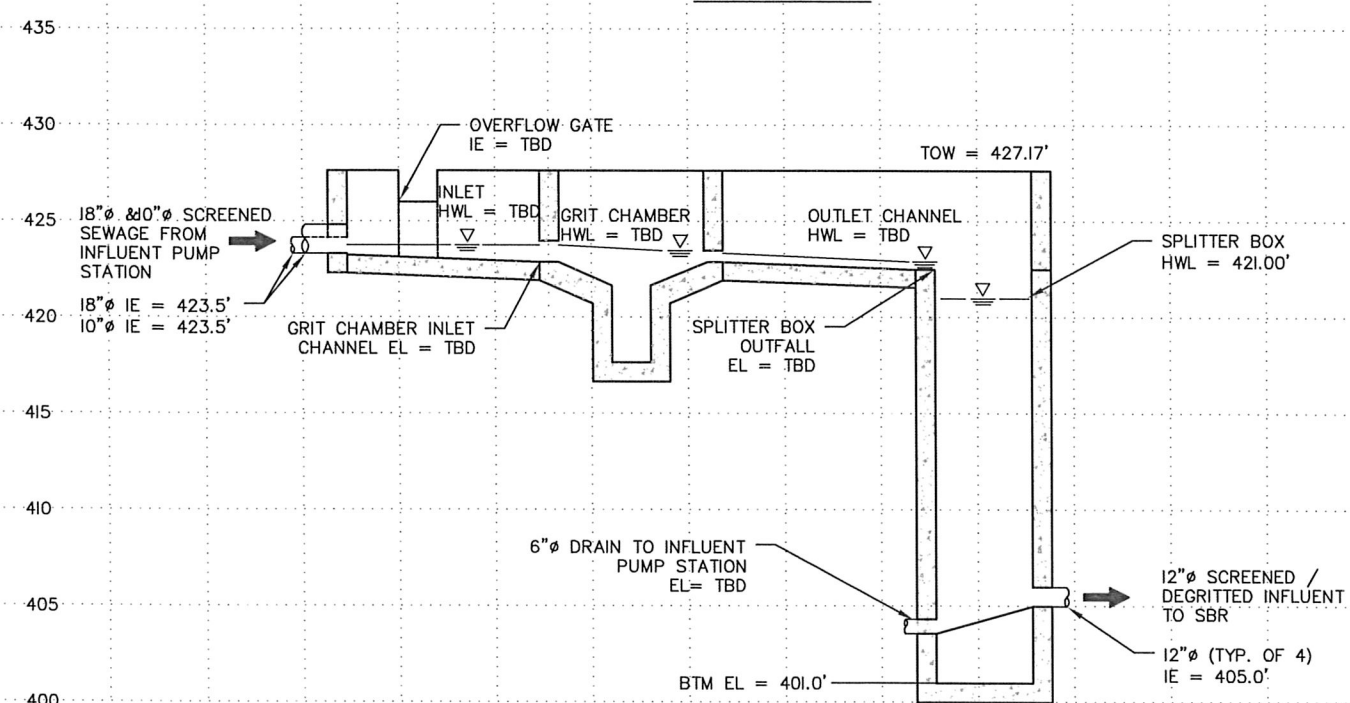

SEQUENCING BATCH REACTOR

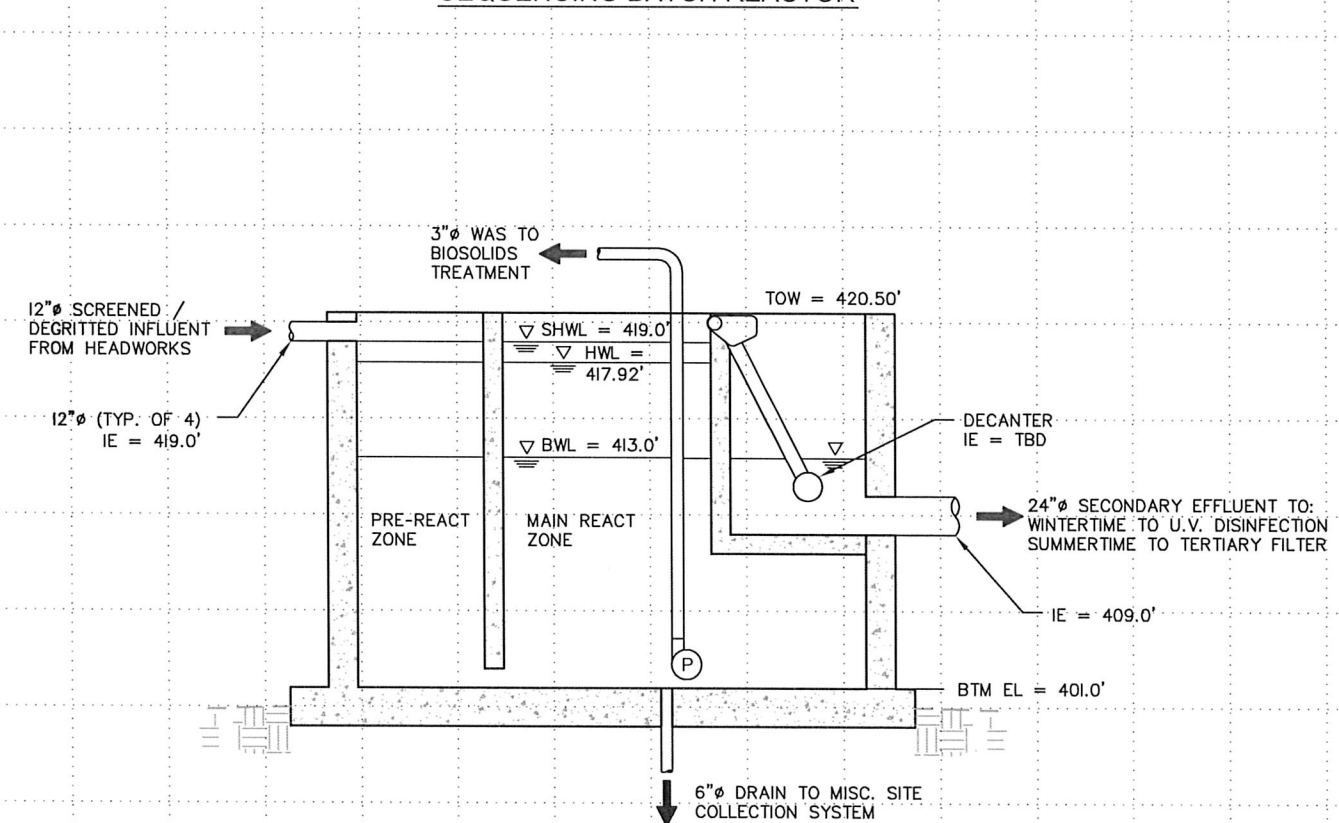

DESIGNED:	DRAWN:	REVISIONS			
---	---	REVISED	DESCRIPTION	SUBMIT.	APPR'D.
APPROVED BY:					
DATE:					


**THE DYER PARTNERSHIP
ENGINEERS & PLANNERS, INC.**
1330 TEAKWOOD AVENUE
COOS BAY, OREGON 97420
TELEPHONE: (541) 269-0732
www.dyerpart.com

LINE IS 1 INCH
AT FULL SCALE
IF NOT 1-INCH - SCALE ACCORDINGLY

WASTEWATER TREATMENT PLANT IMPROVEMENTS CITY OF SUTHERLIN

GENERAL HYDRAULIC PROFILE





PROJECT NO.	DRAWING NO.
146.38	G7
DATE	SHEET NO.
MAY 2016	7 OF 70

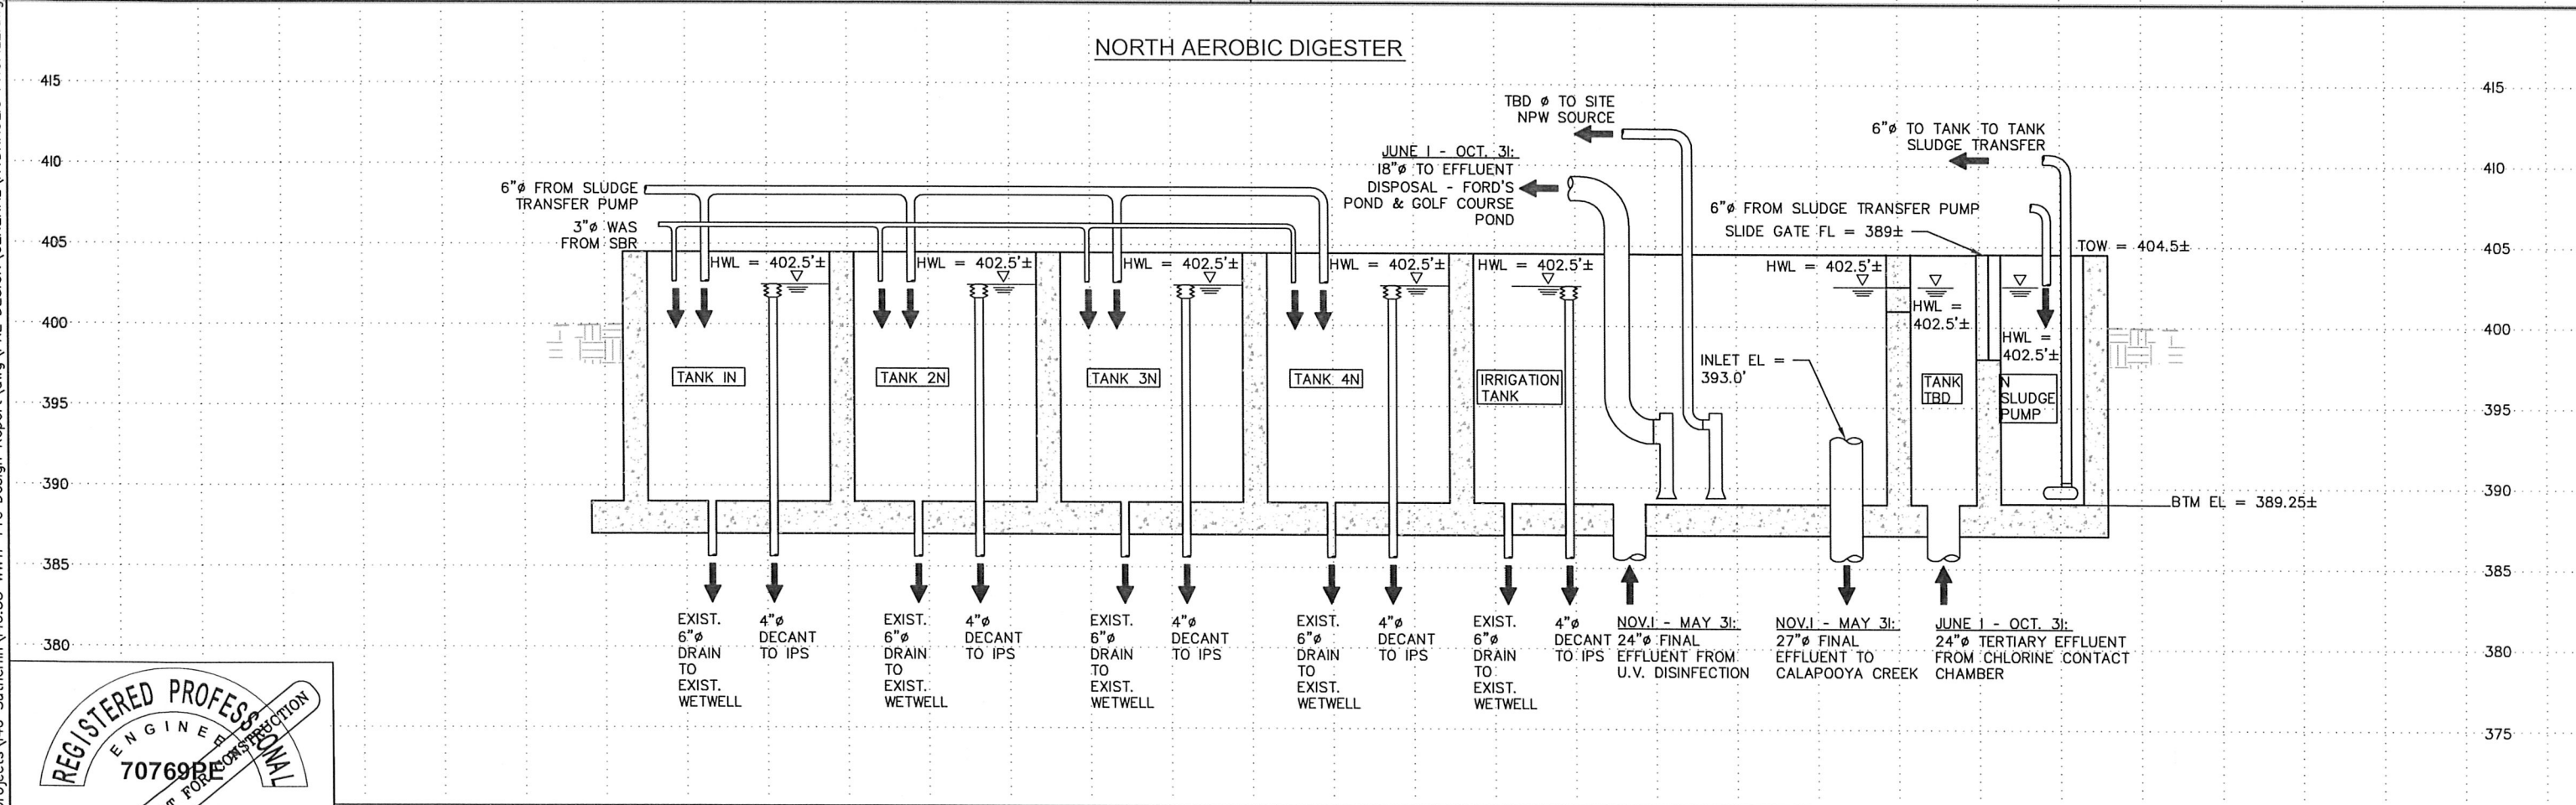

DESIGNED: _____	DRAWN: _____	REVISIONS					 THE DYER PARTNERSHIP ENGINEERS & PLANNERS, INC. 1330 TEAKWOOD AVENUE COOS BAY, OREGON 97420 TELEPHONE: (541) 269-0732 www.dyerpart.com	WASTEWATER TREATMENT PLANT IMPROVEMENTS CITY OF SUTHERLIN		PROJECT NO.	DRAWING NO.
		REVISED	DESCRIPTION	SUBMIT.	APPR'D.	DATE				146.38	G8
APPROVED BY: _____ DATE: _____							 LINE IS 1 INCH AT FULL SCALE IF NOT 1-INCH - SCALE ACCORDINGLY	GENERAL HYDRAULIC PROFILE		DATE	SHEET NO.
										MAY 2016	8 OF 70

May 5, 2016

\\dye\dyer-part\AAprojects\146 Sutherlin\146.38 WWTF Pre-Design Report\dwg\PRE-DESIGN\GENERAL\HYDRAULIC PROFILE.dwg, 5/3/2016 11:05:21 AM

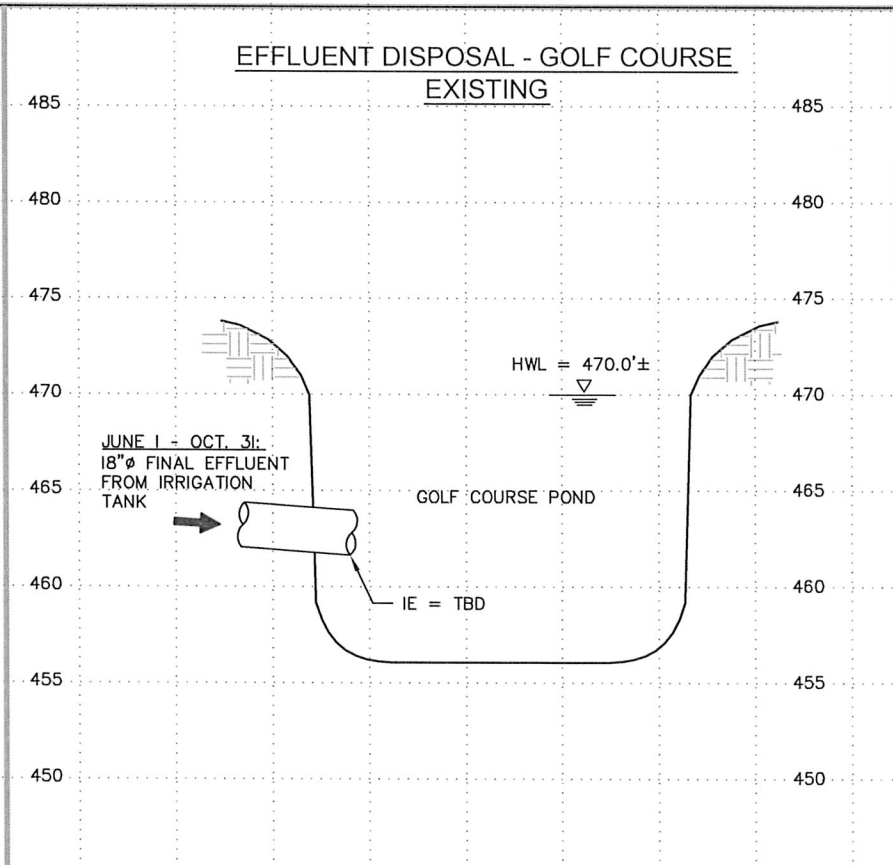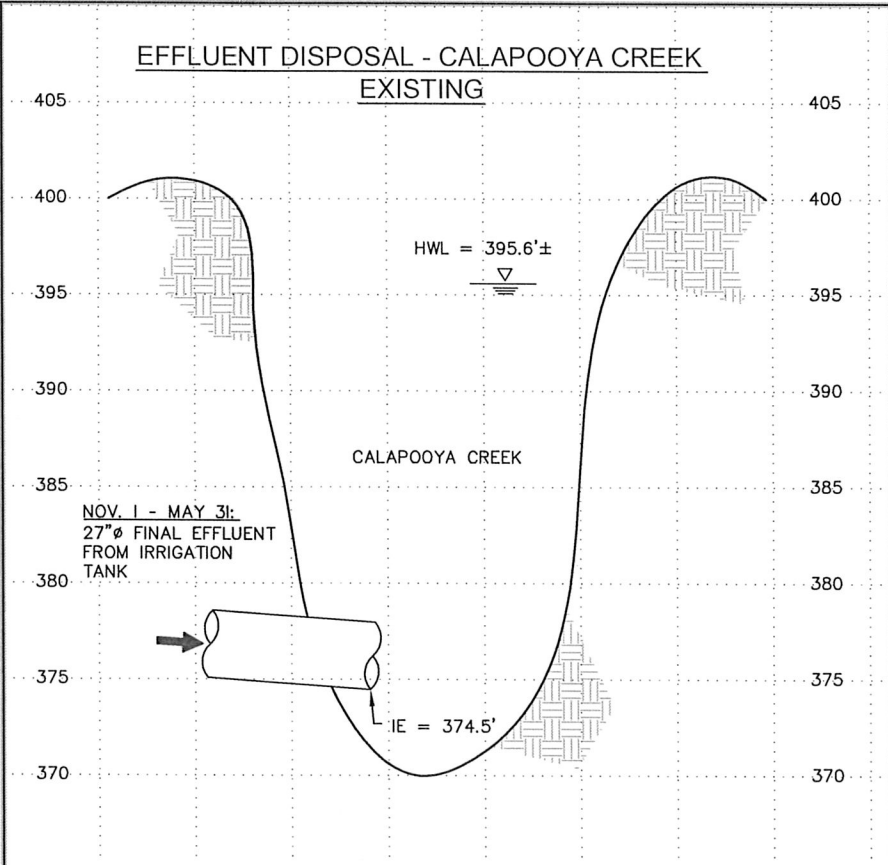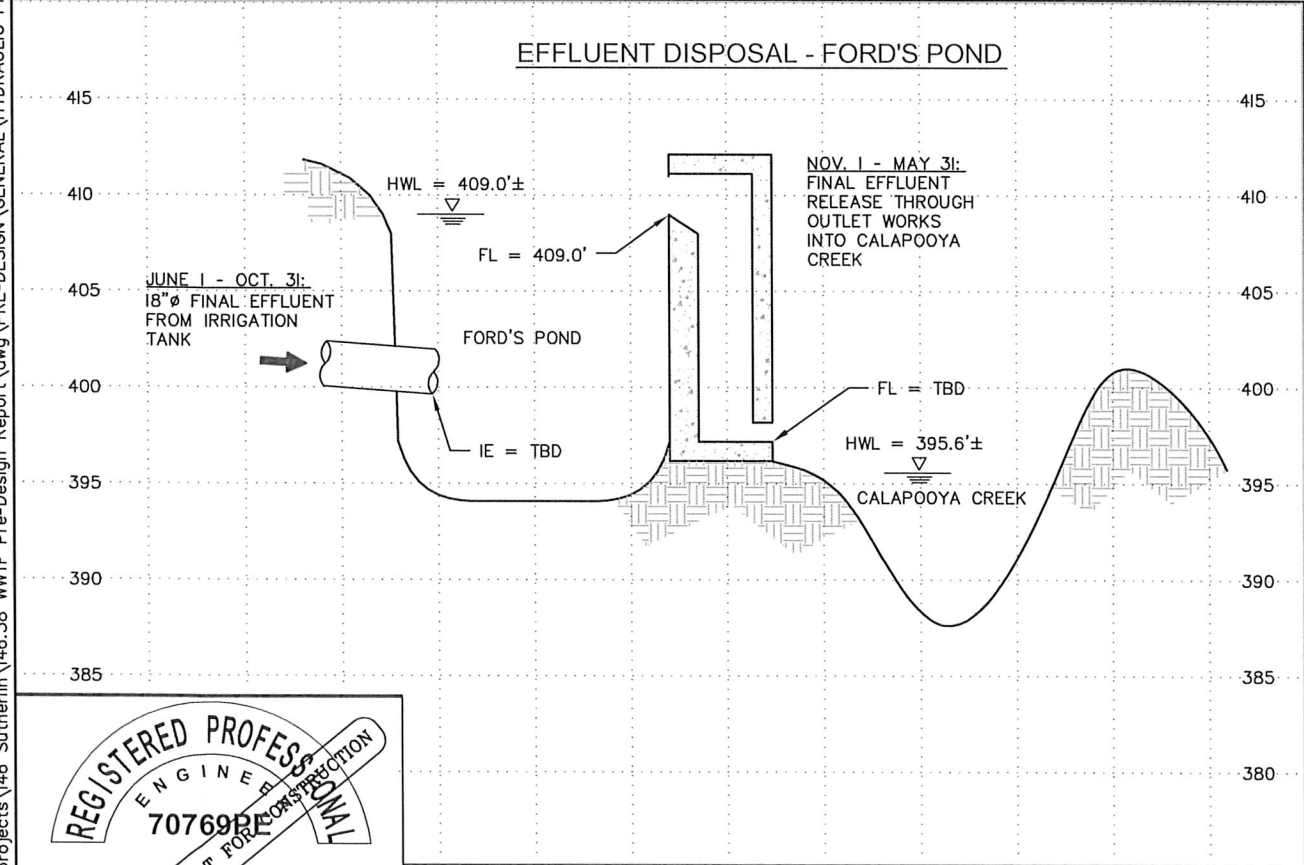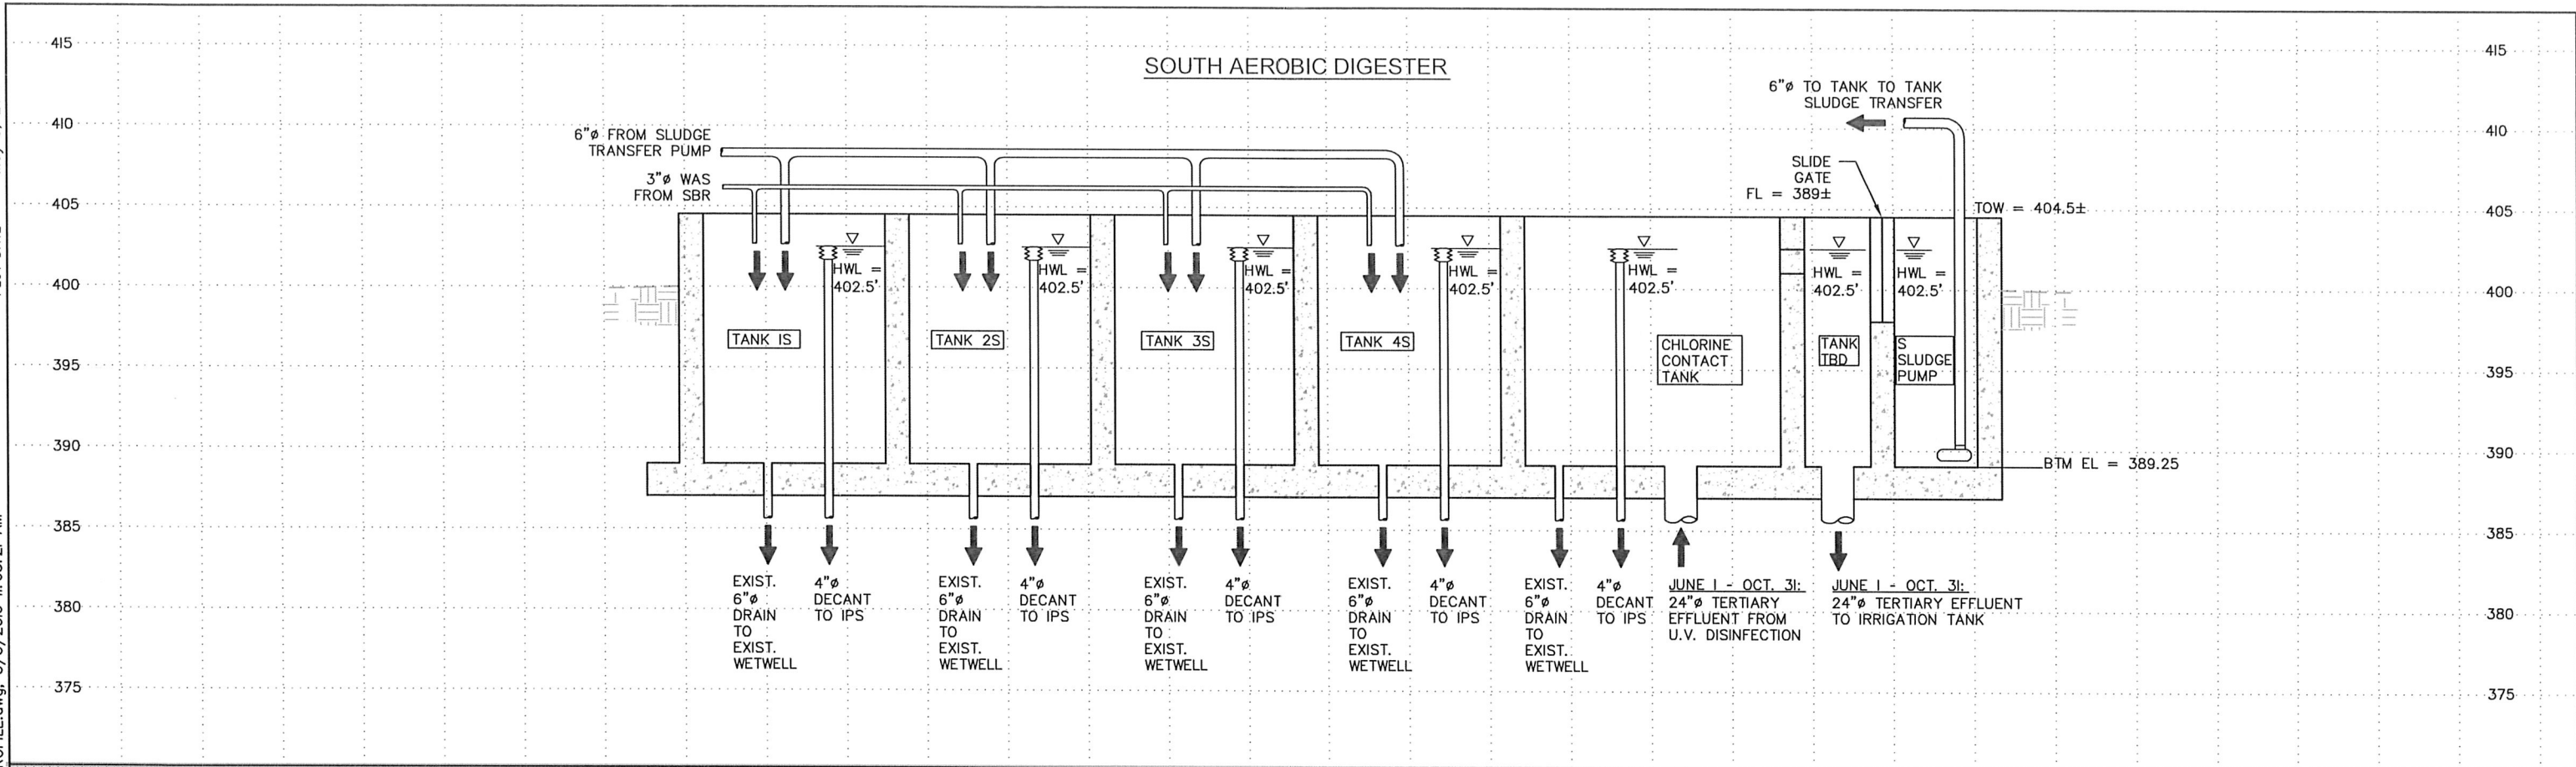

DESIGNED:	DRAWN:	REVISIONS			
---	---	REVISED	DESCRIPTION	SUBMIT.	APPR'D.
APPROVED BY:					
DATE:					



THE DYER PARTNERSHIP
ENGINEERS & PLANNERS, INC.
1330 TEAKWOOD AVENUE
COOS BAY, OREGON 97420
TELEPHONE: (541) 269-0732
www.dyerpart.com

LINE IS 1 INCH
AT FULL SCALE
IF NOT 1-INCH - SCALE ACCORDINGLY

**WASTEWATER TREATMENT PLANT IMPROVEMENTS
CITY OF SUTHERLIN**

**GENERAL
HYDRAULIC PROFILE**

PROJECT NO.	DRAWING NO.
146.38	G9
DATE	SHEET NO.
MAY 2016	9 OF 70

MECHANICAL EQUIPMENT SYMBOLS



BLOWER OR COMPRESSOR, ROTARY LOBE



COMPRESSOR, PISTON



AIR BUBBLE DIFFUSER



SILENCER



FILTER OR FILTER-SILENCER, INLET AIR



 
RECEIVER OR PRESSURE VESSEL



REDUCED PRESSURE BACKFLOW PREVENTER



UTILITY STATION/HOSEBIB




DECANT ARM



GENERATOR



 MIXER



MECHANICAL SCREEN



SCREENING CONTAINER

PUMP SYMBOLS



 
PUMP, CENTRIFUGAL



PUMP, ROTARY LOBE POSITIVE DISPLACEMENT



PUMP, SUBMERSIBLE



PUMP, VERTICAL TURBINE



METERING PUMP



MOTOR

VALVE SYMBOLS



THREE WAY VALVE



AIR RELIEF VALVE



GATE VALVE (NORMALLY OPEN)



GATE VALVE (NORMALLY CLOSED)



PLUG VALVE (NORMALLY OPEN)



PLUG VALVE (NORMALLY CLOSED)



BALL VALVE (NORMALLY OPEN)



BALL VALVE (NORMALLY CLOSED)



BUTTERFLY VALVE



GLOBE VALVE (NORMALLY OPEN)



GLOBE VALVE (NORMALLY CLOSED)



DIAPHRAGM VALVE



NEEDLE VALVE



DOUBLE LEAF CHECK VALVE



CHECK VALVE



BALL CHECK VALVE



MUD VALVE



SOLENOID



MOTOR ACTUATOR



TELESCOPING VALVE

GATE SYMBOLS



SLIDE GATE (NORMALLY CLOSED)



SLIDE GATE (NORMALLY OPEN)



SLUICE GATE, CANAL GATE (NORMALLY CLOSED)



SLUICE GATE, CANAL GATE (NORMALLY OPEN)

PIPING LEGEND



A AERATION AIR



BW BACKWASH WATER



CL CHLORINE



D DRAIN



DB DIGESTED BIOSOLIDS



FE FINAL EFFLUENT



FM FILTER MEDIA



G GRIT SLURRY



NPW NON-POTABLE WATER



OF OVERFLOW



POL POLYMER



PST PRESSATE



RS RAW SEWAGE



RW REUSE WATER



SS SANITARY SEWER



SE SECONDARY EFFLUENT



SA SERVICE AIR



STD STORM DRAIN



SN SUPERNATANT



TD TANK DRAIN



TE TERTIARY EFFLUENT



V VENT



W CITY WATER (POTABLE)



WAS WASTE ACTIVATED SLUDGE

MEASUREMENT AND CONTROL SYMBOLS

FLOW (LIQUID, GAS)



GENERAL FLOW METER



AIR FLOW METER

LEVEL



ULTRASONIC



FLOAT



STAFF GAUGE

PRESSURE



GAUGE WITH DIAPHRAGM CHEMICAL SEAL



VACUUM INDICATOR



PRESSURE SENSOR

TEMPERATURE



TS TEMPERATURE SENSOR



MS MOISTURE SENSOR

ANALYZER



CI CHLORINE RESIDUAL



TB TURBIDITY




DO DISSOLVED OXYGEN




TSS TOTAL SUSPENDED SOLIDS

GENERAL SYMBOLISM

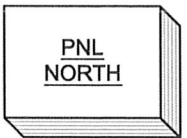

INSTRUMENT OR ELECTRICAL PANEL (PNL)

 

FLUME



 
WEIR



AUTOMATIC SAMPLER



WASHDOWN STATION



XXX-NNNN

EQUIPMENT IDENTIFICATION



XXX NNNN

INSTRUMENT IDENTIFICATION



VFD

 
VARIABLE FREQUENCY DRIVE




AIR BLOWOFF



PROPELLER/TURBINE METER



A AIR FLOW SWITCH

 

P PRESSURE SWITCH



DIAPHRAGM CHEMICAL SEAL

PROCESS LINES



PRIMARY PROCESS FLOW



SECONDARY PROCESS FLOW



EXISTING



VENDOR PACKAGE BOUNDARY



ENCLOSURE BOUNDARY



ELECTRICAL SIGNAL

CROSS REFERENCE SYSTEM

ON DRAWING P101 CONTINUATION IS SHOWN AS:




ON DRAWING P102 THIS CONTINUATION IS SHOWN AS:



SYSTEM NOT DESCRIBED BY PROCESS AND INSTRUMENTATION DRAWING:



 CONTINUATION SHOWING DATA INTERCHANGE:



DESIGNED: _____
DATE: _____

DRAWN: _____
DATE: _____

APPROVED BY: _____
DATE: _____

REVISIONS				
REVISED	DESCRIPTION	SUBMIT.	APPR'D.	DATE



THE DYER PARTNERSHIP
ENGINEERS & PLANNERS, INC.
1330 TEAKWOOD AVENUE
COOS BAY, OREGON 97420
TELEPHONE: (541) 269-0732
www.dyerpart.com

LINE IS 1 INCH
AT FULL SCALE
IF NOT 1-INCH - SCALE ACCORDINGLY

WASTEWATER TREATMENT PLANT IMPROVEMENTS
CITY OF SUTHERLIN


PROCESS
STANDARD SYMBOLS

PROJECT NO.
146.38

DRAWING NO.
P1

DATE
MAY 2016

SHEET NO.
10 OF 70

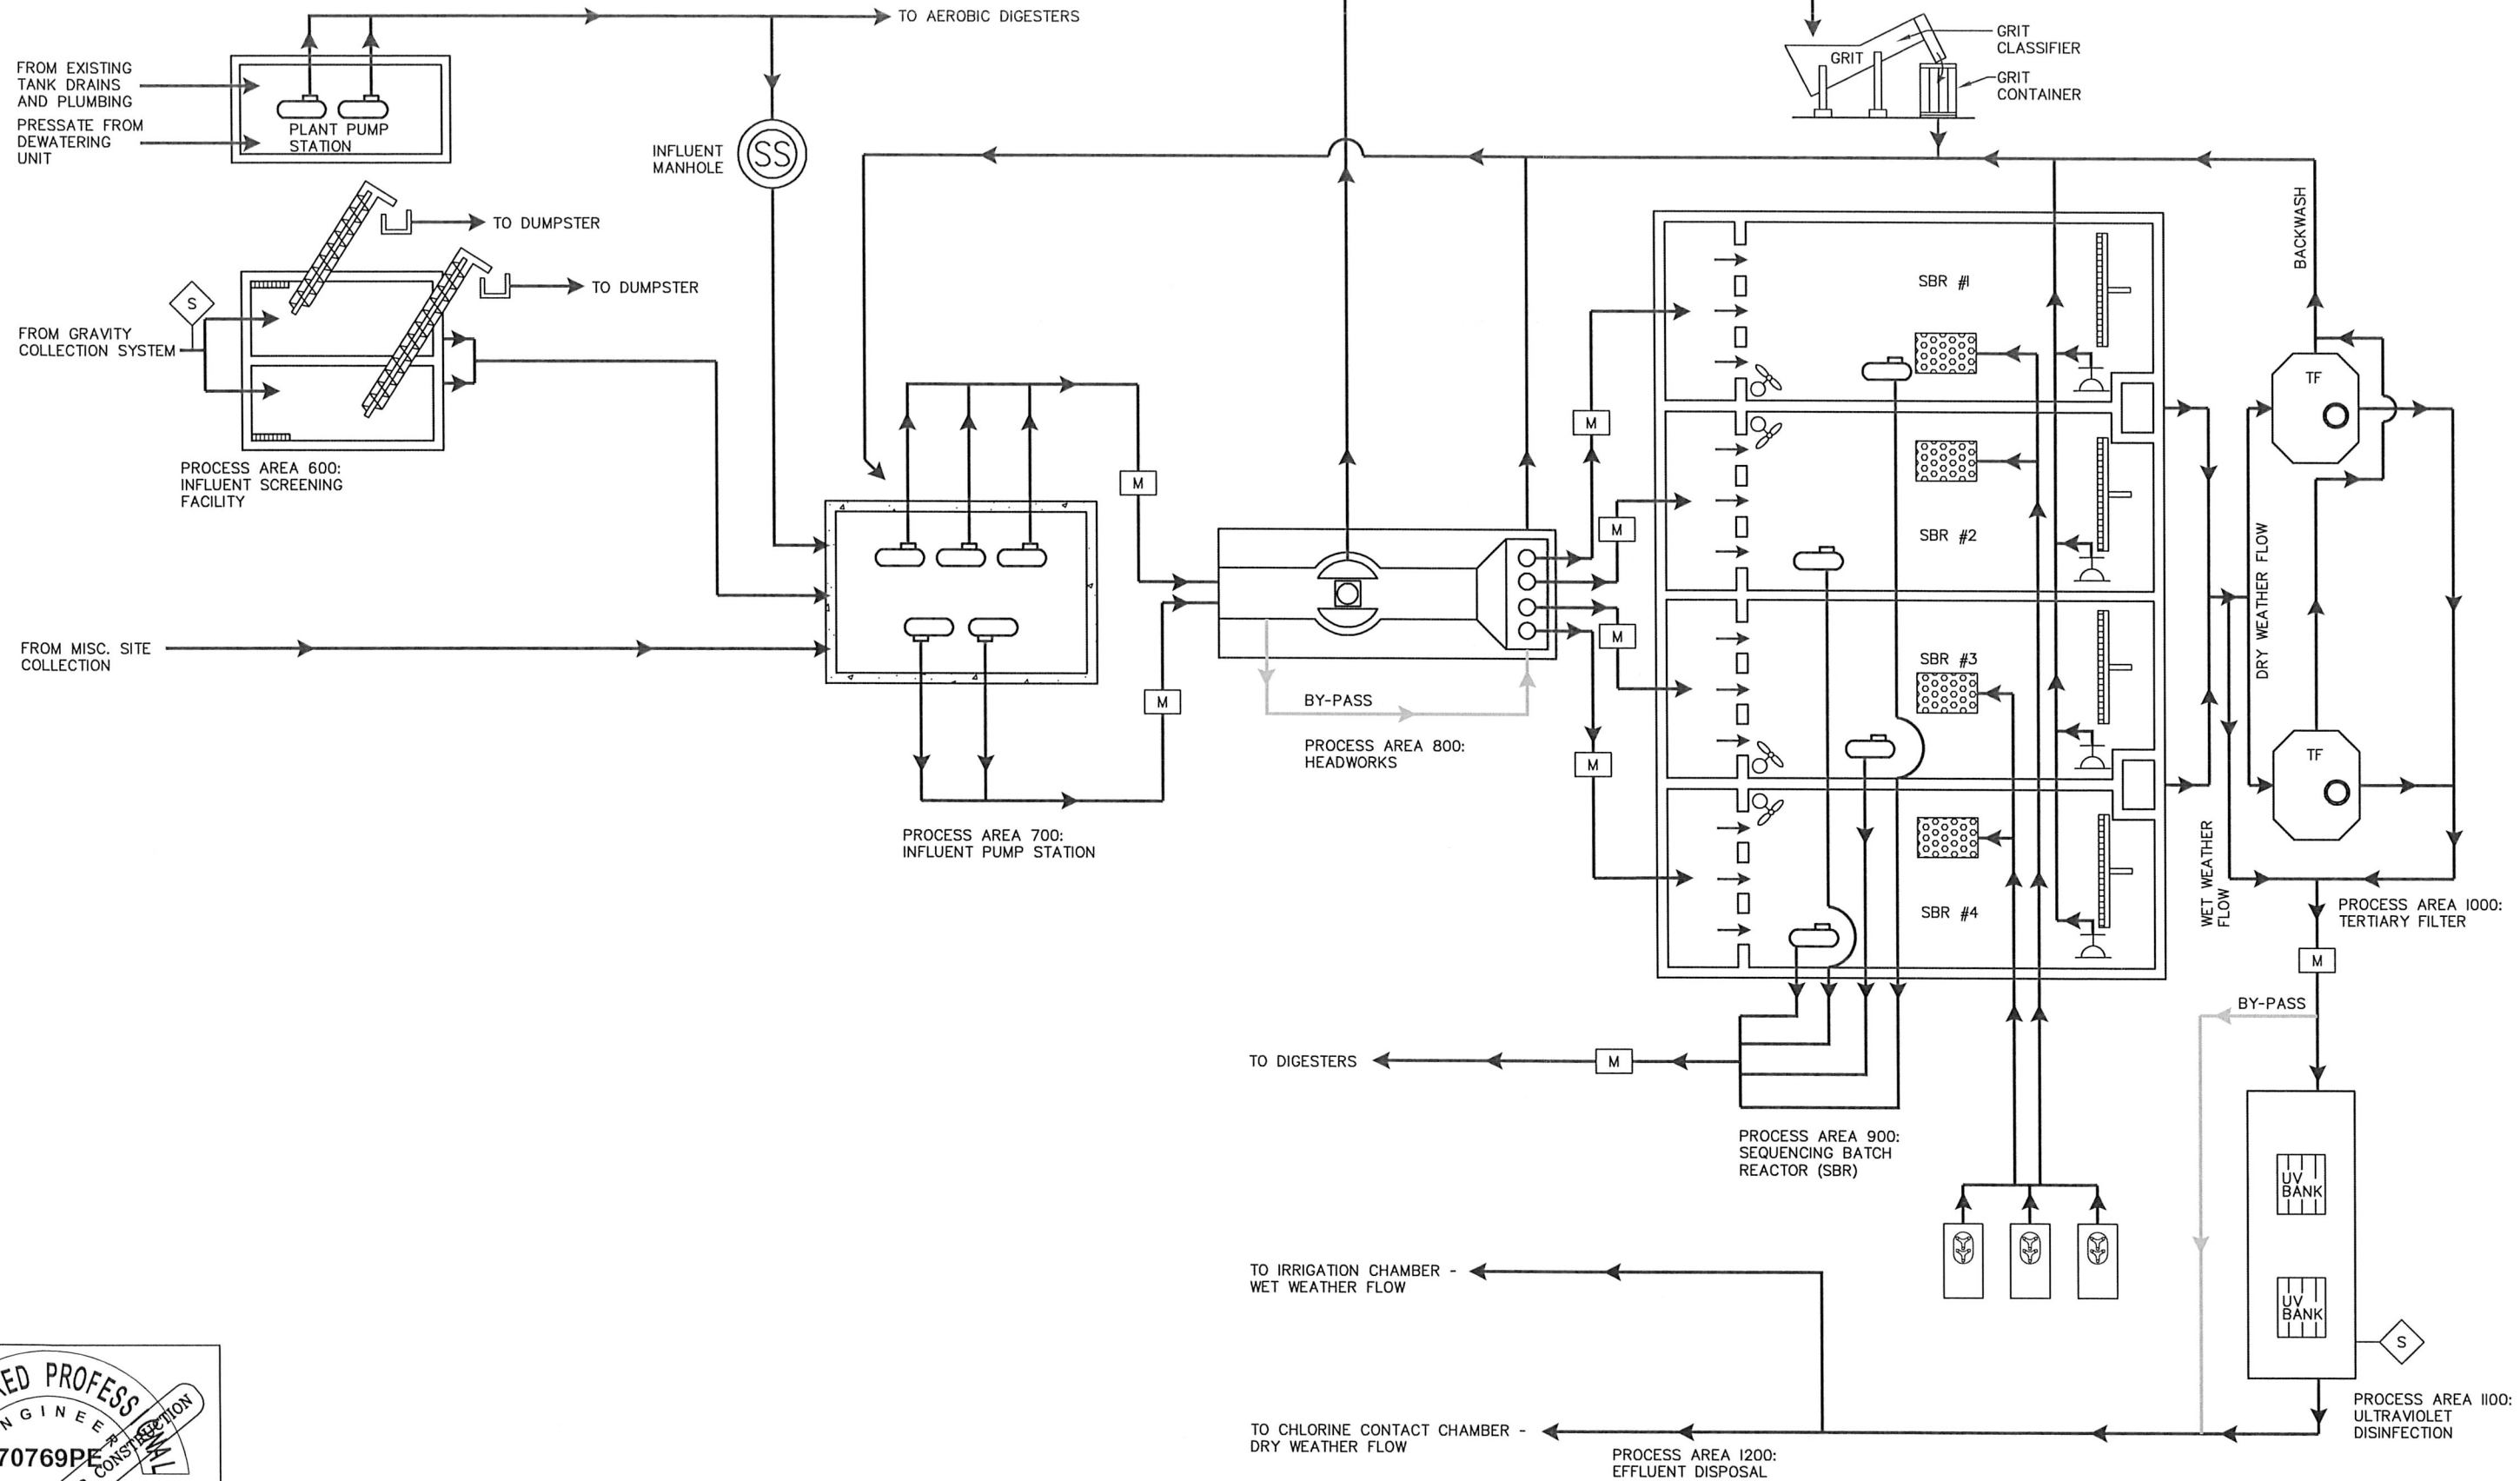


DESIGNED: _____
DRAWN: _____
APPROVED BY: _____
DATE: _____

REVISIONS				
REVISED	DESCRIPTION	SUBMIT	APPR'D	DATE

D THE DYER PARTNERSHIP
ENGINEERS & PLANNERS, INC.
1330 TEAKWOOD AVENUE
COOS BAY, OREGON 97420
TELEPHONE: (541) 269-0732
www.dyerpart.com


LINE IS 1 INCH
AT FULL SCALE
IF NOT 1-INCH - SCALE ACCORDINGLY

WASTEWATER TREATMENT PLANT IMPROVEMENTS CITY OF SUTHERLIN		PROJECT NO. 146.38	DRAWING NO. P2
PROCESS GENERAL PROCESS DIAGRAM - LIQUID STREAM		DATE MAY 2016	SHEET NO. 11 OF 70

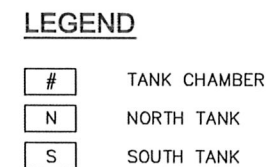

DESIGNED: ----	DRAWN: ----	REVISIONS					 THE DYER PARTNERSHIP ENGINEERS & PLANNERS, INC. 1330 TEAKWOOD AVENUE COOS BAY, OREGON 97420 TELEPHONE: (541) 269-0732 www.dyerpart.com	WASTEWATER TREATMENT PLANT IMPROVEMENTS CITY OF SUTHERLIN		PROJECT NO.	DRAWING NO.
		REVISED	DESCRIPTION	SUBMIT	APPR'D.	DATE				146.38	P3
APPROVED BY: _____ DATE: _____								PROCESS GENERAL PROCESS DIAGRAM - WASTE STREAM		DATE	SHEET NO.
										MAY 2016	12 OF 70

\\dye\dyer-part\Aprojects\146 Sutherlin\146.38 WWTF Pre-Design Report\dwg\PRE-DESIGN\PROCESS AREA 100 OVERALL\P4.dwg, 11/30/2015 3:47:27 PM PLOT DATE May 5, 2016

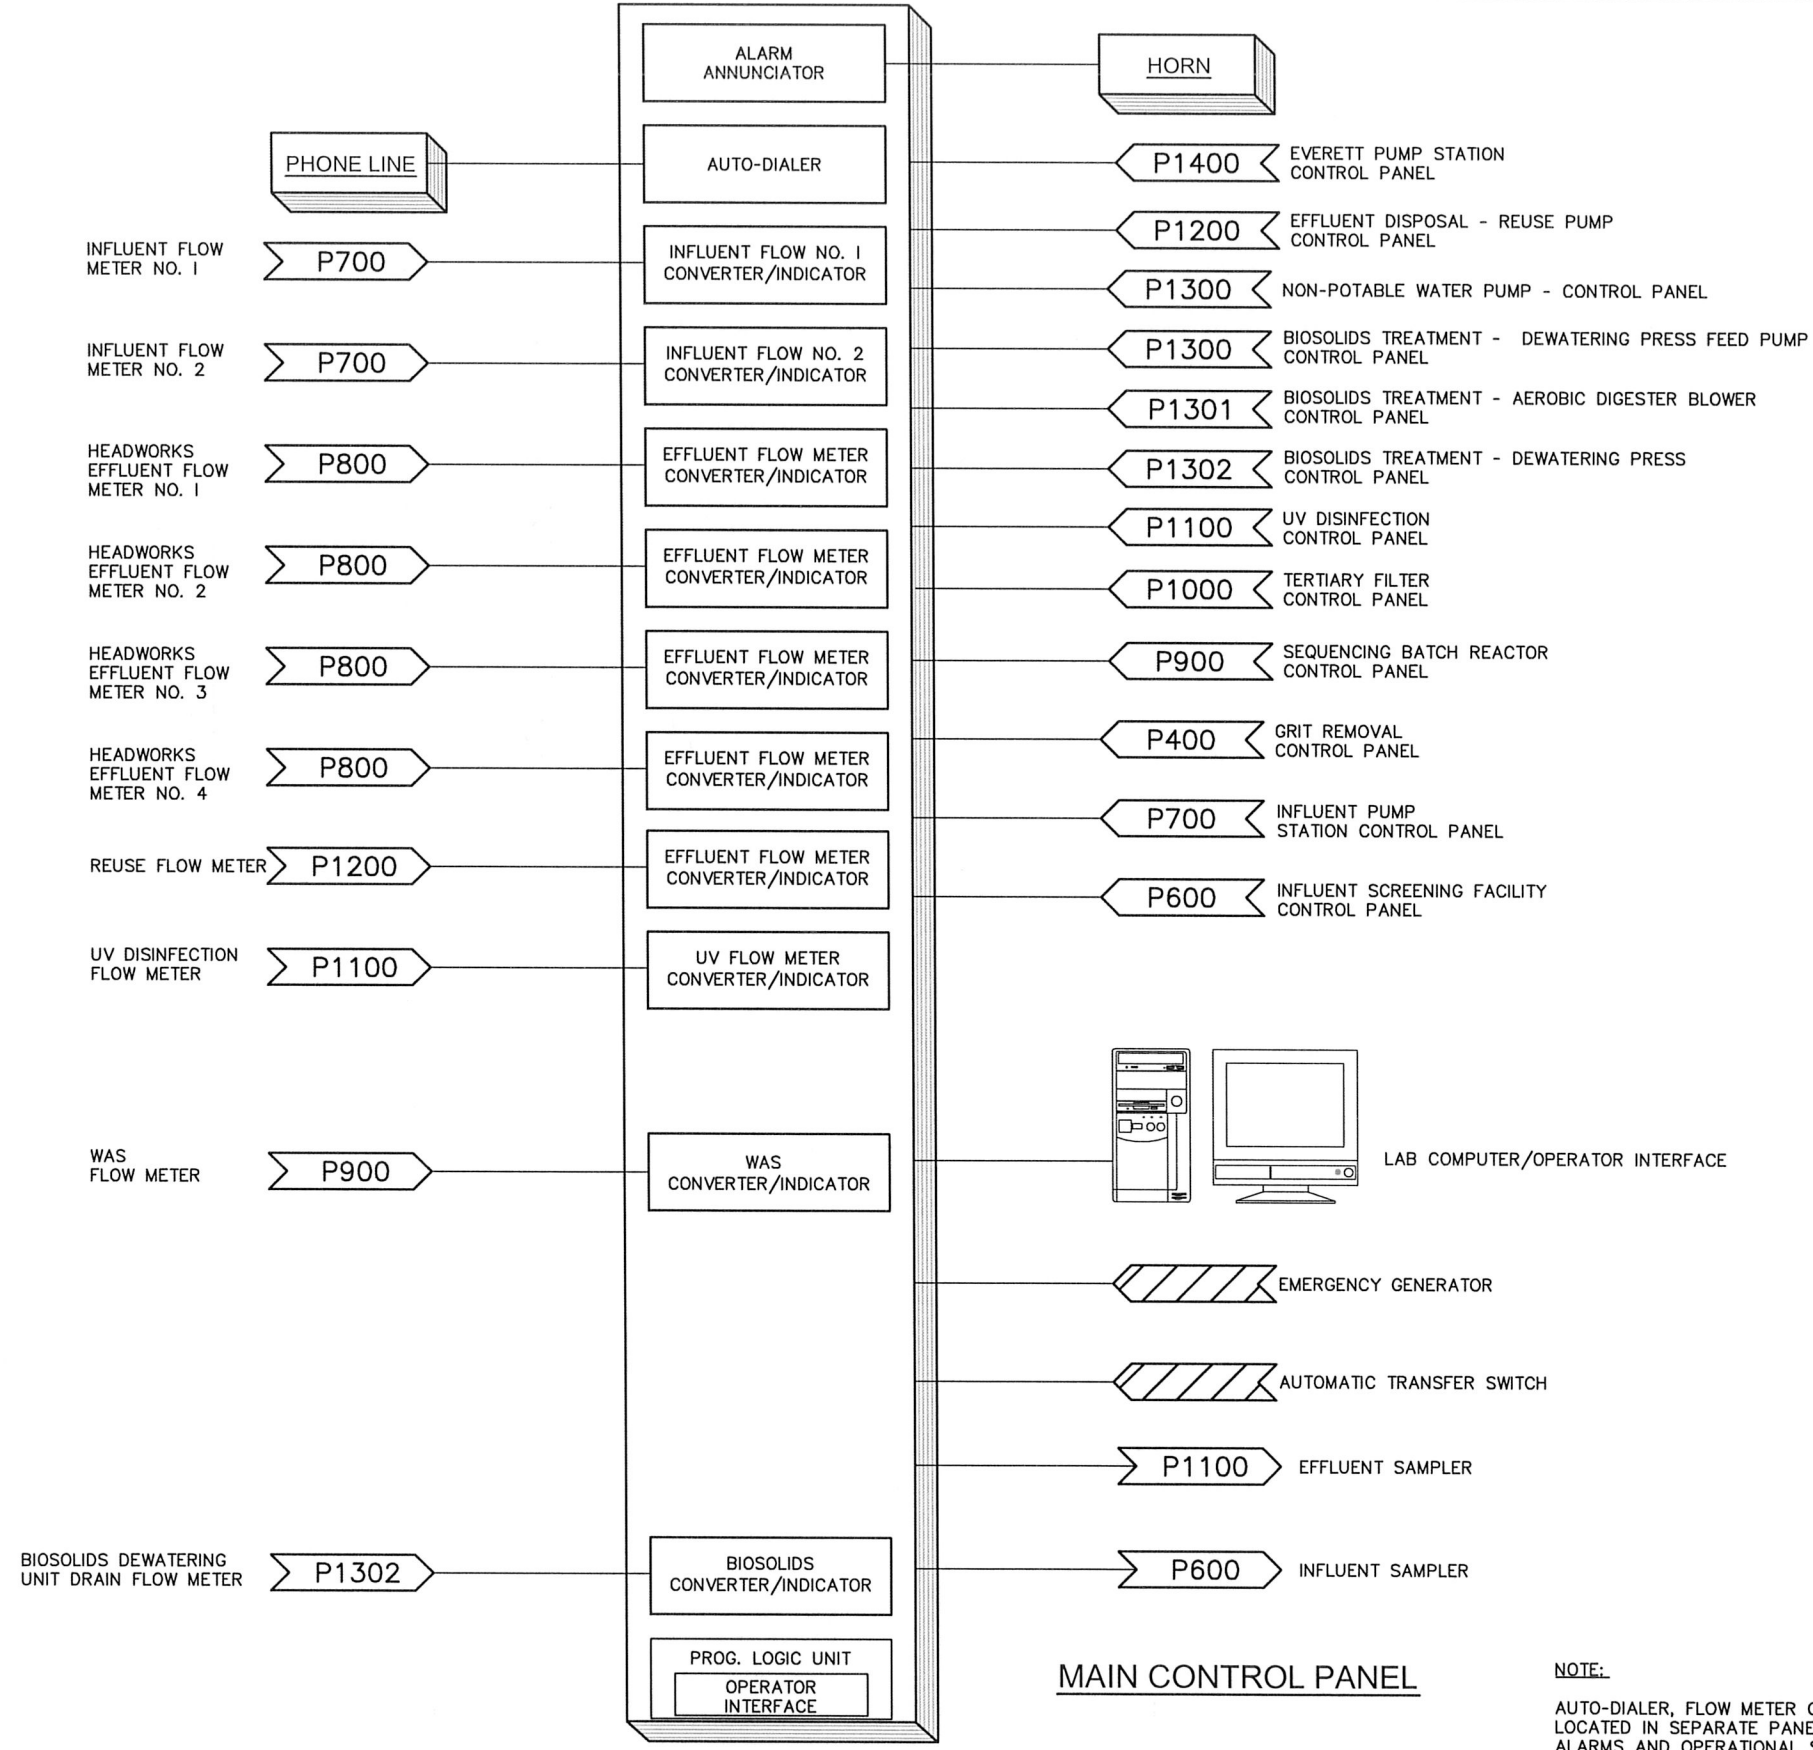

NOTE:
AUTO-DIALER, FLOW METER CONVERTERS, AND OTHER DEVICES MAY BE LOCATED IN SEPARATE PANELS, BUT WILL ALL TRANSMIT INFORMATION, ALARMS AND OPERATIONAL STATUS TO MAIN CONTROL PANEL PLC.



DESIGNED: ----	DRAWN: ----
APPROVED BY: _____	DATE: _____

REVISIONS				
REVISED	DESCRIPTION	SUBMIT.	APPR'D.	DATE



THE DYER PARTNERSHIP
ENGINEERS & PLANNERS, INC.
1330 TEAKWOOD AVENUE
COOS BAY, OREGON 97420
TELEPHONE: (541) 269-0732
www.dyerpart.com

LINE IS 1 INCH
AT FULL SCALE
IF NOT 1-INCH - SCALE ACCORDINGLY


WASTEWATER TREATMENT PLANT IMPROVEMENTS
CITY OF SUTHERLIN

PROCESS
MAIN CONTROL PANEL

PROJECT NO. 146.38	DRAWING NO. P4
DATE MAY 2016	SHEET NO. 13 OF 70



DESIGNED: _____		DRAWN: _____		<table><tr><th>REVISED</th><th>DESCRIPTION</th><th>SUBMIT.</th><th>APPR'D.</th><th>DATE</th></tr><tr><td> </td><td> </td><td> </td><td> </td><td> </td></tr><tr><td> </td><td> </td><td> </td><td> </td><td> </td></tr><tr><td> </td><td> </td><td> </td><td> </td><td> </td></tr><tr><td> </td><td> </td><td> </td><td> </td><td> </td></tr><tr><td> </td><td> </td><td> </td><td> </td><td> </td></tr><tr><td> </td><td> </td><td> </td><td> </td><td> </td></tr><tr><td> </td><td> </td><td> </td><td> </td><td> </td></tr></table>					REVISED	DESCRIPTION	SUBMIT.	APPR'D.	DATE																																				D THE DYER PARTNERSHIP ENGINEERS & PLANNERS, INC. 1330 TEAKWOOD AVENUE COOS BAY, OREGON 97420 TELEPHONE: (541) 269-0732 www.dyerpart.com LINE IS 1 INCH AT FULL SCALE IF NOT 1-INCH - SCALE ACCORDINGLY		WASTEWATER TREATMENT PLANT IMPROVEMENTS CITY OF SUTHERLIN		PROJECT NO. 146.38	DRAWING NO. P600
REVISED	DESCRIPTION	SUBMIT.	APPR'D.						DATE																																													
APPROVED BY: _____DATE: _____				PROCESS INFLUENT SCREENING FACILITY		DATE MAY 2016	SHEET NO. 14 OF 70																																															

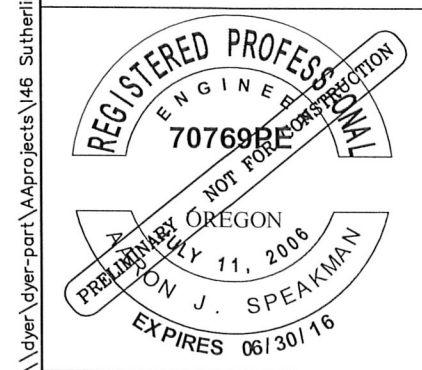

DESIGNED: _____
DRAWN: _____
APPROVED BY: _____
DATE: _____


REVISIONS				
REVISED	DESCRIPTION	SUBMIT.	APPR'D.	DATE

D


THE DYER PARTNERSHIP
ENGINEERS & PLANNERS, INC.
1330 TEAKWOOD AVENUE
COOS BAY, OREGON 97420
TELEPHONE: (541) 269-0732
www.dyerpart.com

LINE IS 1 INCH
AT FULL SCALE
IF NOT 1-INCH - SCALE ACCORDINGLY

WASTEWATER TREATMENT PLANT IMPROVEMENTS CITY OF SUTHERLIN		PROJECT NO. 146.38	DRAWING NO. P700
		DATE MAY 2016	SHEET NO. 15 OF 70

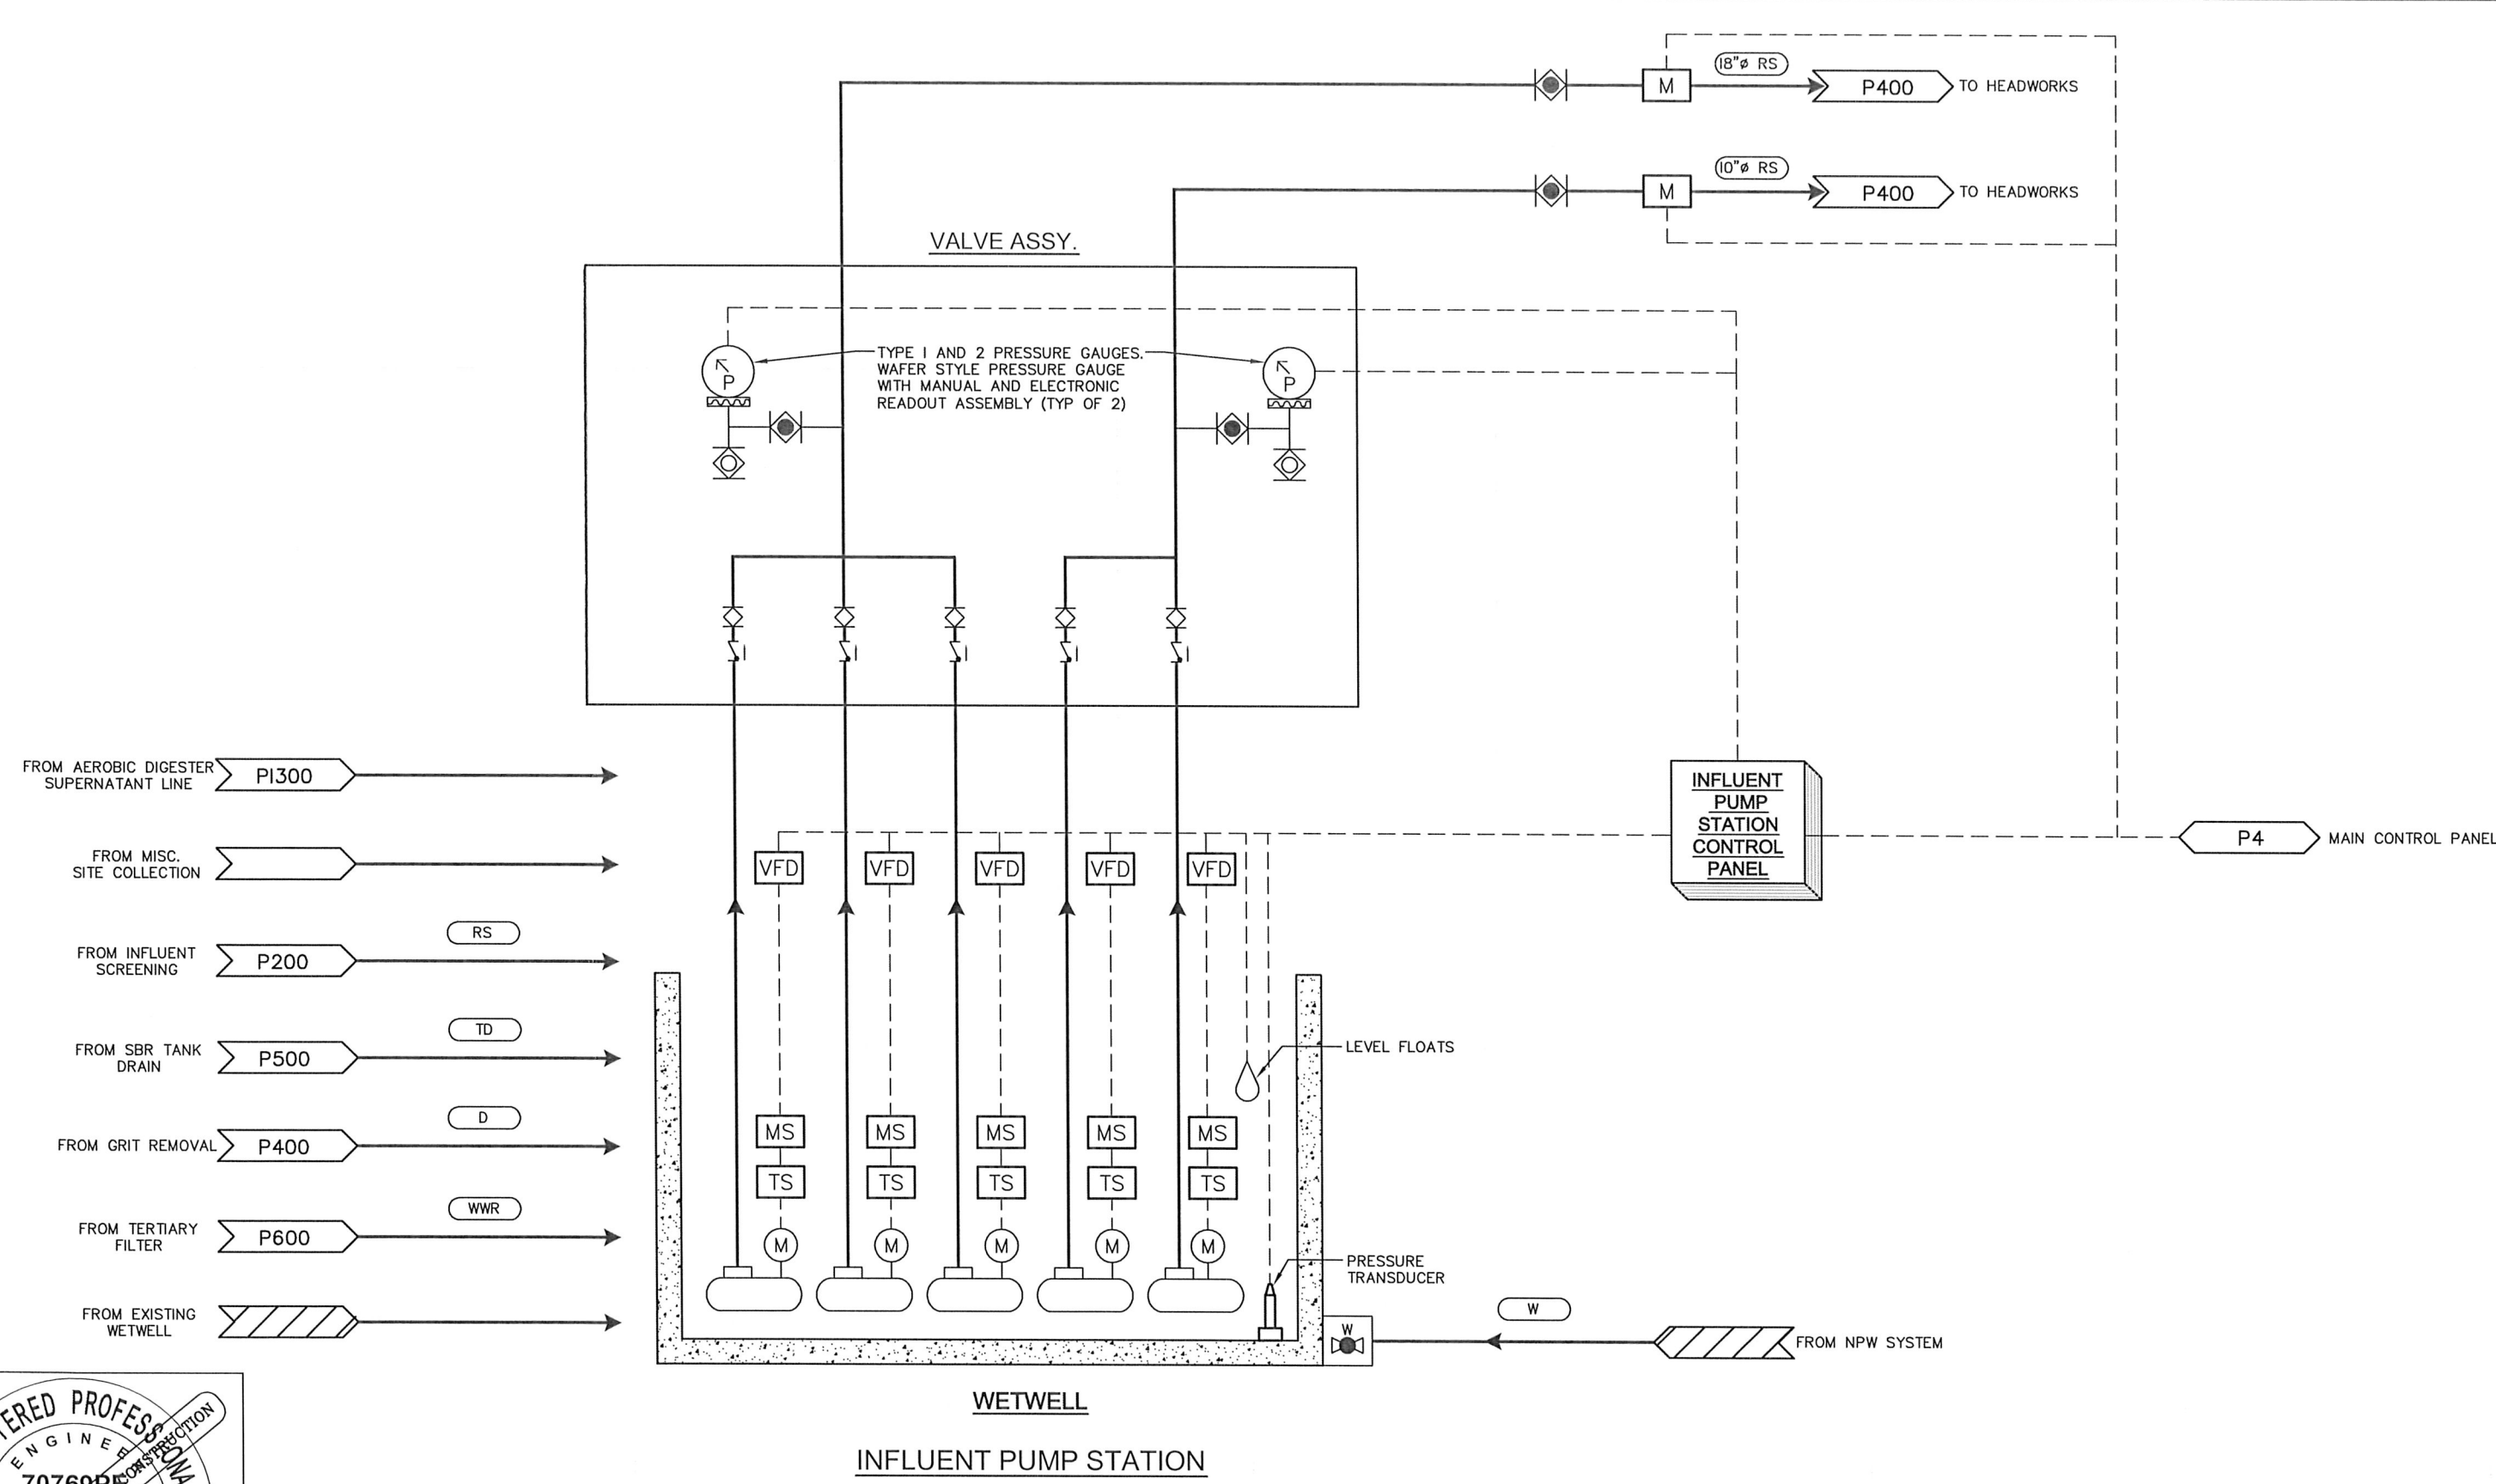

\\dyer\dyer-part\A\projects\146 Sutherlin\146.38 WWTF Pre-Design Report\dwg\PRE-DESIGN\PROCESS AREA 800 HEADWORKS\P800.dwg, 5/3/2016 1:46:59 PM May 5, 2016 PLOT DATE

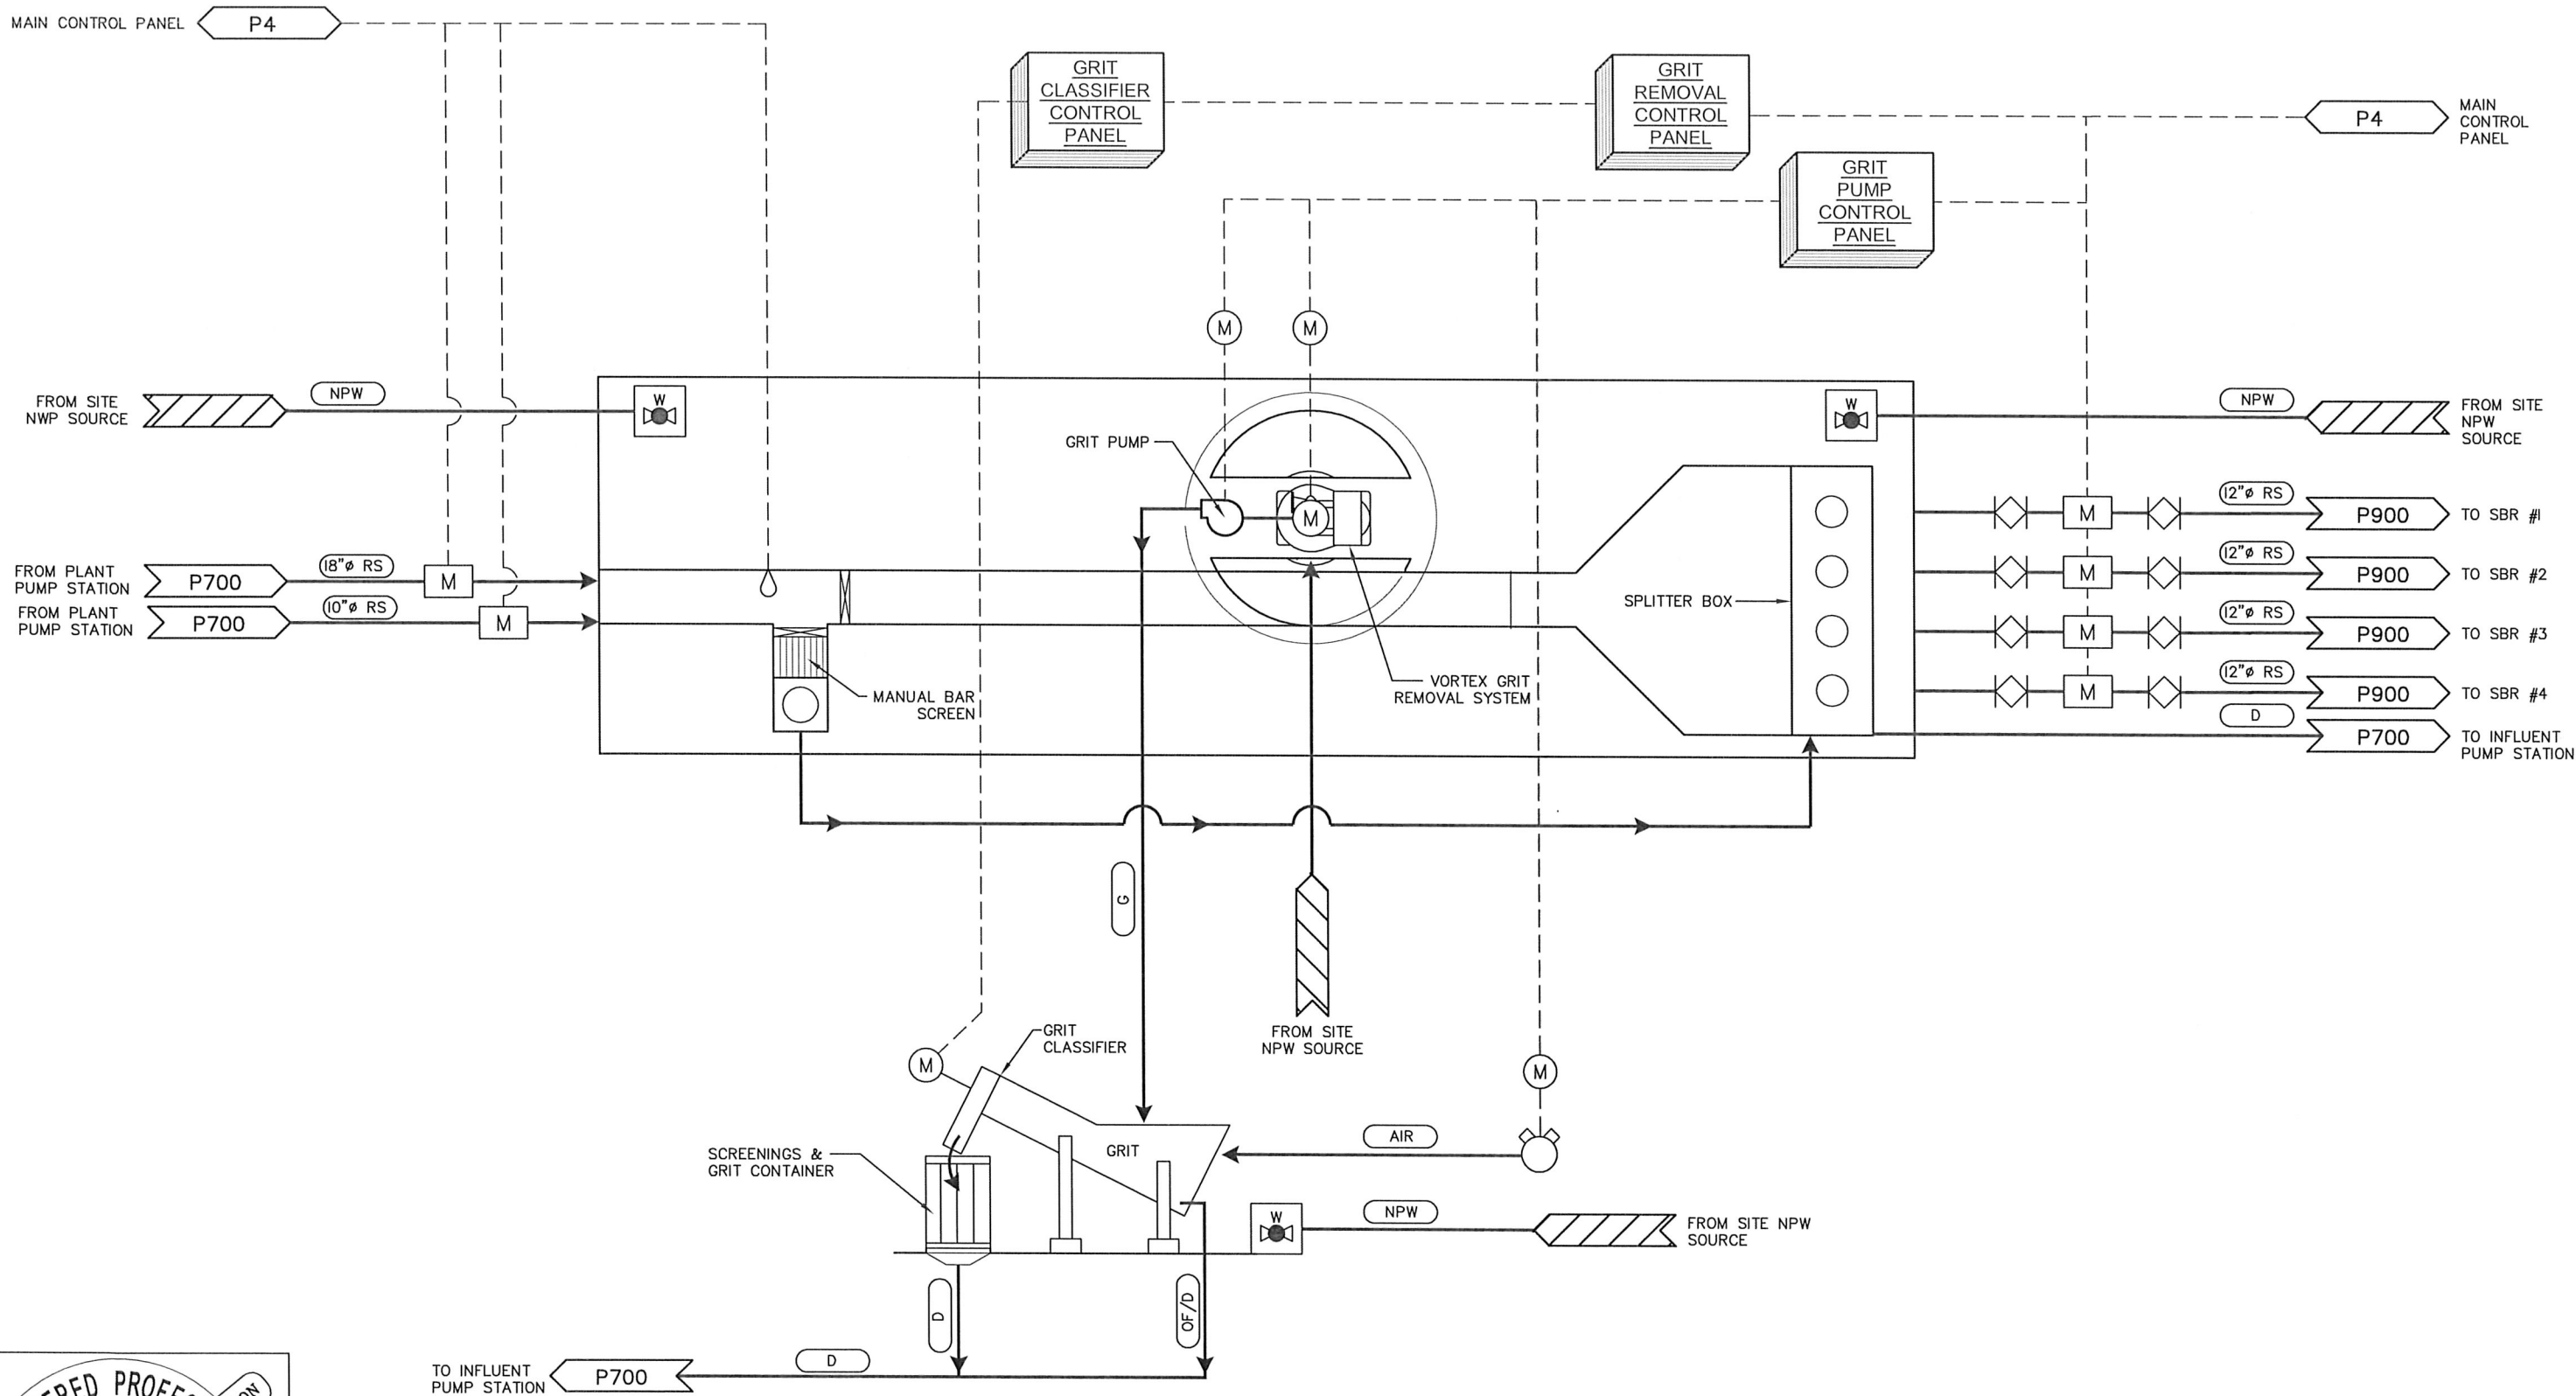

HEADWORKS



DESIGNED:	DRAWN:
---	---
APPROVED BY:	DATE:
---	---

REVISIONS				
REVISED	DESCRIPTION	SUBMIT.	APPR'D.	DATE




THE DYER PARTNERSHIP
ENGINEERS & PLANNERS, INC.
1330 TEAKWOOD AVENUE
COOS BAY, OREGON 97420
TELEPHONE: (541) 269-0732
www.dyerpart.com

LINE IS 1 INCH
AT FULL SCALE
IF NOT 1-INCH - SCALE ACCORDINGLY

WASTEWATER TREATMENT PLANT IMPROVEMENTS CITY OF SUTHERLIN		PROJECT NO. 146.38	DRAWING NO. P800
PROCESS HEADWORKS		DATE MAY 2016	SHEET NO. 16 OF 70

\\dyer\dyer-part\A\Projects\146 Sutherlin\146 WWTF Pre-Design Report\dwg\PRE-DESIGN\PROCESS AREA 900 SBR\P900.dwg, 12/1/2015 10:19:41 AM PLOT DATE May 5, 2016

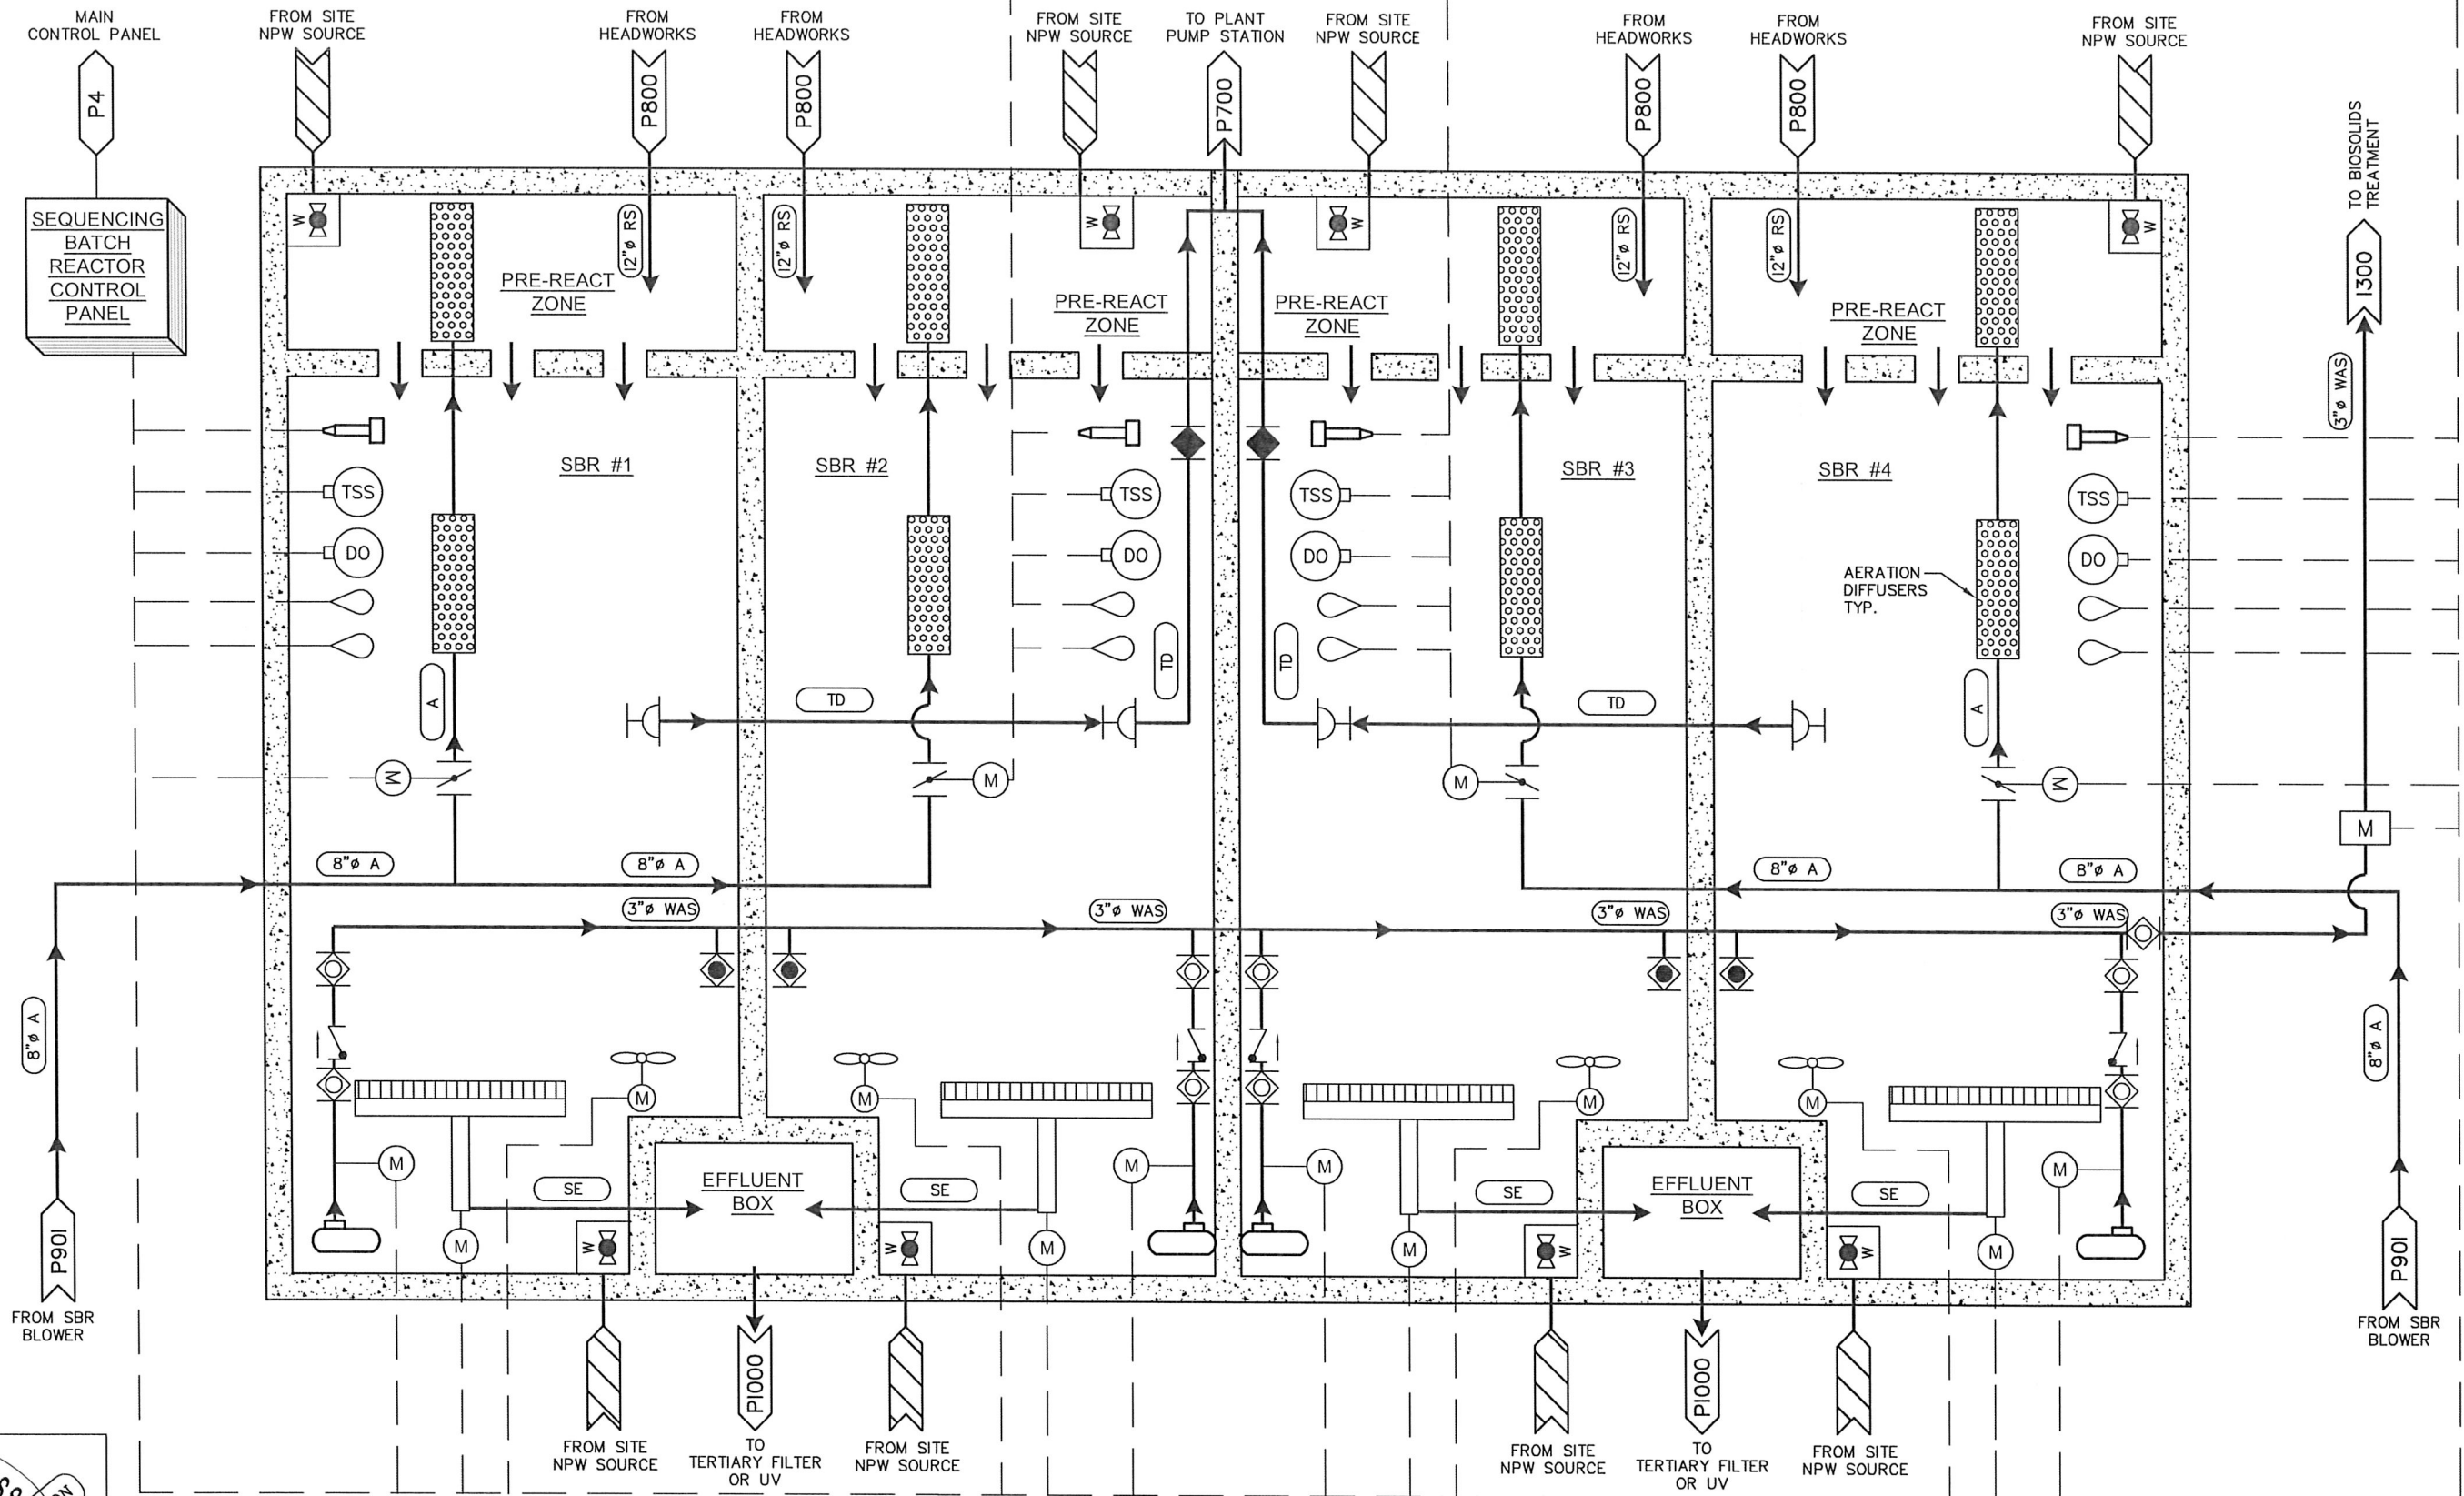

SEQUENCING BATCH REACTOR (SBR)



DESIGNED:	DRAWN:
---	---
APPROVED BY:	DATE:
---	---


REVISIONS				
REVISED	DESCRIPTION	SUBMIT.	APPR'D.	DATE

D THE DYER PARTNERSHIP
ENGINEERS & PLANNERS, INC.
1330 TEAKWOOD AVENUE
COOS BAY, OREGON 97420
TELEPHONE: (541) 269-0732
www.dyerpart.com

LINE IS 1 INCH
AT FULL SCALE
IF NOT 1-INCH - SCALE ACCORDINGLY

WASTEWATER TREATMENT PLANT IMPROVEMENTS CITY OF SUTHERLIN		PROJECT NO. 146.38	DRAWING NO. P900
PROCESS SBR		DATE MAY 2016	SHEET NO. 17 OF 70

\\dye\dyer-part\A\projects\146 Sutherlin\146.38 WWTF Pre-Design Report\dwg\PRE-DESIGN\PROCESS AREA 900 SBR\p901.dwg, 11/30/2015 3:50:46 PM May 5, 2016 PLOT DATE

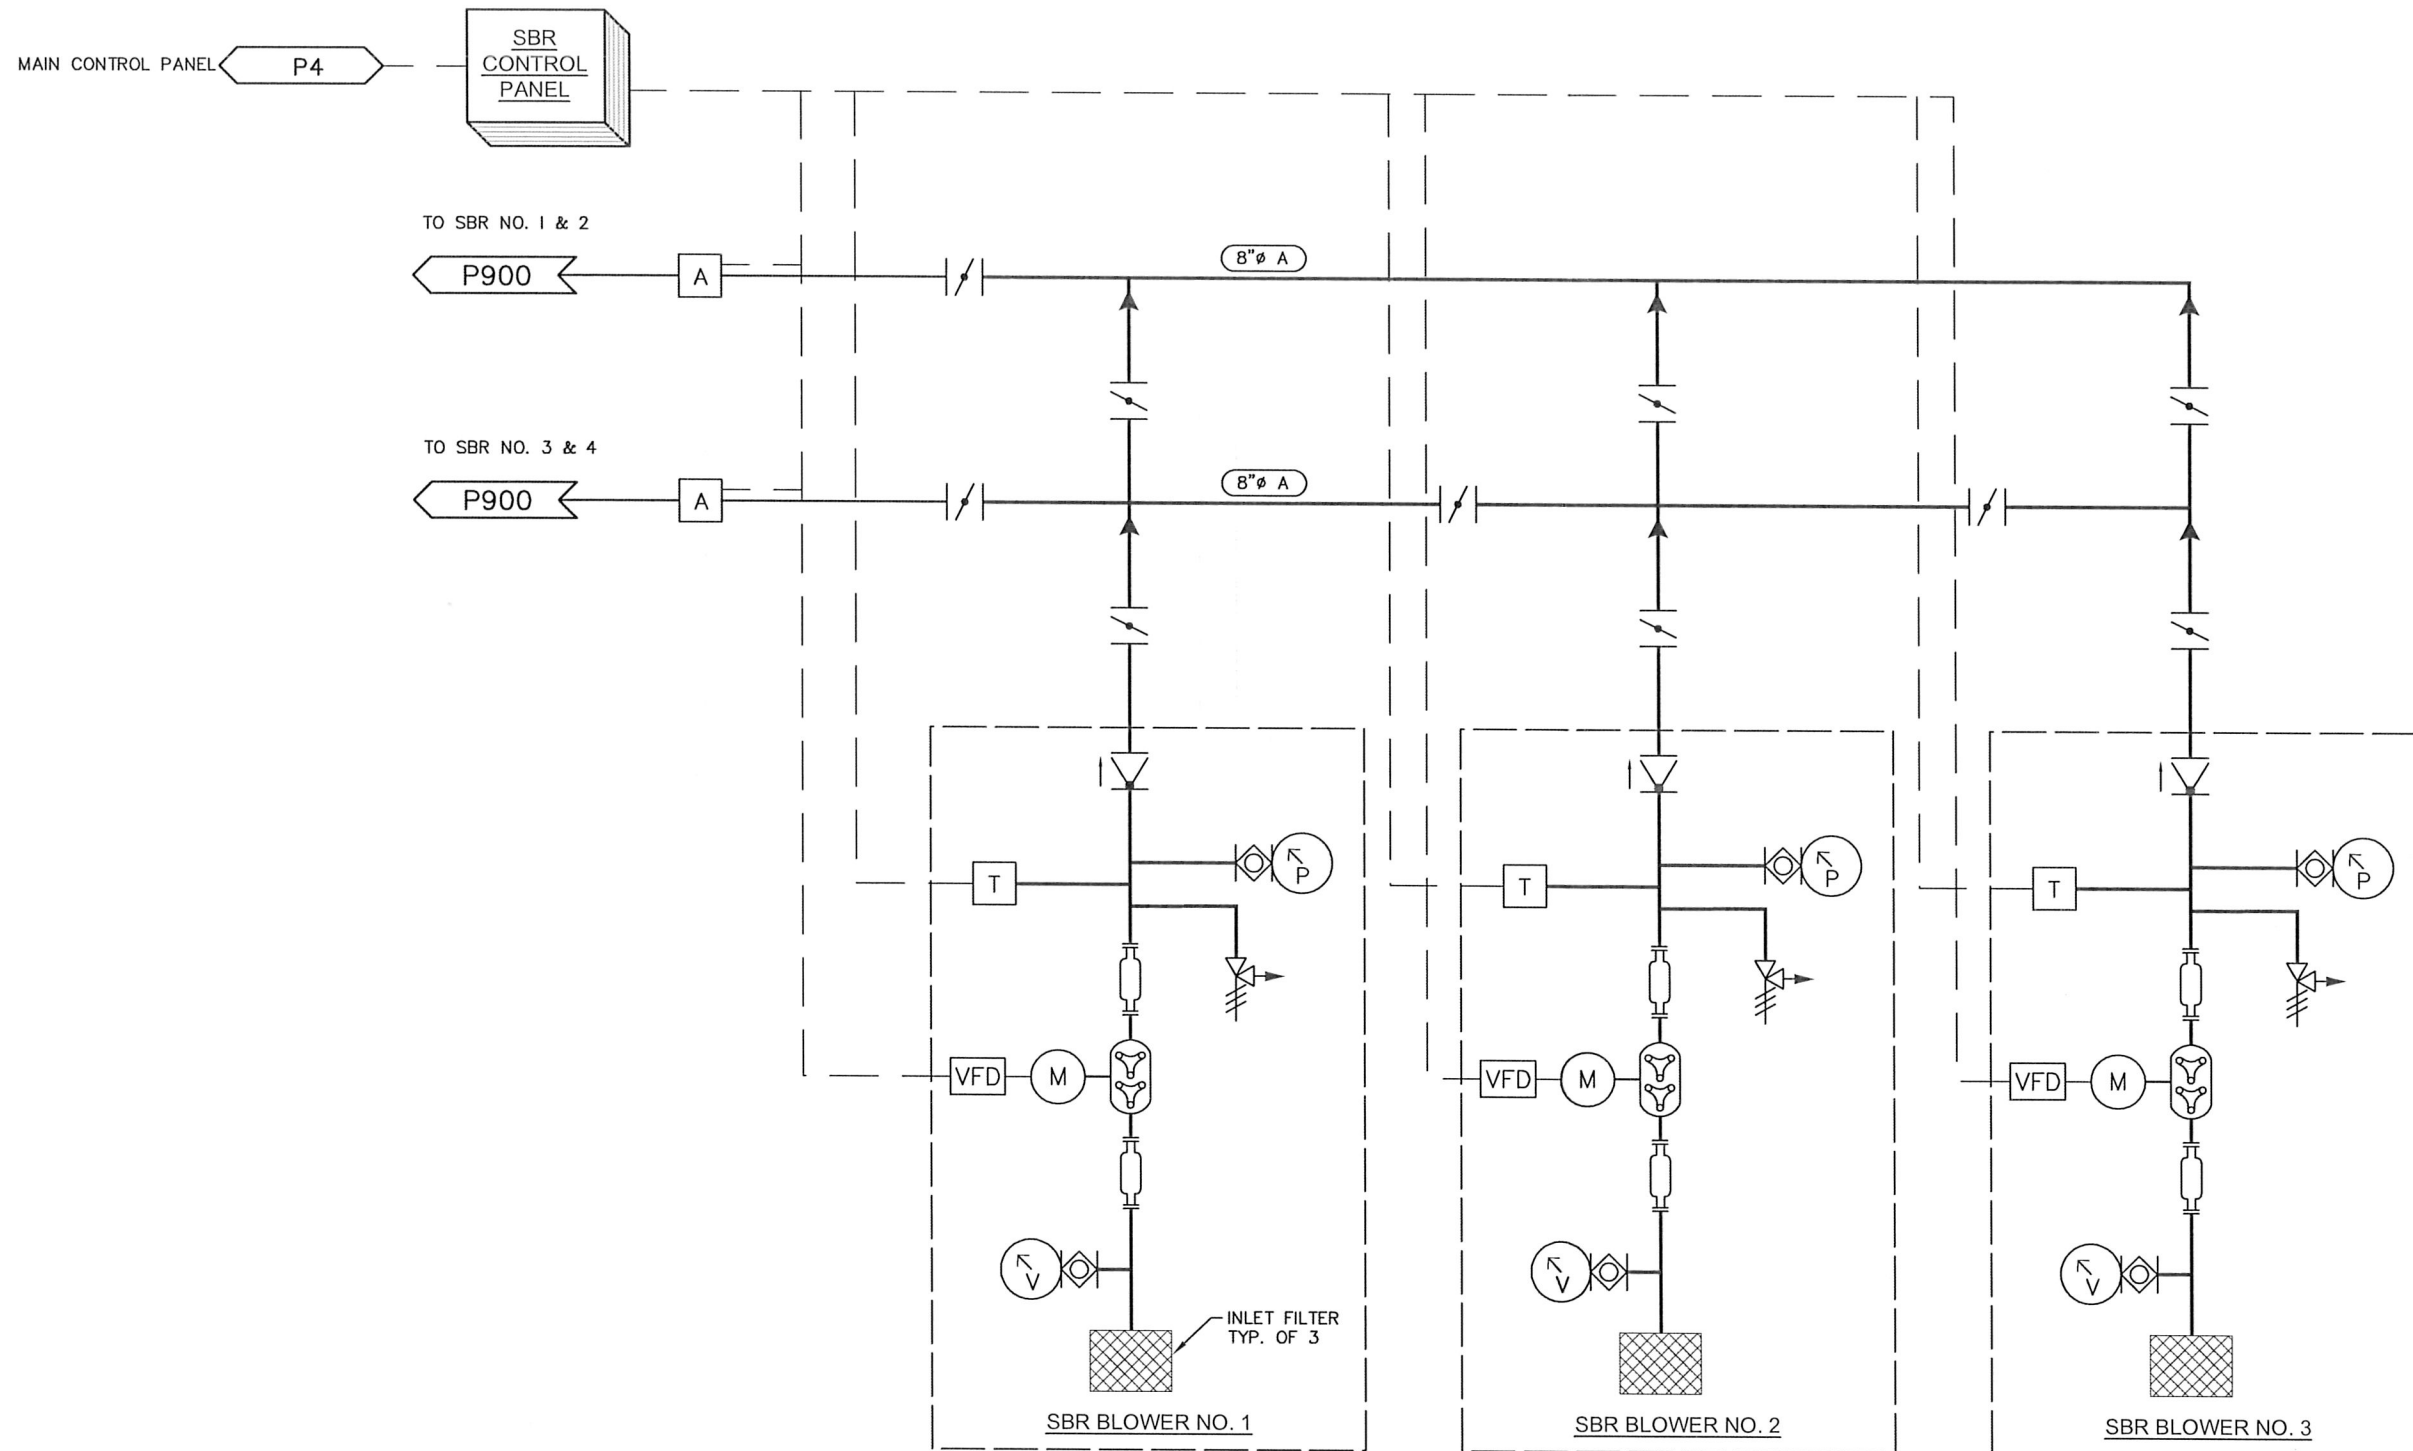

SBR BLOWERS



DESIGNED:	DRAWN:	REVISIONS			
----	----	REVISED	DESCRIPTION	SUBMIT.	APPR'D. DATE
APPROVED BY:					
DATE:					




THE DYER PARTNERSHIP
ENGINEERS & PLANNERS, INC.
1330 TEAKWOOD AVENUE
COOS BAY, OREGON 97420
TELEPHONE: (541) 269-0732
www.dyerpart.com

LINE IS 1 INCH
AT FULL SCALE
IF NOT 1-INCH - SCALE ACCORDINGLY

WASTEWATER TREATMENT PLANT IMPROVEMENTS
CITY OF SUTHERLIN

PROCESS
SBR BLOWERS

PROJECT NO.	DRAWING NO.
146.38	P901
DATE	SHEET NO.
MAY 2016	18 OF 70

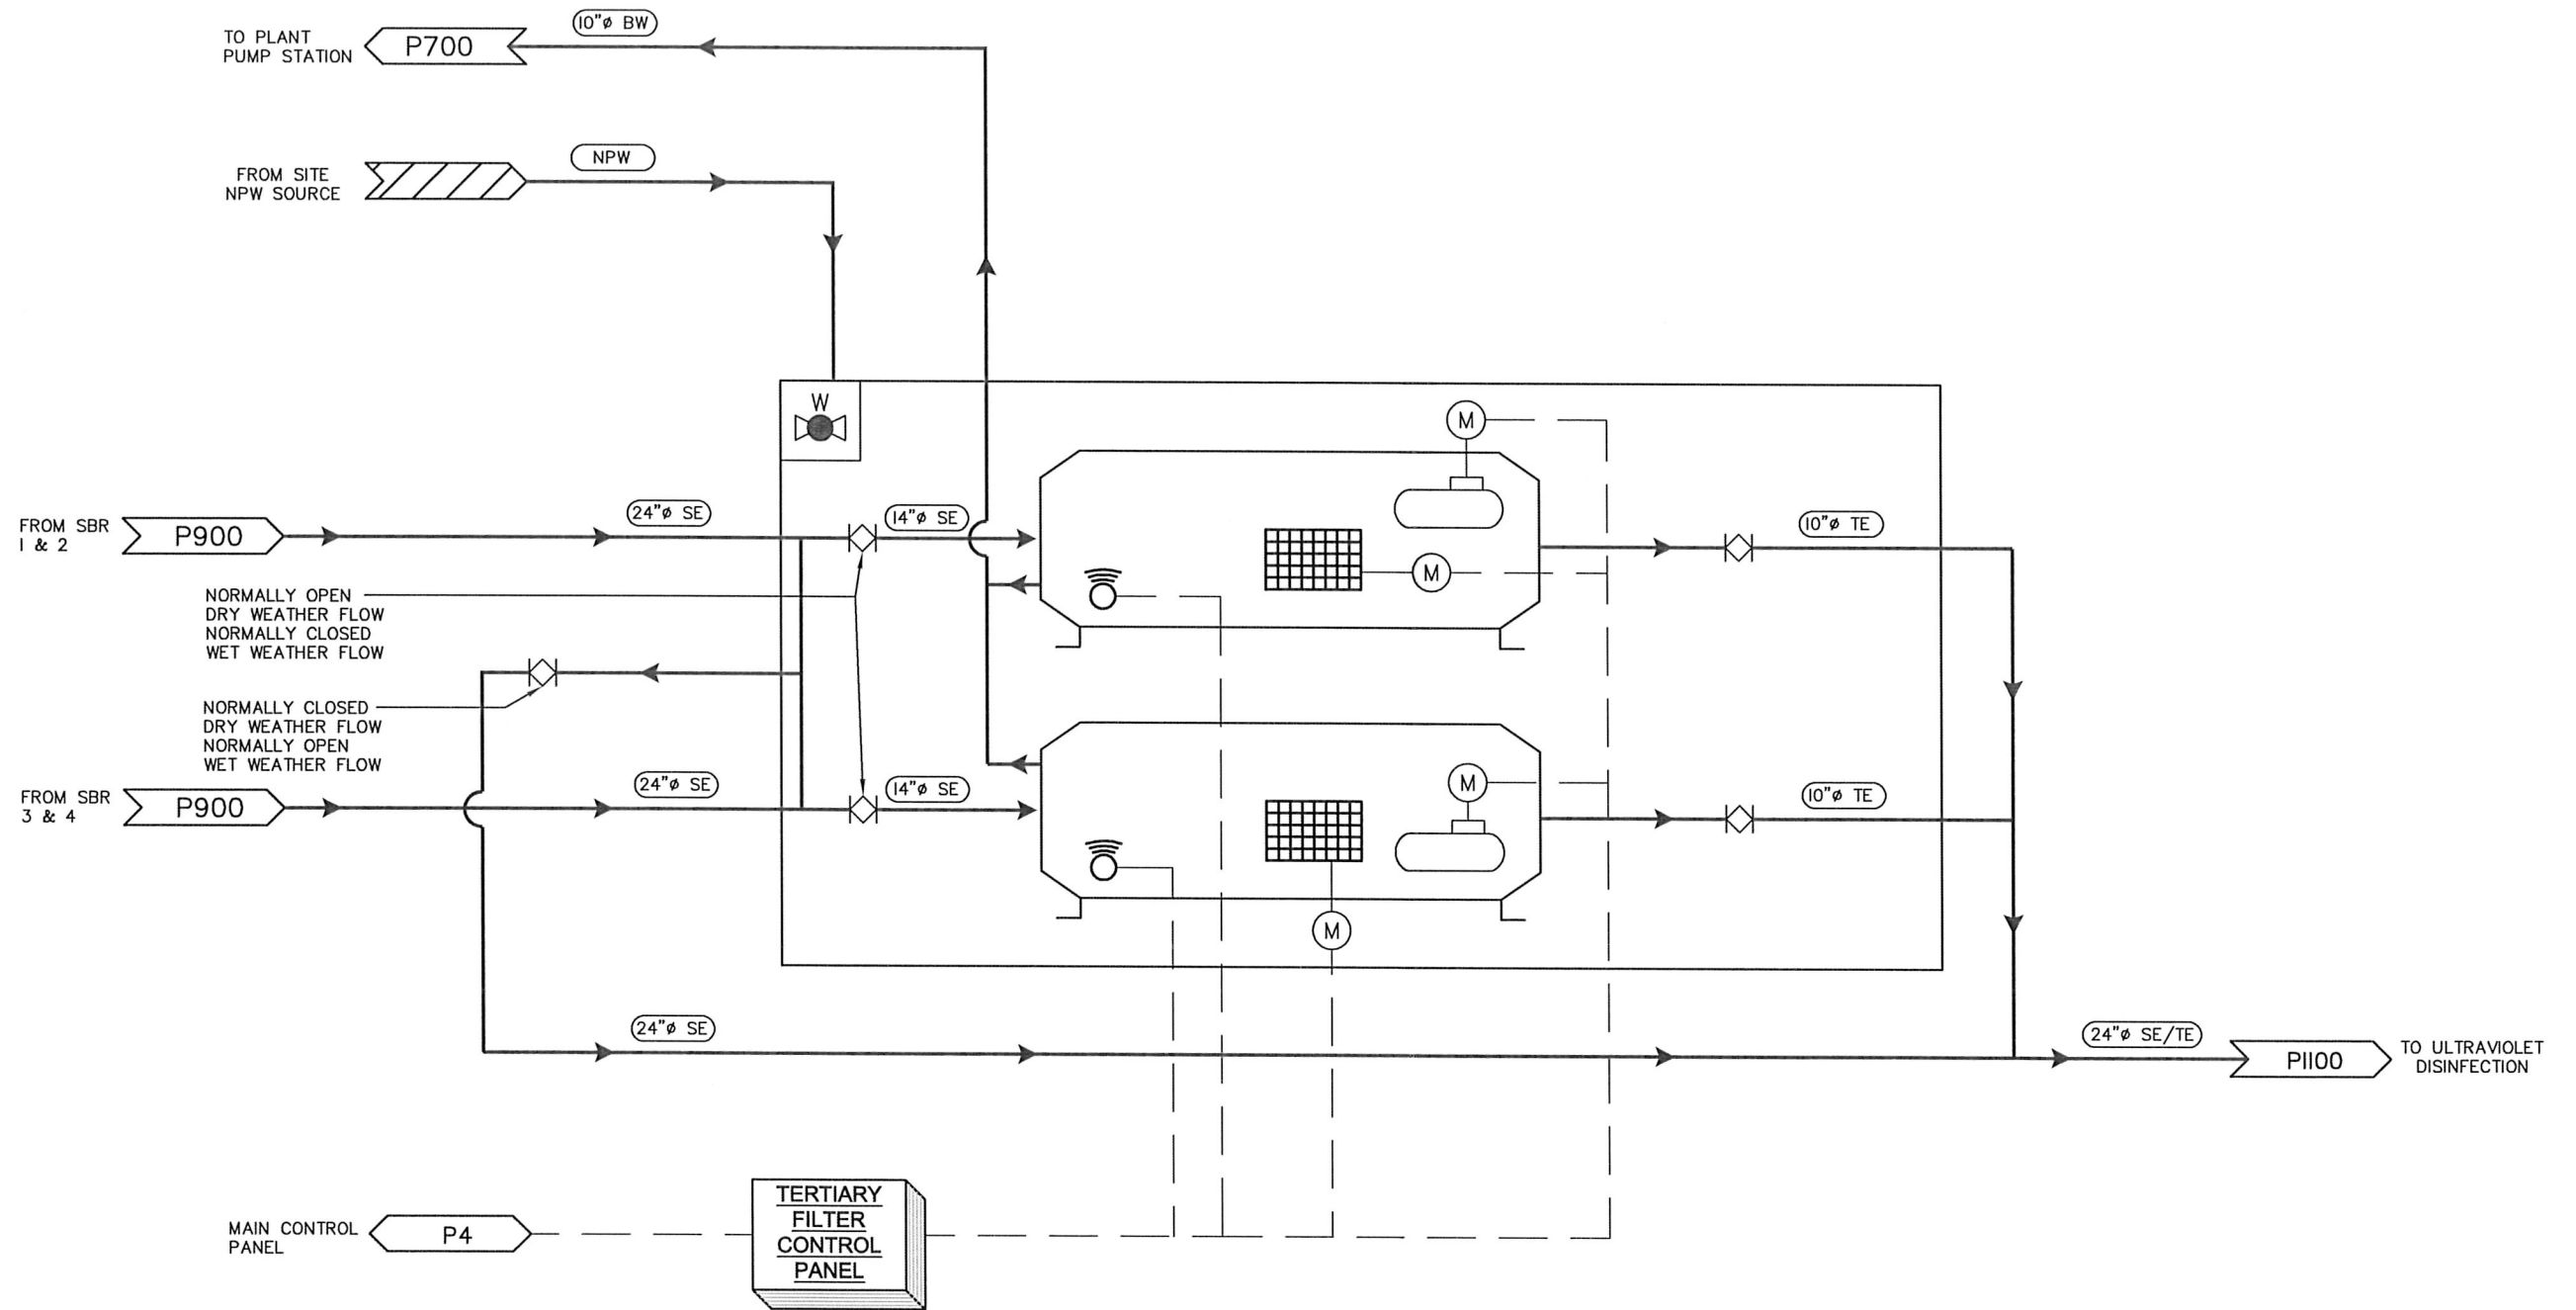

TERTIARY FILTER



DESIGNED: _____
DRAWN: _____
APPROVED BY: _____
DATE: _____

REVISIONS				
REVISED	DESCRIPTION	SUBMIT.	APPR'D.	DATE

D THE DYER PARTNERSHIP
ENGINEERS & PLANNERS, INC.
1330 TEAKWOOD AVENUE
COOS BAY, OREGON 97420
TELEPHONE: (541) 269-0732
www.dyerpart.com


LINE IS 1 INCH
AT FULL SCALE
IF NOT 1-INCH - SCALE ACCORDINGLY

**WASTEWATER TREATMENT PLANT IMPROVEMENTS
CITY OF SUTHERLIN**

**PROCESS
TERTIARY FILTERS**

PROJECT NO. 146.38	DRAWING NO. P1000
DATE MAY 2016	SHEET NO. 19 OF 70

\\dye\dyer-part\A\projects\146 Sutherlin\146.38 WWTF Pre-Design Report\dwg\PRE-DESIGN\PROCESS AREA 1100 UV\PI1100.dwg, 5/3/2016 1:47:39 PM PLOT DATE May 5, 2016

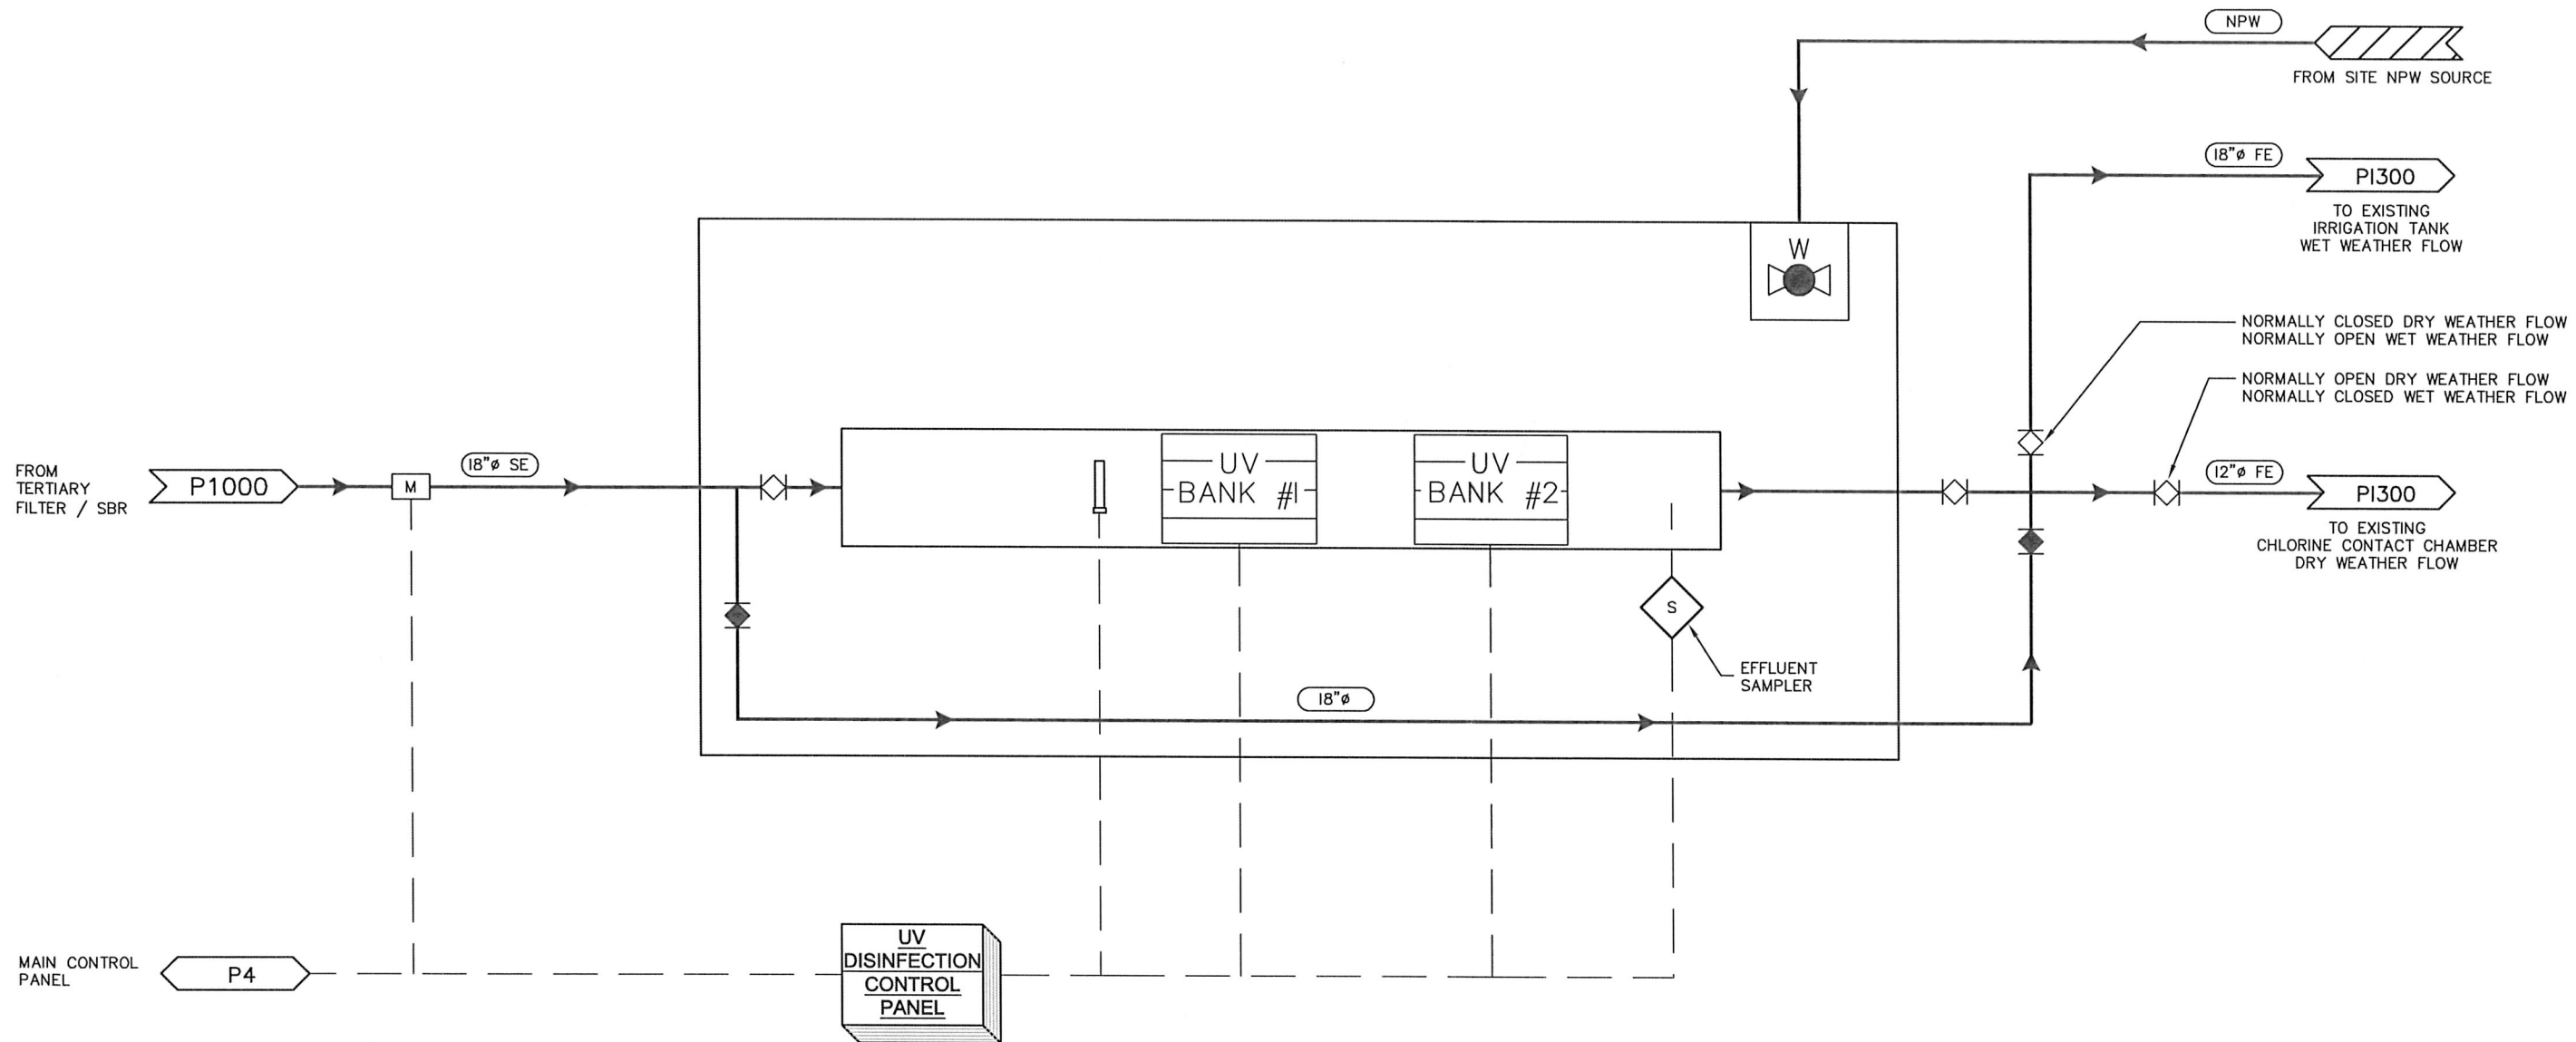

ULTRAVIOLET DISINFECTION



DESIGNED:	DRAWN:
----	----
APPROVED BY:	DATE:
-----	-----


REVISIONS				
REVISED	DESCRIPTION	SUBMIT.	APPR'D.	DATE



THE DYER PARTNERSHIP
ENGINEERS & PLANNERS, INC.
1330 TEAKWOOD AVENUE
COOS BAY, OREGON 97420
TELEPHONE: (541) 269-0732
www.dyerpart.com

LINE IS 1 INCH
AT FULL SCALE
IF NOT 1-INCH - SCALE ACCORDINGLY

WASTEWATER TREATMENT PLANT IMPROVEMENTS CITY OF SUTHERLIN		PROJECT NO. 146.38	DRAWING NO. P1100
PROCESS ULTRAVIOLET DISINFECTION		DATE MAY 2016	SHEET NO. 20 OF 70

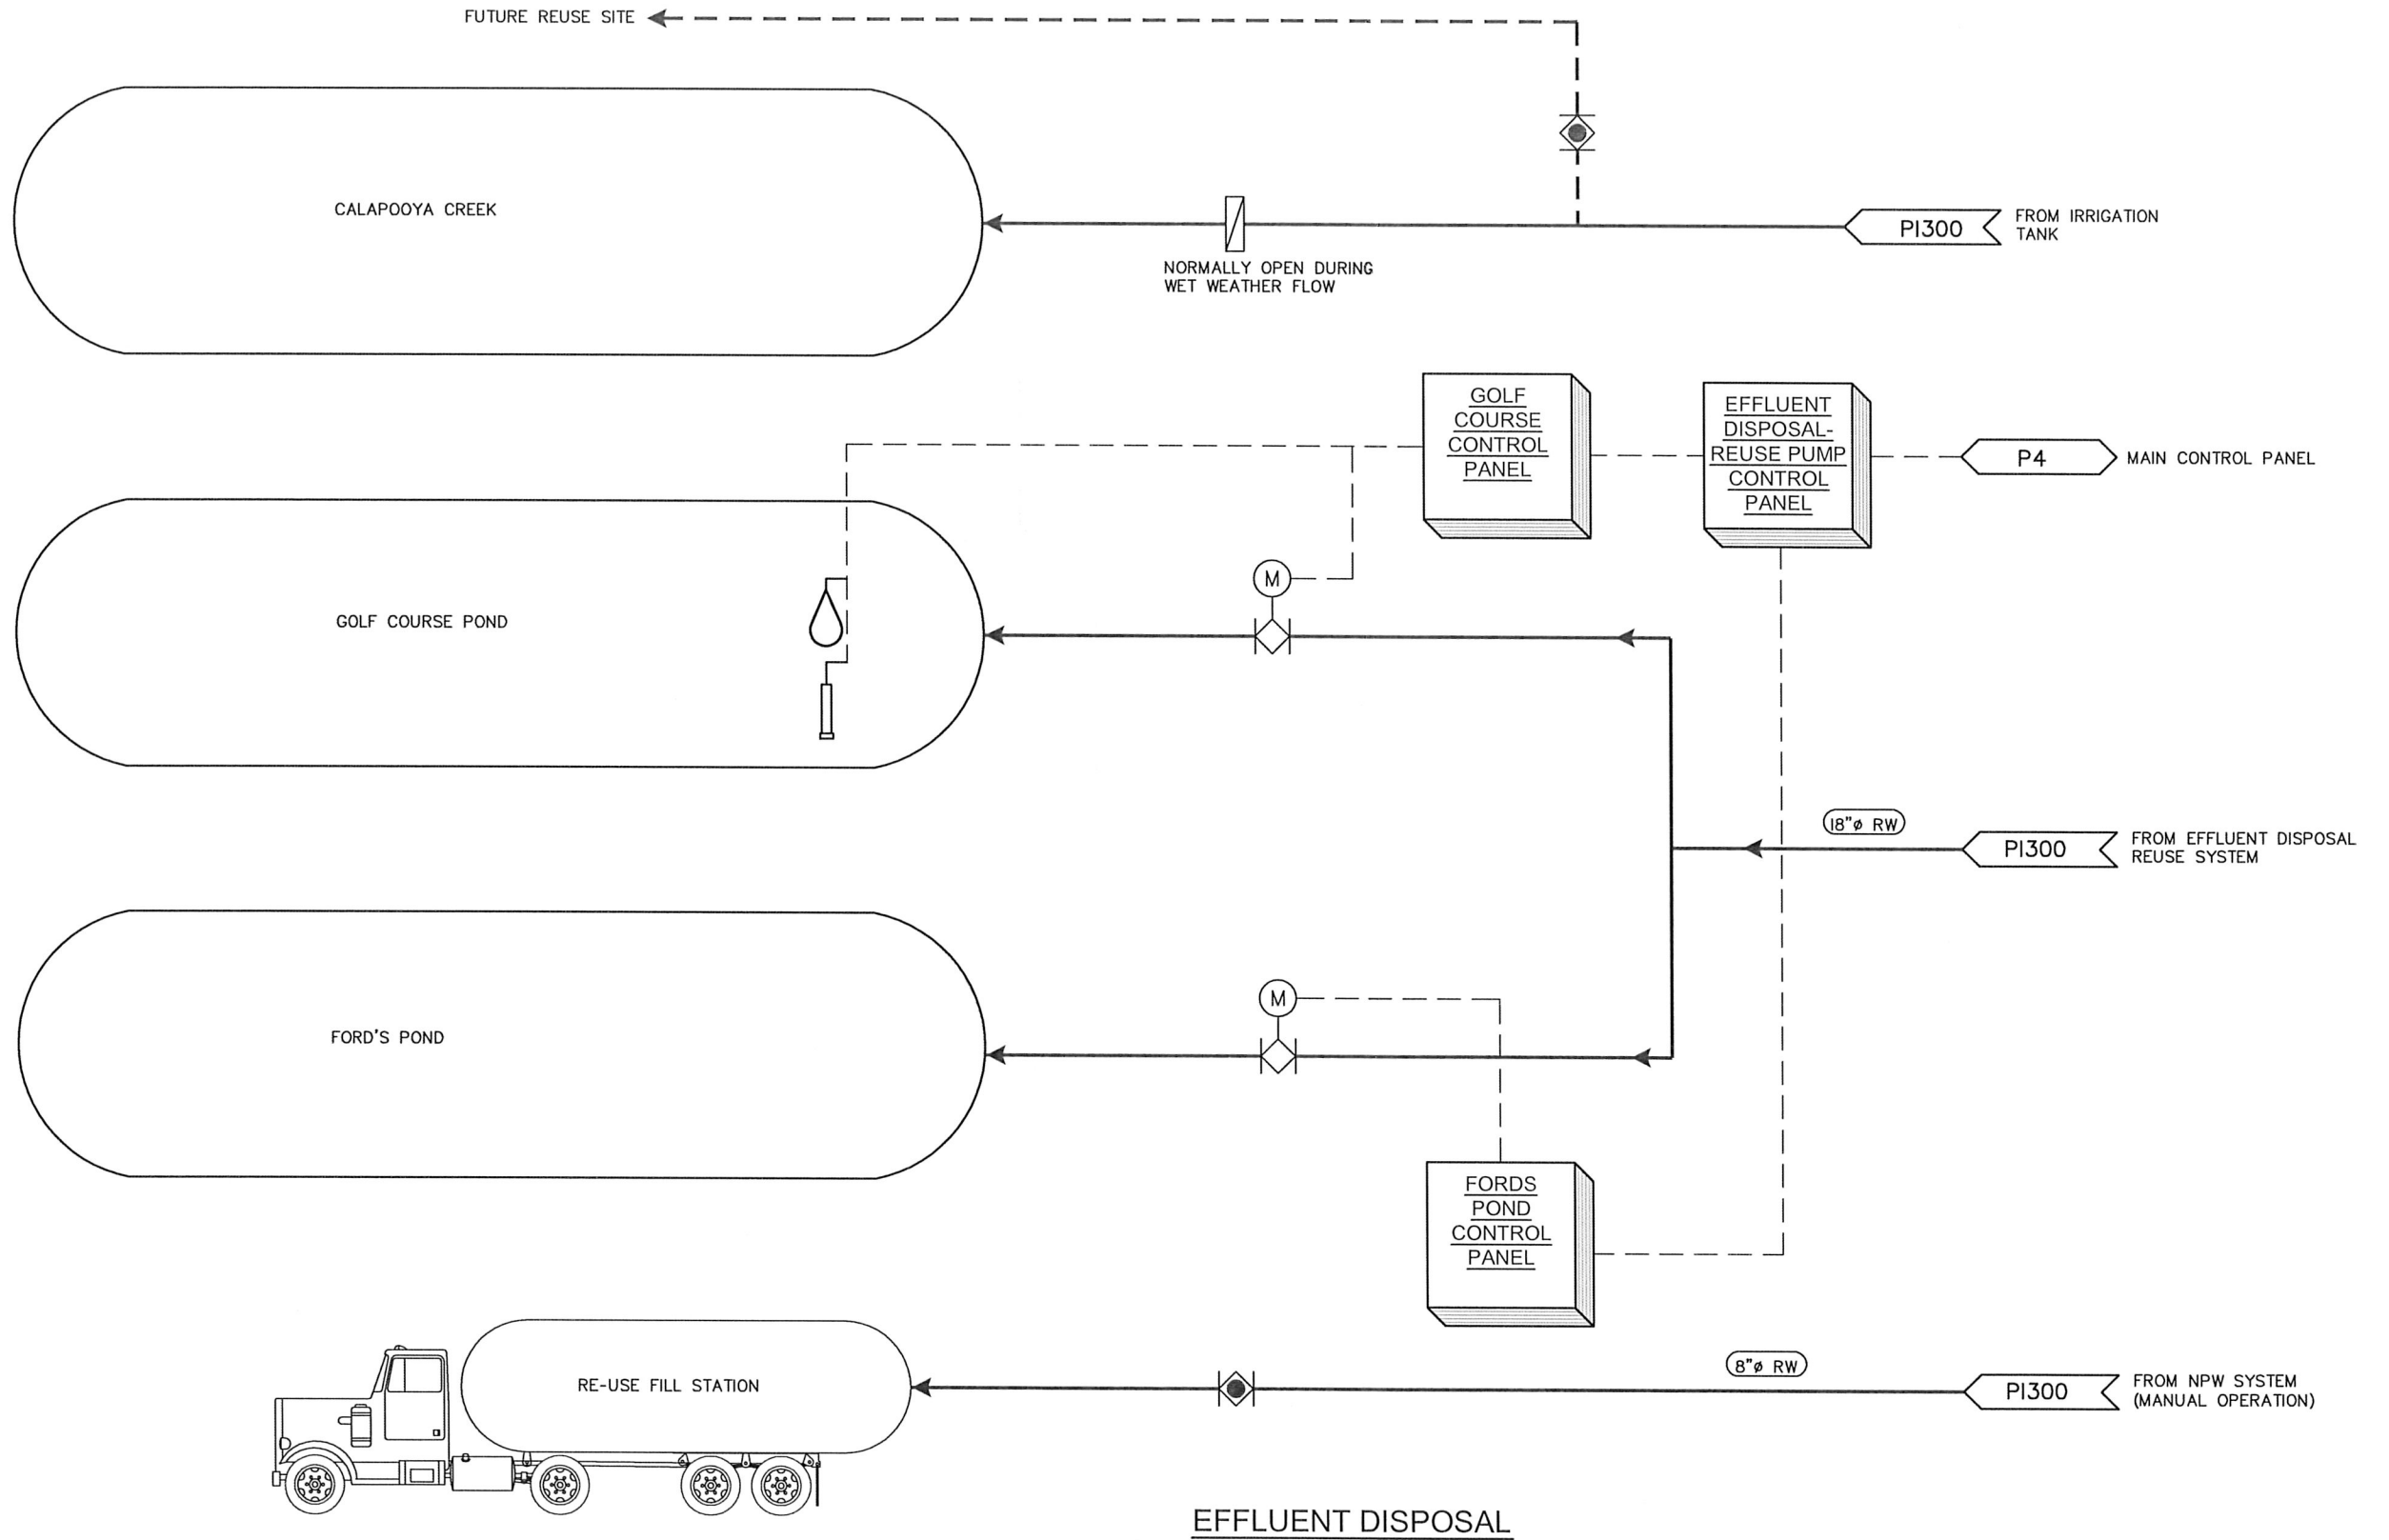

DESIGNED: _____
DRAWN: _____
APPROVED BY: _____
DATE: _____

REVISIONS					
REVISED	DESCRIPTION	SUBMIT.	APPR'D.	DATE	



THE DYER PARTNERSHIP
ENGINEERS & PLANNERS, INC.
1330 TEAKWOOD AVENUE
COOS BAY, OREGON 97420
TELEPHONE: (541) 269-0732
www.dyerpart.com


LINE IS 1 INCH
AT FULL SCALE
IF NOT 1-INCH - SCALE ACCORDINGLY

WASTEWATER TREATMENT PLANT IMPROVEMENTS
CITY OF SUTHERLIN

PROCESS
EFFLUENT DISPOSAL - REUSE

PROJECT NO.	DRAWING NO.
146.38	P1200
DATE	SHEET NO.
MAY 2016	21 OF 70

\\dye\dyer-part\AAprojects\146.38 WWT Pre-Design Report\146.38 WWT Pre-Design Report\dwg\PRE-DESIGN\PROCESS AREA 1300 SLUDGE HOLDING\PI300.dwg, 5/3/2016 2:04:23 PM May 5, 2016 PLOT DATE

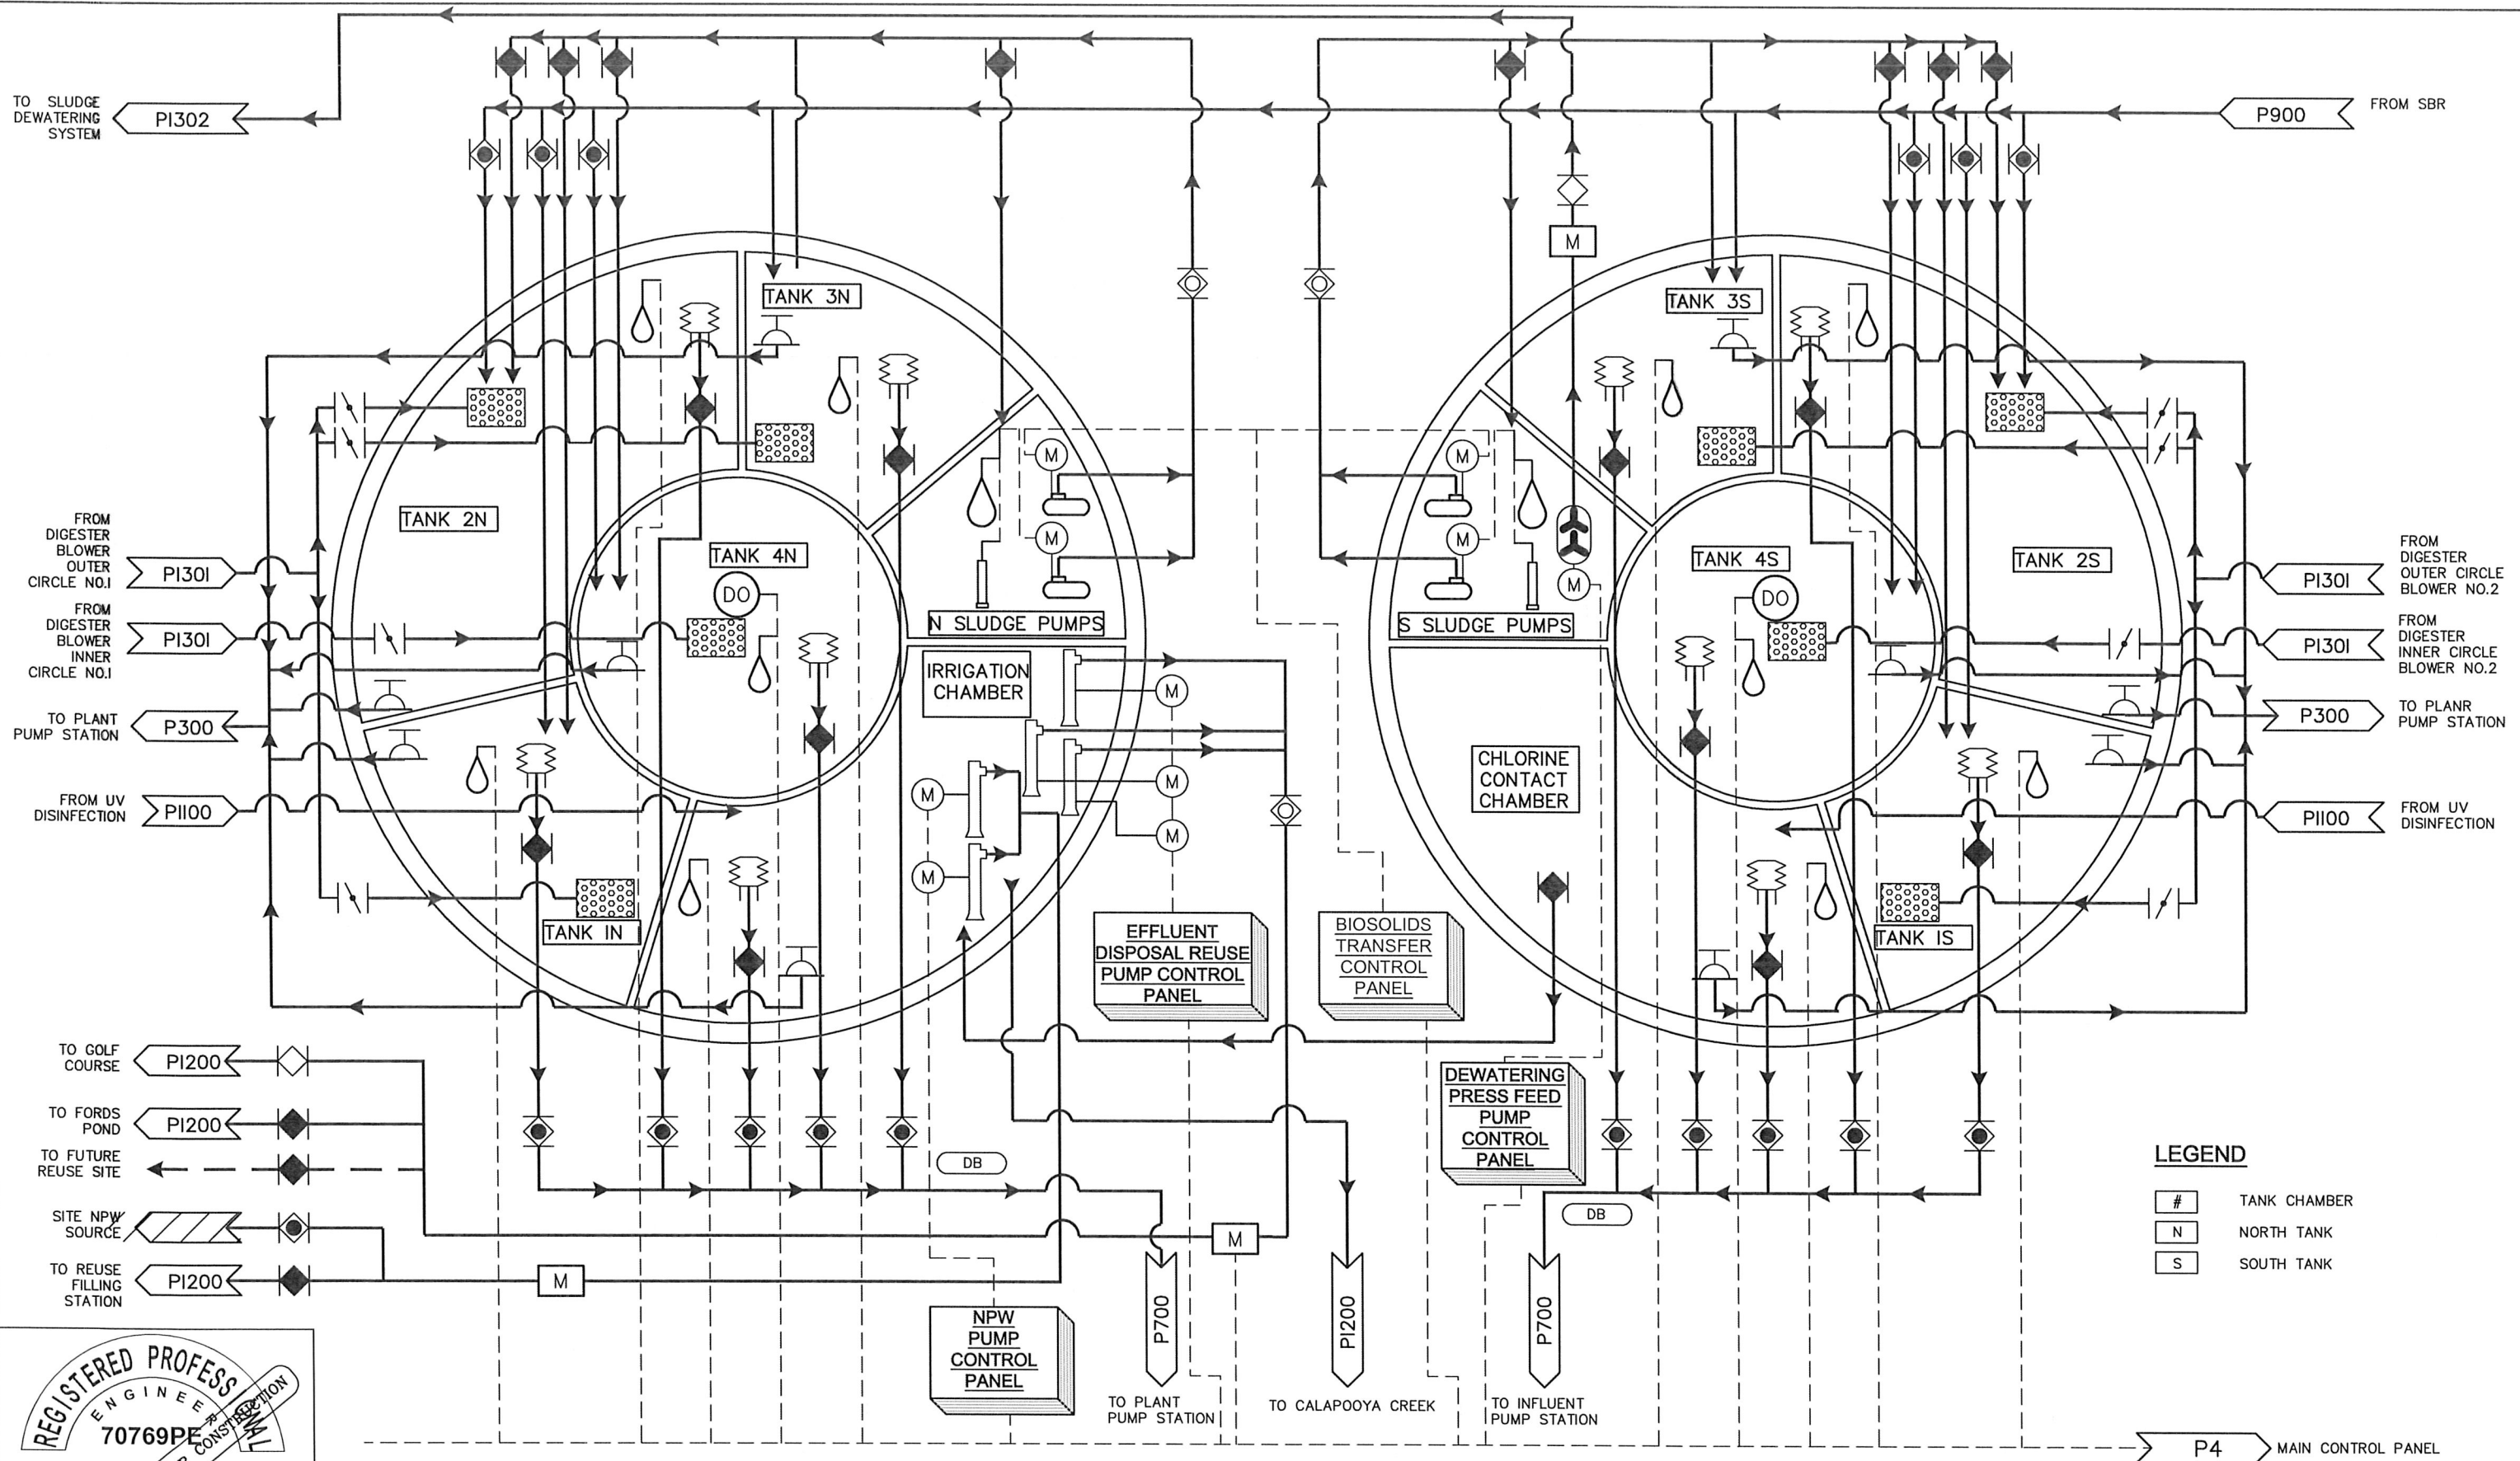

DESIGNED:	DRAWN:	REVISIONS			
----	----	REVISED	DESCRIPTION	SUBMIT	APPR'D. DATE
APPROVED BY:					
DATE:					




THE DYER PARTNERSHIP
ENGINEERS & PLANNERS, INC.
1330 TEAKWOOD AVENUE
COOS BAY, OREGON 97420
TELEPHONE: (541) 269-0732
www.dyerpart.com

LINE IS 1 INCH
AT FULL SCALE
IF NOT 1-INCH - SCALE ACCORDINGLY


WASTEWATER TREATMENT PLANT IMPROVEMENTS
CITY OF SUTHERLIN
PROCESS
BIOSOLIDS TREATMENT

PROJECT NO.	DRAWING NO.
146.38	P1300
DATE	SHEET NO.
MAY 2016	22 OF 70

\\dye\dyer-part\Aaprojects\146 Sutherlin\146.38 WWTF Pre-Design Report\dwg\PRE-DESIGN\PROCESS AREA 1300 SLUDGE HOLDING\PI301.dwg, 5/3/2016 2:06:15 PM May 5, 2016 PLOT DATE

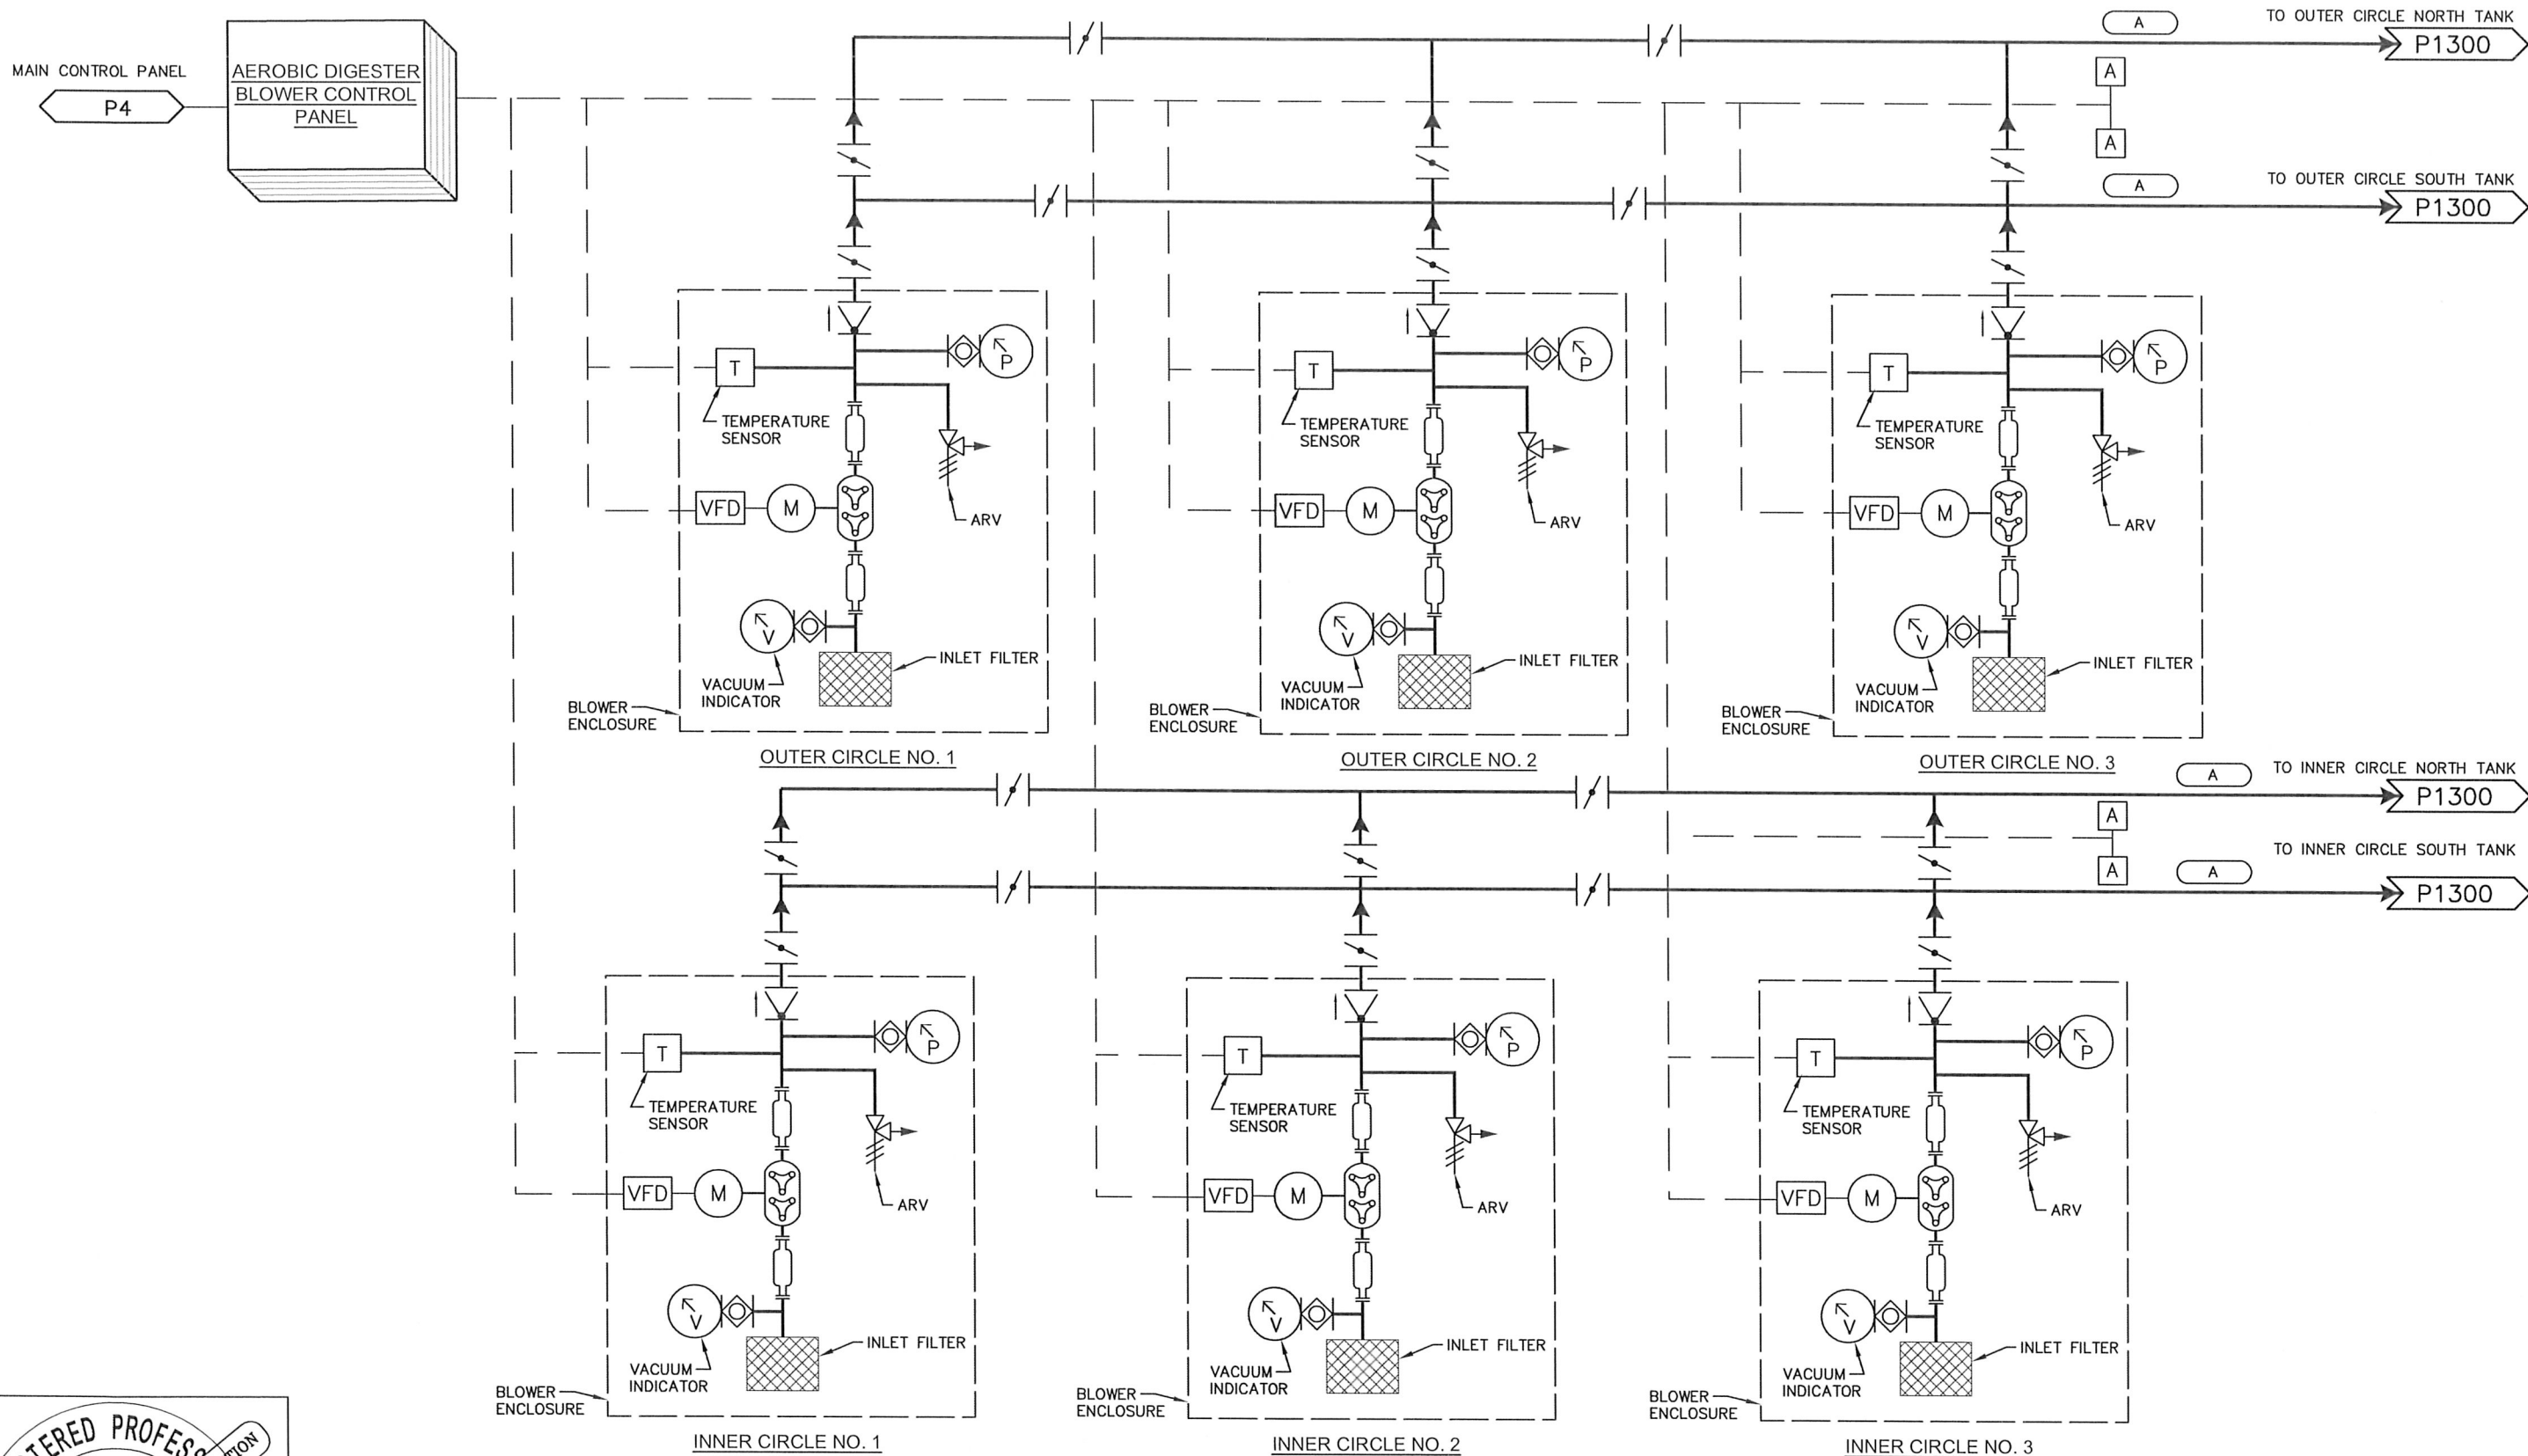

SLUDGE HOLDING TANK BLOWERS

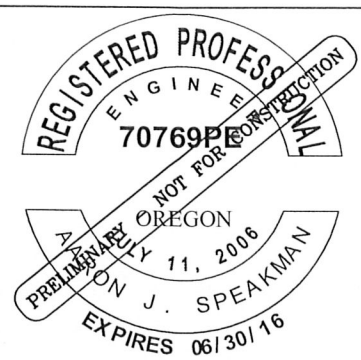

DESIGNED:	DRAWN:	REVISIONS			
---	---	REVISED	DESCRIPTION	SUBMIT.	APPR'D. DATE
APPROVED BY:					
DATE:					


D THE DYER PARTNERSHIP
ENGINEERS & PLANNERS, INC.
1330 TEAKWOOD AVENUE
COOS BAY, OREGON 97420
TELEPHONE: (541) 269-0732
www.dyerpart.com

LINE IS 1 INCH
AT FULL SCALE
IF NOT 1-INCH - SCALE ACCORDINGLY

WASTEWATER TREATMENT PLANT IMPROVEMENTS
CITY OF SUTHERLIN

PROCESS
BIOSOLIDS TREATMENT BLOWERS

PROJECT NO.	DRAWING NO.
146.38	P1301
DATE	SHEET NO.
MAY 2016	23 OF 70

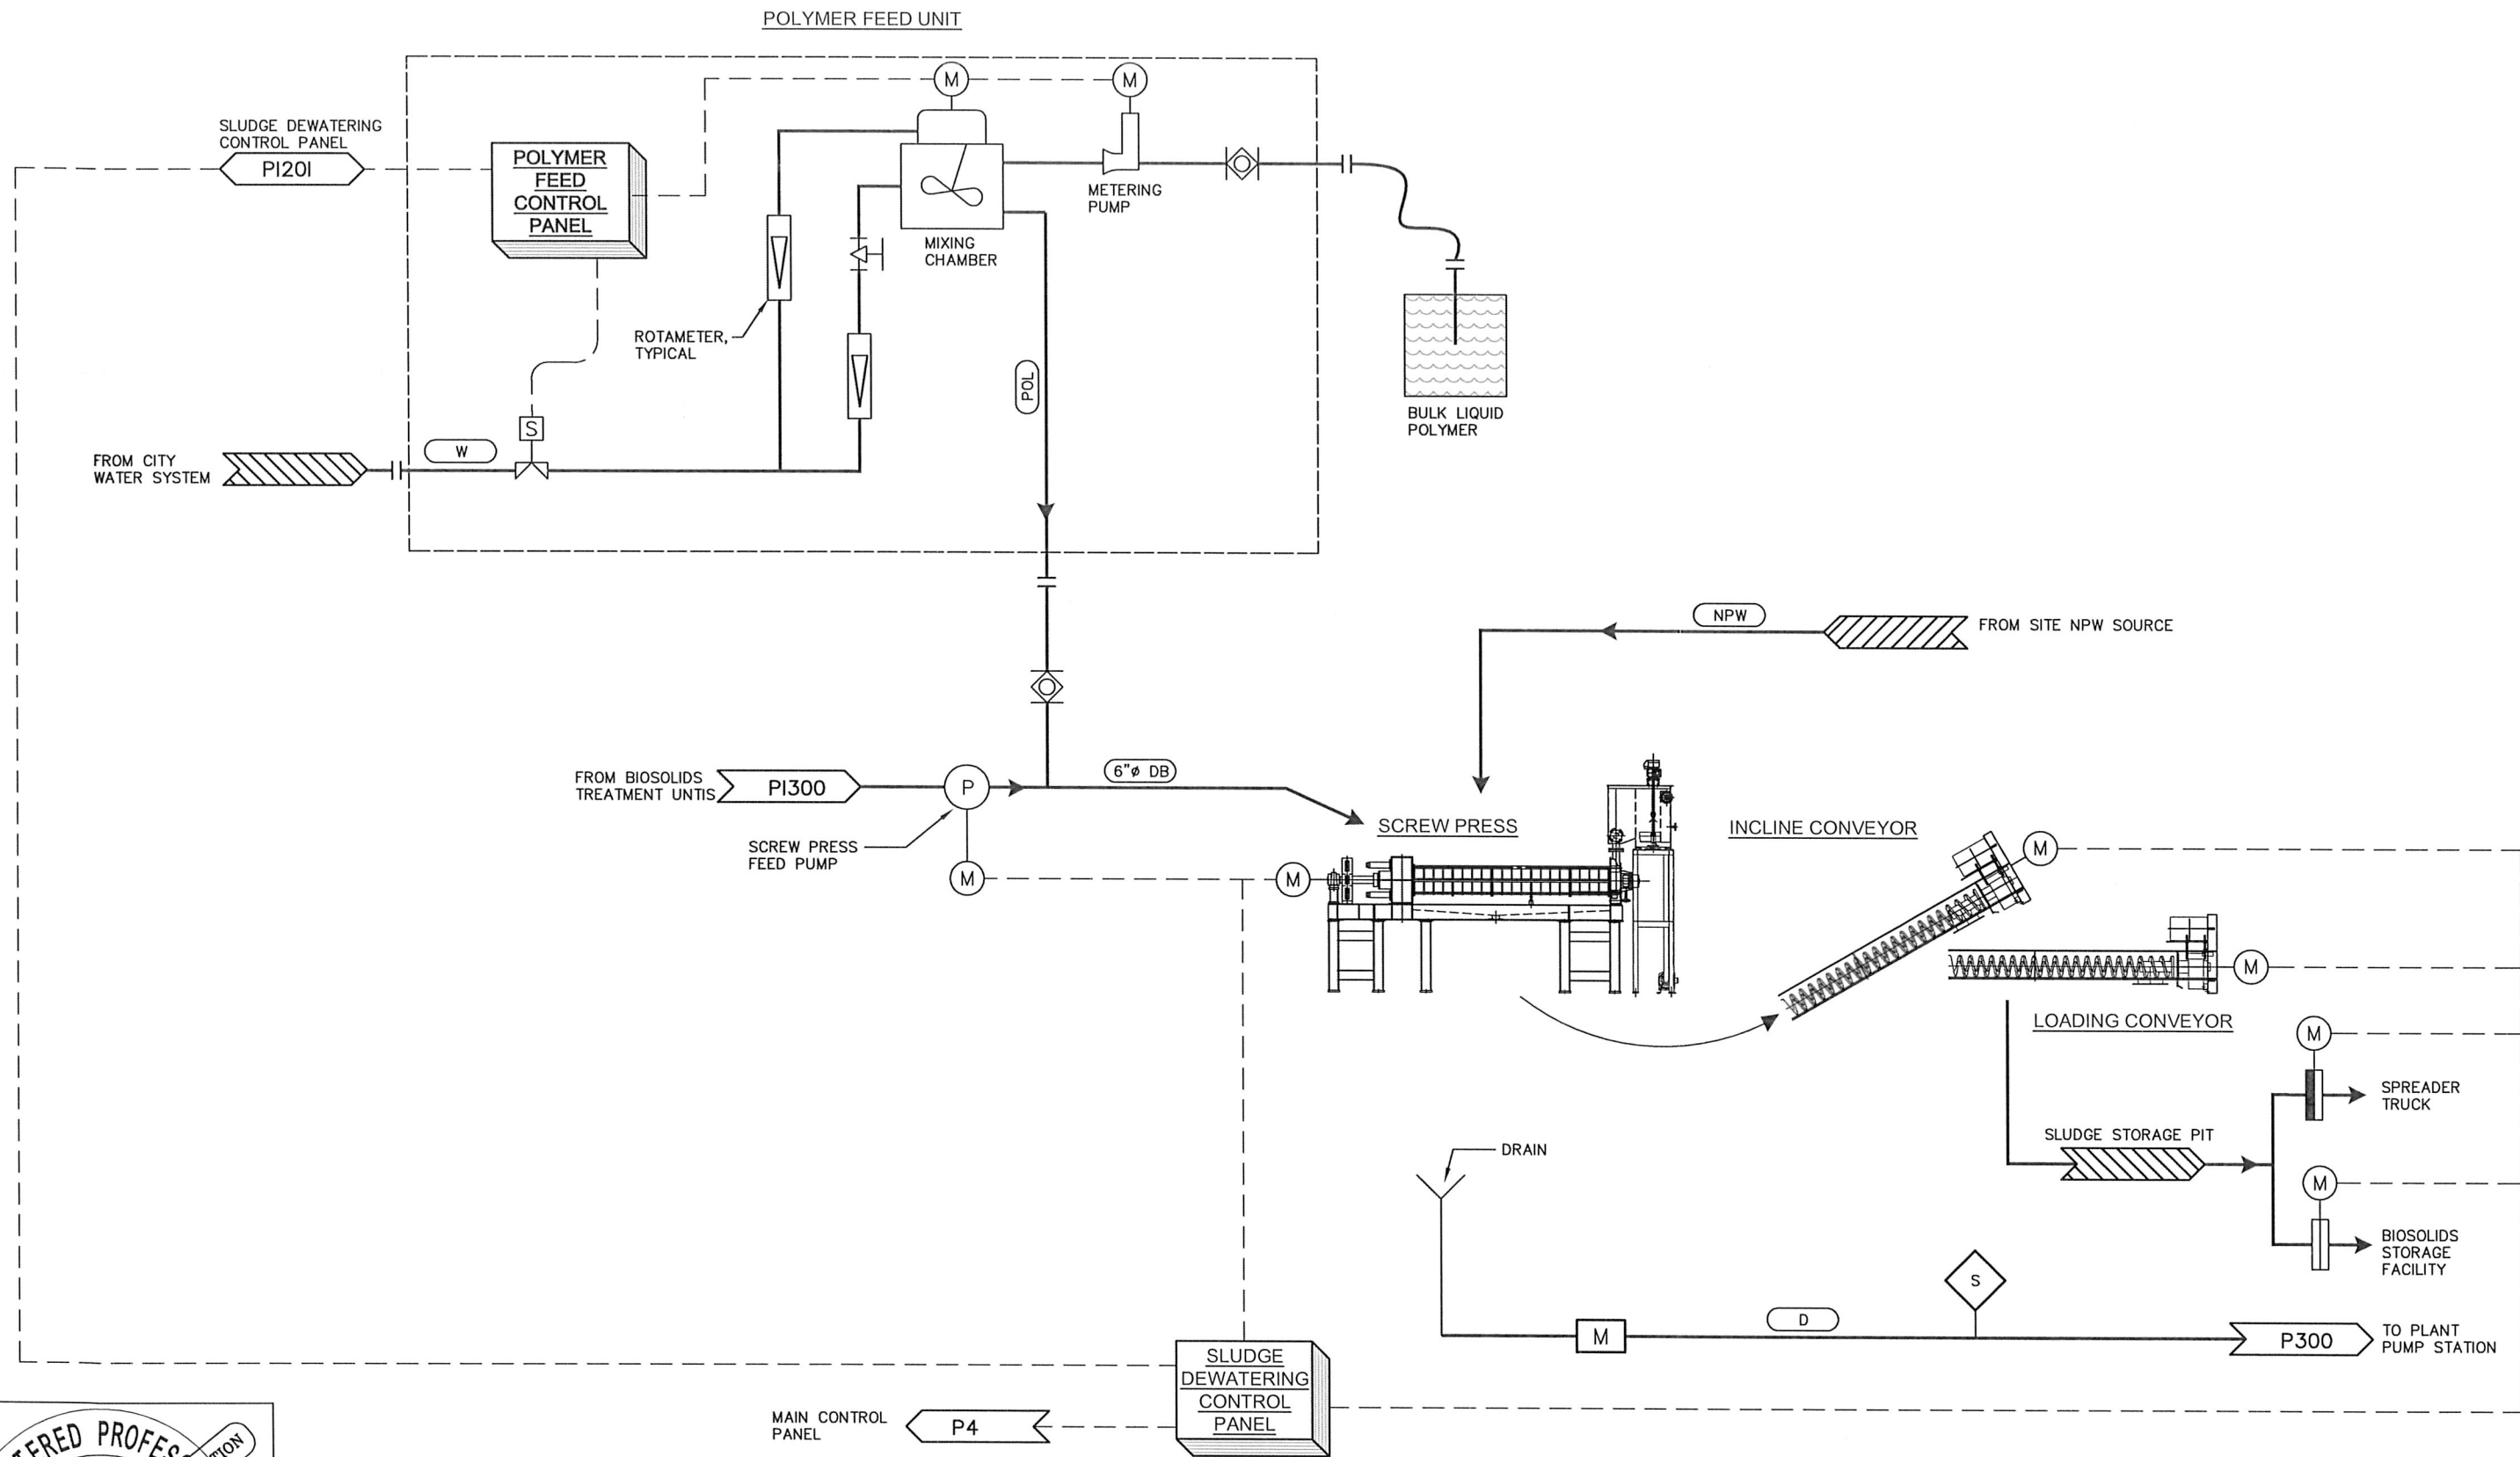

DESIGNED: _____
DRAWN: _____
APPROVED BY: _____
DATE: _____

REVISIONS				
REVISED	DESCRIPTION	SUBMIT.	APPR'D.	DATE

D THE DYER PARTNERSHIP
ENGINEERS & PLANNERS, INC.
1330 TEAKWOOD AVENUE
COOS BAY, OREGON 97420
TELEPHONE: (541) 269-0732
www.dyerport.com


LINE IS 1 INCH
AT FULL SCALE
IF NOT 1-INCH - SCALE ACCORDINGLY

**WASTEWATER TREATMENT PLANT IMPROVEMENTS
CITY OF SUTHERLIN**

**PROCESS
EFFLUENT DISPOSAL - SLUDGE DEWATERING**

PROJECT NO.	DRAWING NO.
146.38	P1302
DATE	SHEET NO.
MAY 2016	24 OF 70

\\dyer\dyer-part\A\Projects\146 Sutherlin\146.38 WWTF Pre-Design Report\dwg\PRE-DESIGN\CIVIL\SITE LAYOUT.dwg, 5/3/2016 4:39:27 PM PLOT DATE May 5, 2016

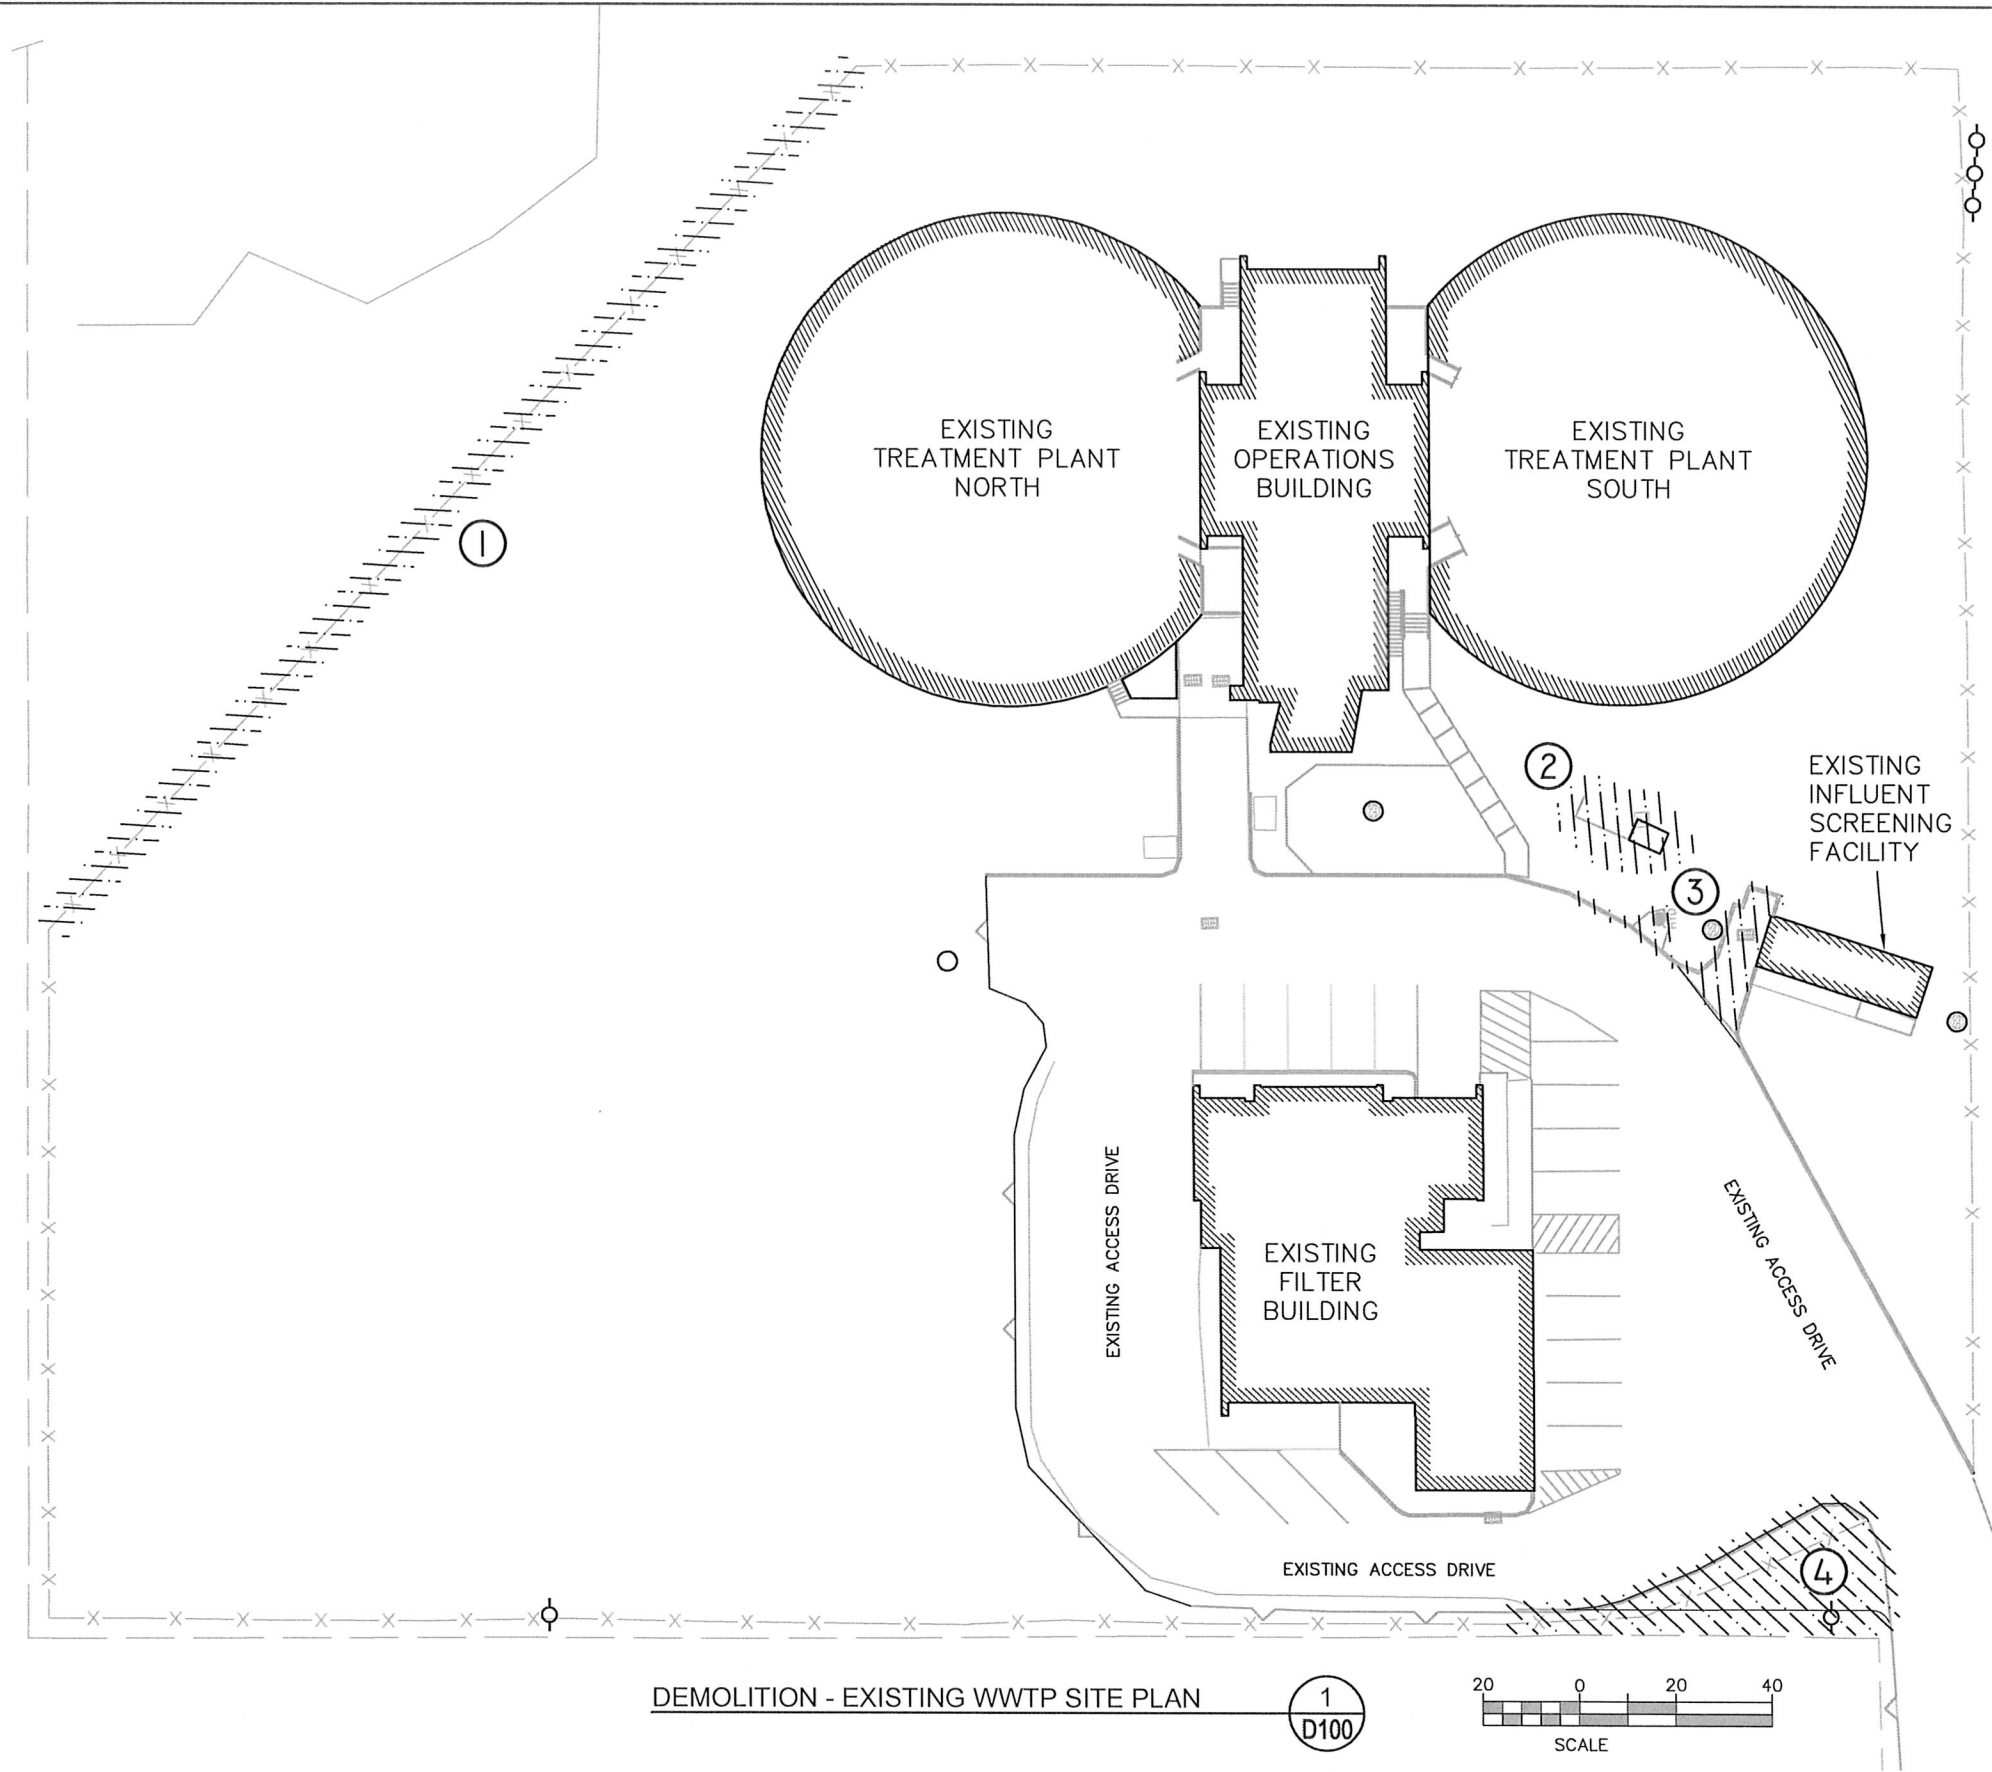

LEGEND

DEMO EXISTING

- NO. DEMOLITION NOTES
- 1

CHAIN-LINK FENCE; REMOVE EXISTING FENCE AND SALVAGE TO OWNER FOR REUSE.
- 2

VAULT; REMOVE AND RELOCATE EXISTING VAULT.
- 3

CONC. SIDEWALK; REMOVE EXISTING CONCRETE SIDEWALK. DISPOSE OF DEBRIS.
CURB; REMOVE EXISTING CURB. DISPOSE OF DEBRIS.
FIRE HYDRANT; REMOVE AND RELOCATE EXISTING FIRE HYDRANT.
- 4

CHAIN-LINK FENCE; REMOVE EXISTING FENCE AND SALVAGE TO OWNER FOR REUSE.
CURB; REMOVE EXISTING CURB. DISPOSE OF DEBRIS.

 
 
- GENERAL DEMOLITION NOTES:
1.

THIS DEMOLITION PLAN ILLUSTRATES DEMOLITION WORK REQUIRED FOR THE COMPLETION OF THIS PROJECT. THE NUMERICAL ORDER PRESENTED BELOW DOES NOT REPRESENT A DEMOLITION SEQUENCE. REFER TO PROJECT SPECIFICATIONS FOR INFORMATION REGARDING SEQUENCE OF WORK AND RELATED WORK CONSTRAINTS REGARDING ON SITE DEMOLITION.
2.

COORDINATE WORK WITH SECTION 01014.

DEMOLITION - EXISTING WWTP SITE PLAN

1
D100



<u>DESIGNED:</u> _____	<u>DRAWN:</u> _____	<u>REVISIONS</u>				
		REVISED	DESCRIPTION	SUBMIT.	APPR'D.	DATE
					</	

THE DYER PARTNERSHIP
ENGINEERS & PLANNERS, INC.
1330 TEAKWOOD AVENUE
COOS BAY, OREGON 97420
TELEPHONE: (541) 269-0732
www.dyerpart.com

LINE IS 1 INCH
AT FULL SCALE
IF NOT 1-INCH - SCALE ACCORDINGLY

WASTEWATER TREATMENT PLANT IMPROVEMENTS CITY OF SUTHERLIN		PROJECT NO. 146.38	DRAWING NO. D100
DEMOLITION EXISTING SITE		DATE MAY 2016	SHEET NO. 25 OF 70

\\dye-er-part\A\projects\146 Sutherlin\146.38 WWTf Pre-Design Report\dwg\PRE-DESIGN\DEMO\OPS BLDG.dwg, 11/30/2015 5:08:41 PM PLOT DATE May 5, 2016

LEGEND

DEMO EXISTING

EXISTING WALL TO REMAIN, TYPICAL BLDG. / DIGESTER

- NO. DEMOLITION NOTES
- 1

FILTER: REMOVE EXISTING 26' I.D. 3 CELL FILTER, EQUIPMENT, AND PIPING TO FIN. FLR. PLUG AND ABANDON IN PLACE.
- 2


SPLITTER BOX: REMOVE EXISTING SPLITTER BOX, SUPPORTS, EQUIPMENT, AND PIPING TO FIN. FLR. PLUG AND ABANDON IN PLACE.
- 3

BUILDING: REMOVE EXISTING WALL TO ALLOW EXISTING EQUIPMENT REMOVAL AND INSTALLATION OF NEW EQUIPMENT. OPENING SIZE TO BE DETERMINED.
- 4

BUILDING: REMOVE EXISTING WALL TO ALLOW INSTALLATION OF NEW EXHAUST FAN. OPENING SIZE TO BE DETERMINED.
- 5

BUILDING: REMOVE EXISTING WINDOW ABOVE TO ALLOW INSTALLATION OF NEW SUPPLY AIR GRILL. OPENING SIZE TO BE DETERMINED.
- 6

MISCELLANEOUS: REMOVE ALL WATERLINES, AIRLINES, AND CONDUIT ASSOCIATED WITH THE OPERATION OF THE BLOWERS FROM THE FILTER TO PLACE OF ORIGIN.

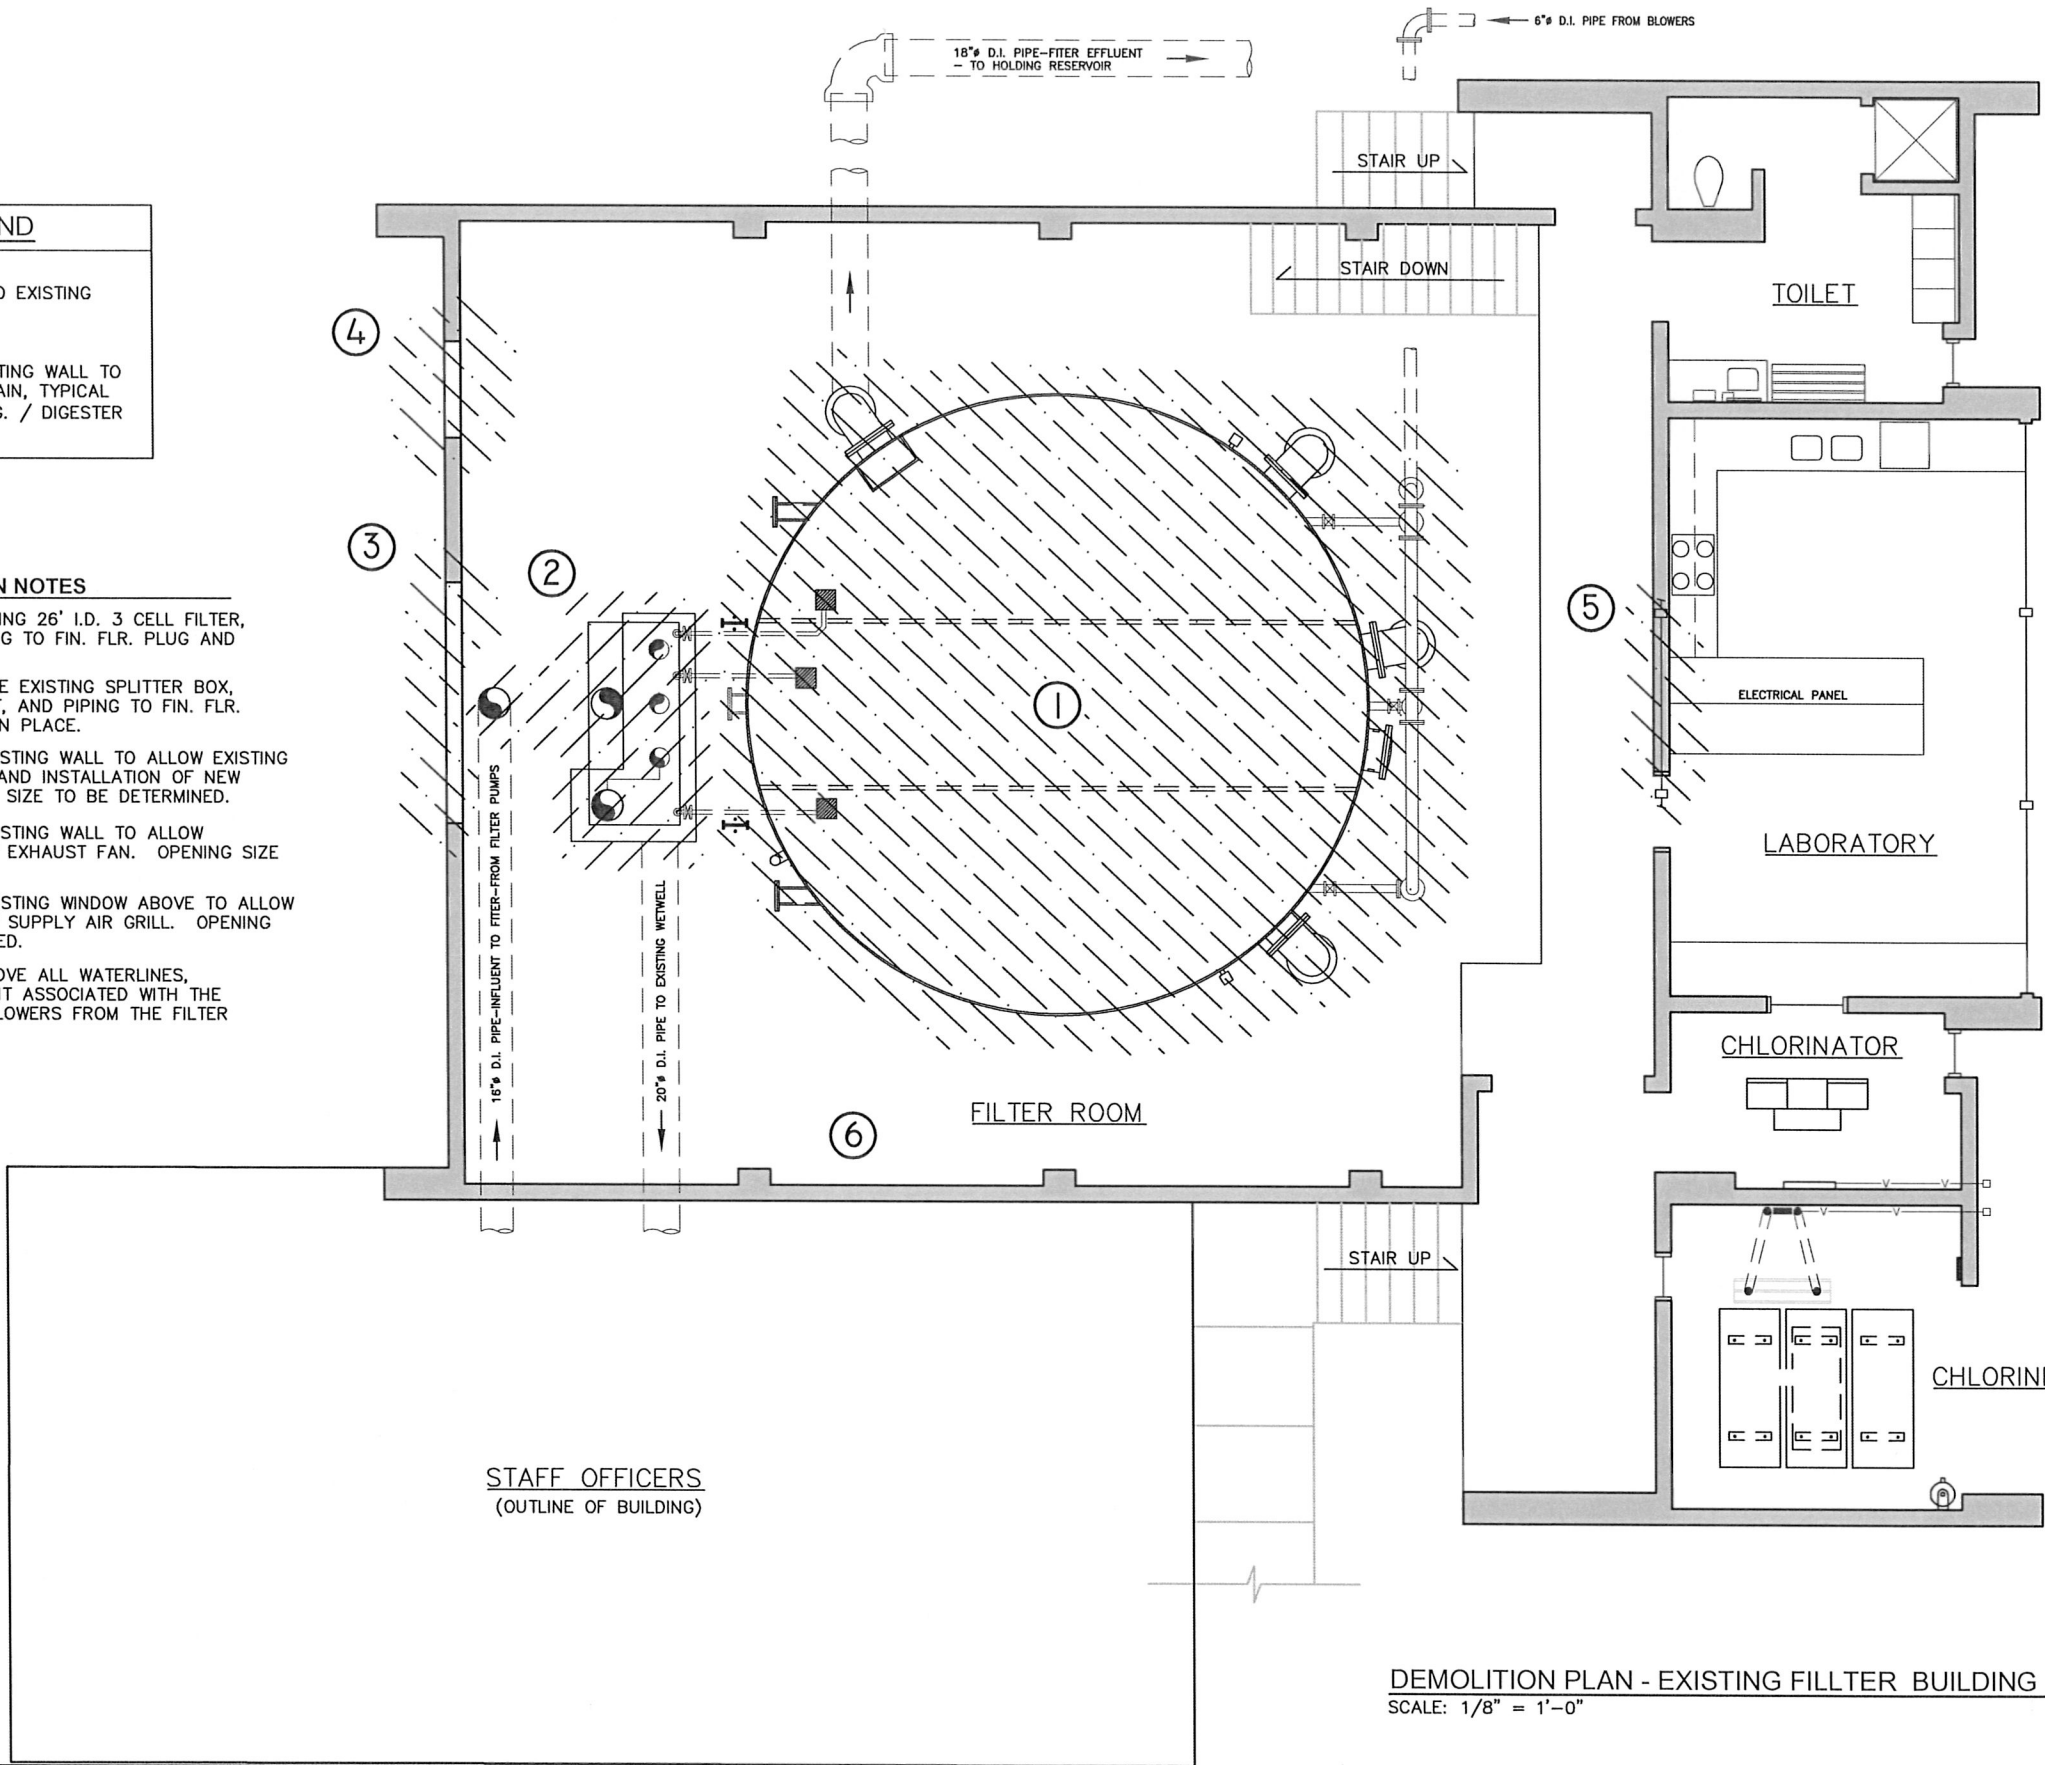

REGISTERED PROFESSIONAL ENGINEER

70769

PRELIMINARY NOT FOR CONSTRUCTION

OREGON

J. SPEAKMAN

EXPIRES 06/30/16

DESIGNED:	DRAWN:	REVISIONS			
----	----	REVISED	DESCRIPTION	SUBMIT, APPR'D.	DATE
APPROVED BY:					
DATE:					


D

THE DYER PARTNERSHIP
ENGINEERS & PLANNERS, INC.
1330 TEAKWOOD AVENUE
COOS BAY, OREGON 97420
TELEPHONE: (541) 269-0732
www.dyerpart.com

LINE IS 1 INCH
AT FULL SCALE
IF NOT 1-INCH - SCALE ACCORDINGLY

WASTEWATER TREATMENT PLANT IMPROVEMENTS CITY OF SUTHERLIN		PROJECT NO. 146.38	DRAWING NO. D200
DEMOLITION EXISTING FILTER BUILDING		DATE MAY 2016	SHEET NO. 26 OF 70

\\dyer\dyer-part\A\projects\146 Sutherland\146.38 WWTF Pre-Design Report\dwg\PRE-DESIGN\DEMO OPS BLDG.dwg, 11/30/2015 5:08:41 PM PLOT DATE May 5, 2016

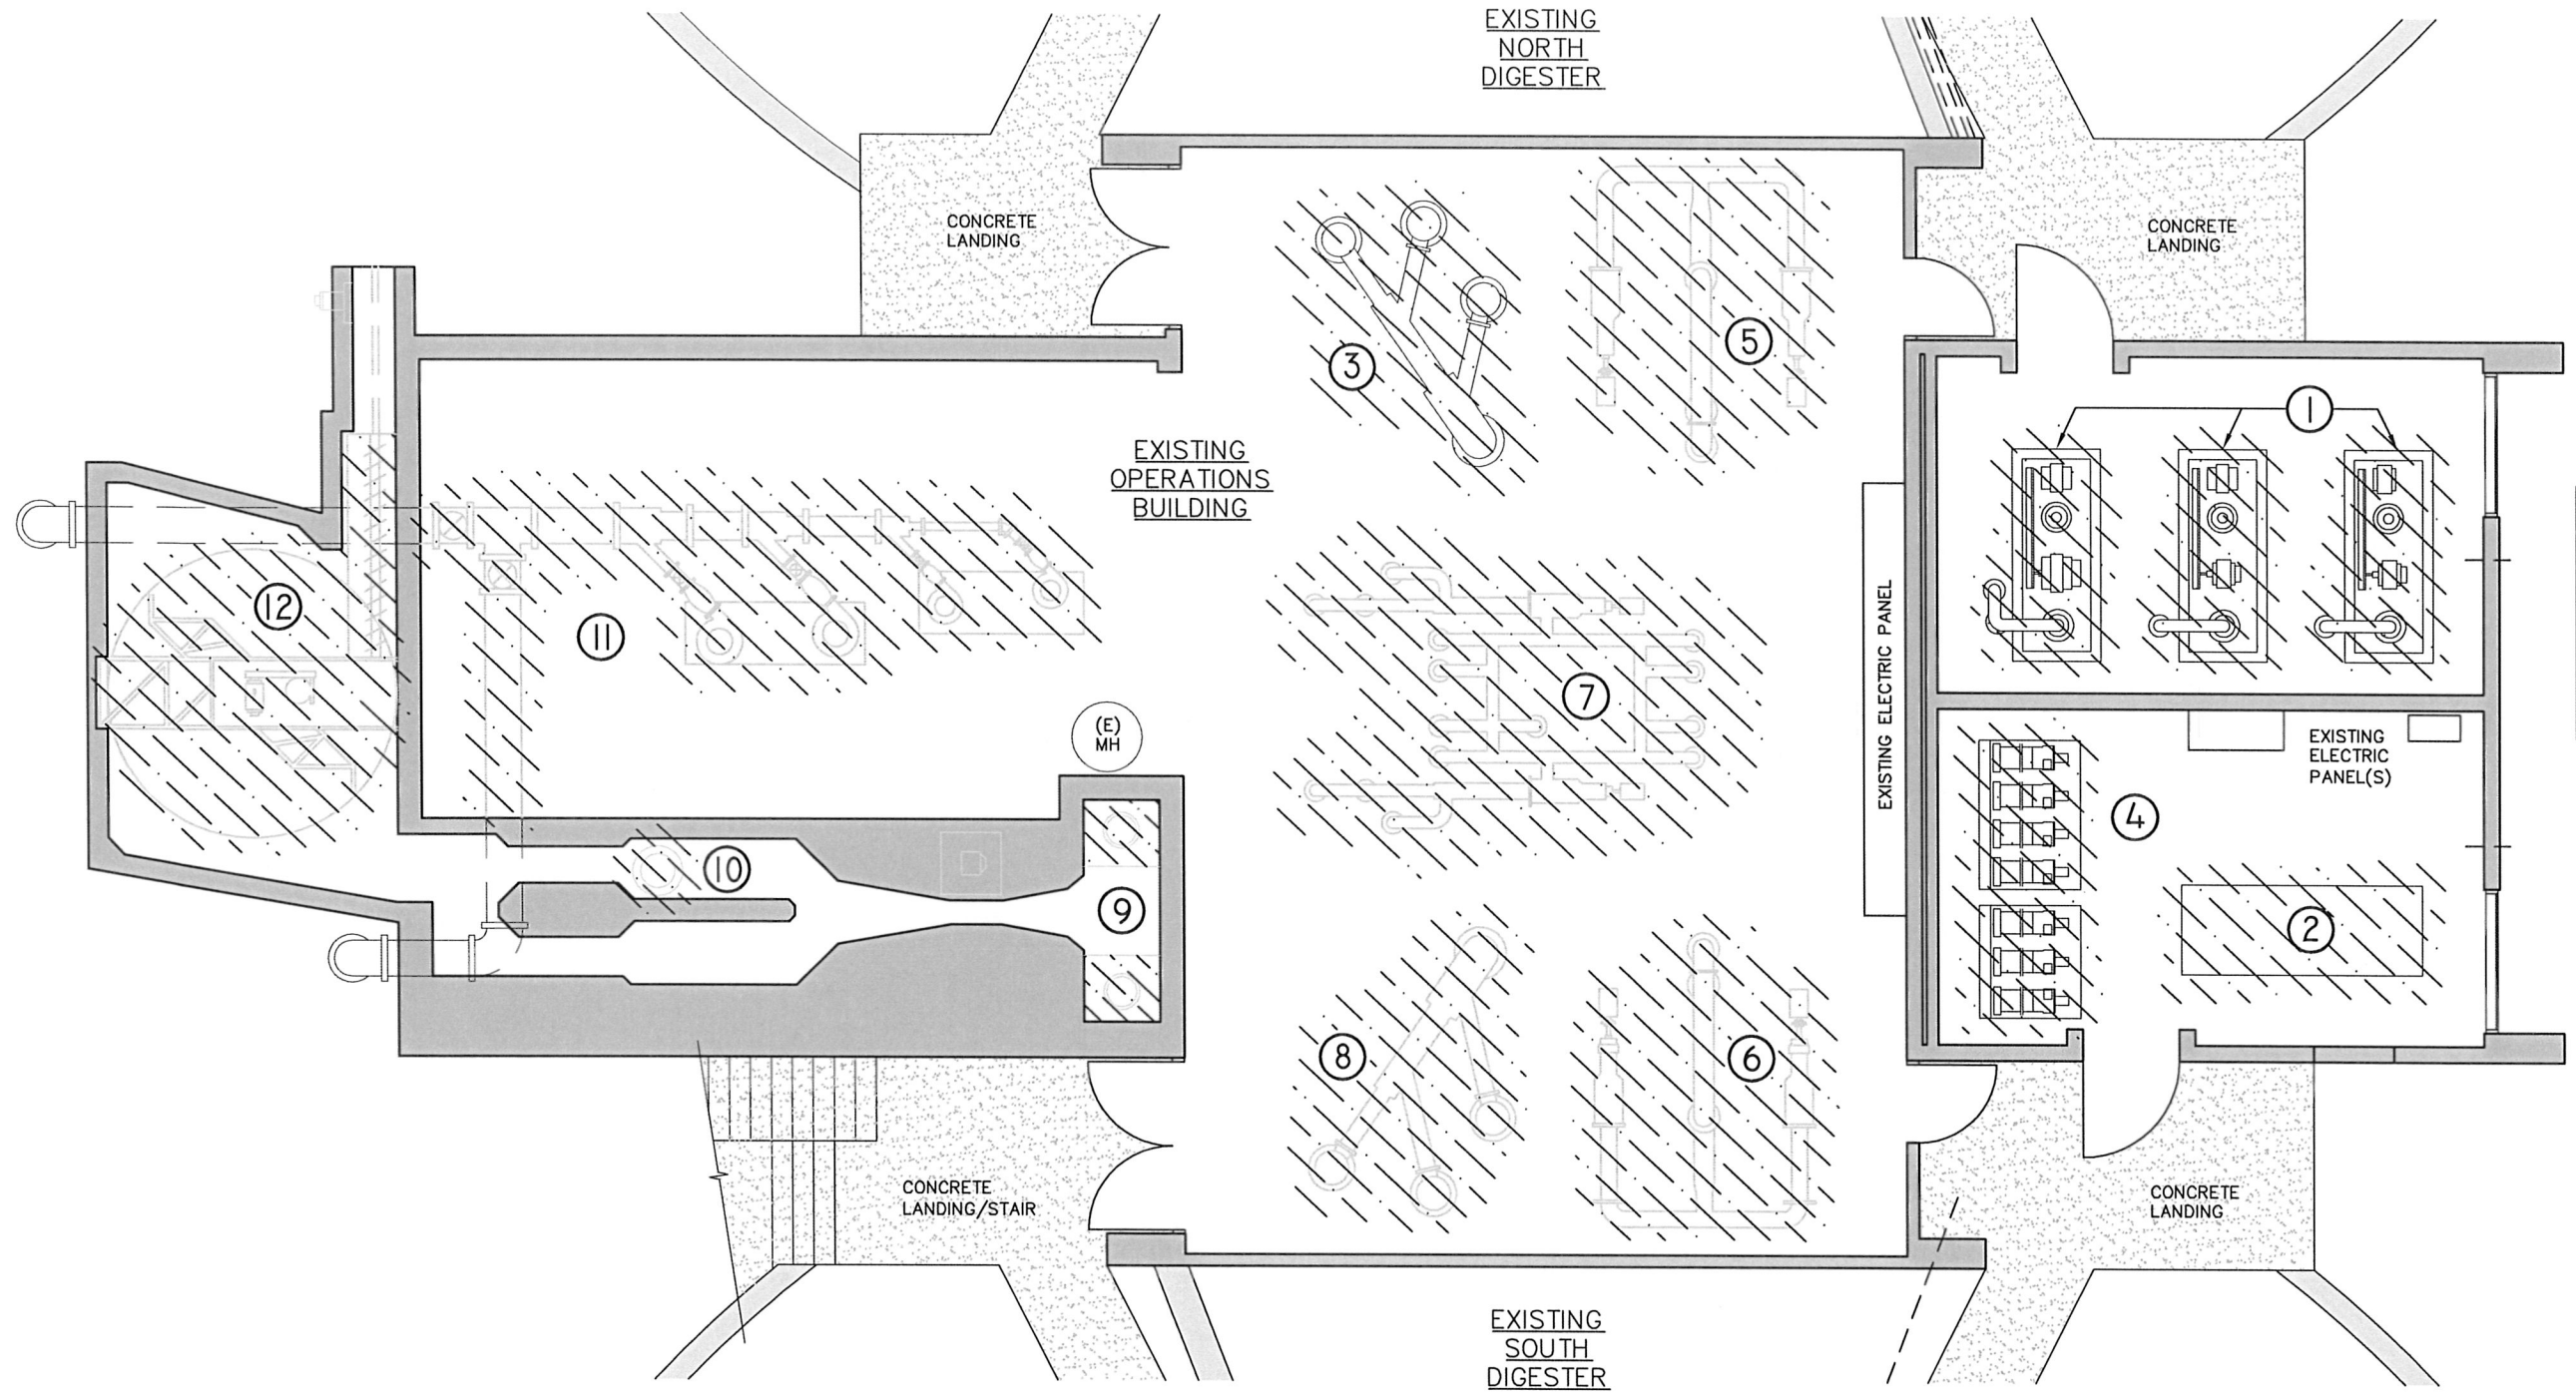

LEGEND

DEMO EXISTING

EXISTING WALL TO REMAIN, TYPICAL BLDG. / DIGESTER

NO. DEMOLITION NOTES

- | | | |
|---|--|---|
| ① BLOWERS: REMOVE AND REPLACE EXISTING BLOWER. | ⑤ RAS PUMP NORTH: REMOVE EXISTING PUMPS AND PIPING TO FINISH FLOOR. | ⑨ FLOW SPLITTER: PLUG AND ABANDON. |
| ② GENERATOR: REMOVE AND REPLACE EXISTING GENERATOR. | ⑥ RAS PUMP SOUTH: REMOVE EXISTING PUMPS AND PIPING TO FINISH FLOOR. | ⑩ COMMINUTOR: REMOVE EXISTING. |
| ③ REUSE PUMPS: REMOVE AND REPLACE EXISTING IRRIGATION PUMPS. | ⑦ SCUM PUMP: REMOVE EXISTING PUMPS AND PIPING TO FINISH FLOOR. | ⑪ INFLUENT PUMP: REMOVE EXISTING PUMPS AND PIPING TO FINISH FLOOR. |
| ④ REUSE PUMP: REMOVE. | ⑧ FILTER PUMP: REMOVE EXISTING PUMPS AND PIPING TO FINISH FLOOR. | ⑫ GRIT AND REMOVAL SYSTEM: REMOVE EXISTING. |

DEMOLITION PLAN - EXISTING OPERATIONS BUILDING
SCALE: 1/8" = 1'-0"

1
D300

NOTE:
1. SEE M1300 FOR EXISTING PIPING TO REMAIN
2. REMOVE ALL EQUIPMENT AND PIPE CONCRETE PADS TO FINISH FLOOR ELEVATION
3. DEMOLITION THIS BUILDING CAN NOT START UNTIL NEW TREATMENT SYSTEM IS OPERATIONAL.




DESIGNED:	DRAWN:	REVISIONS			
----	----	REVISED	DESCRIPTION	SUBMIT.	APPR'D. DATE
APPROVED BY:					
DATE:					

D THE DYER PARTNERSHIP
ENGINEERS & PLANNERS, INC.
1330 TEAKWOOD AVENUE
COOS BAY, OREGON 97420
TELEPHONE: (541) 269-0732
www.dyerpart.com


LINE IS 1 INCH
AT FULL SCALE
IF NOT 1-INCH - SCALE ACCORDINGLY

WASTEWATER TREATMENT PLANT IMPROVEMENTS CITY OF SUTHERLIN		PROJECT NO. 146.38	DRAWING NO. D300
DEMOLITION EXISTING OPERATIONS BUILDING		DATE MAY 2016	SHEET NO. 27 OF 70

\\dyer\dyer-part\Aprojects\146 Sutherlin\146.38 WWTF Pre-Design Report\dwg\PRE-DESIGN\DEMO OPS BLDG.dwg, 11/30/2015 5:08:41 PM PLOT DATE May 5, 2016

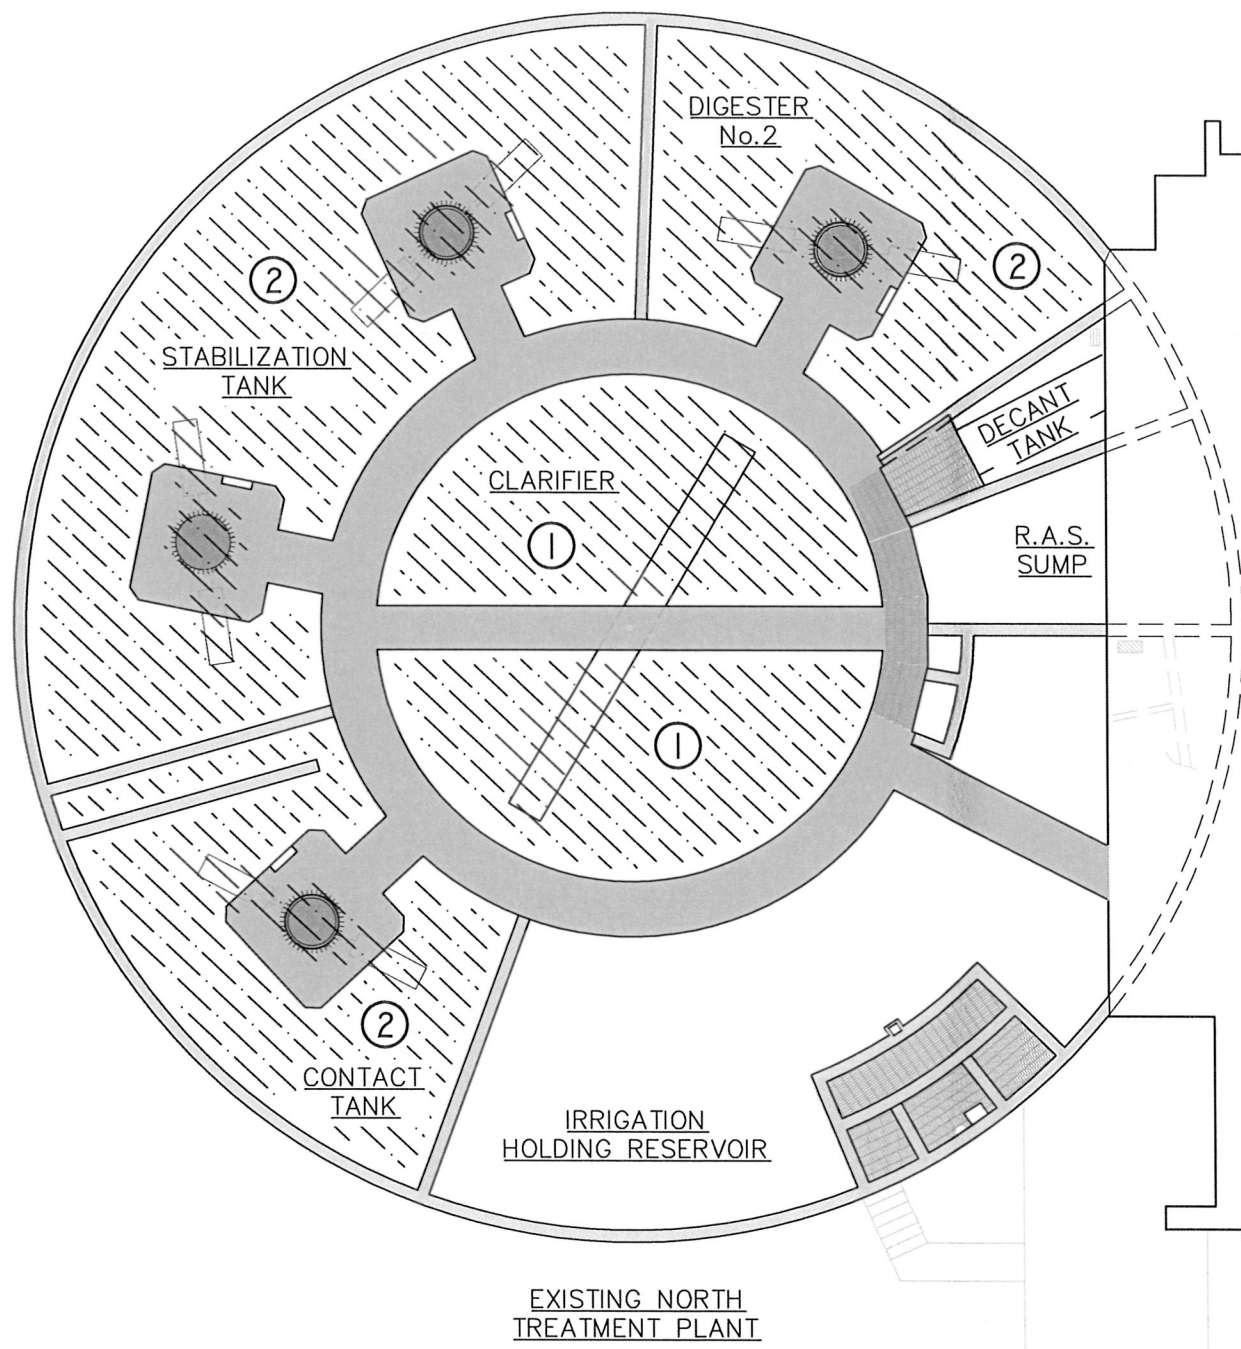

GENERATOR FUEL TANK ③

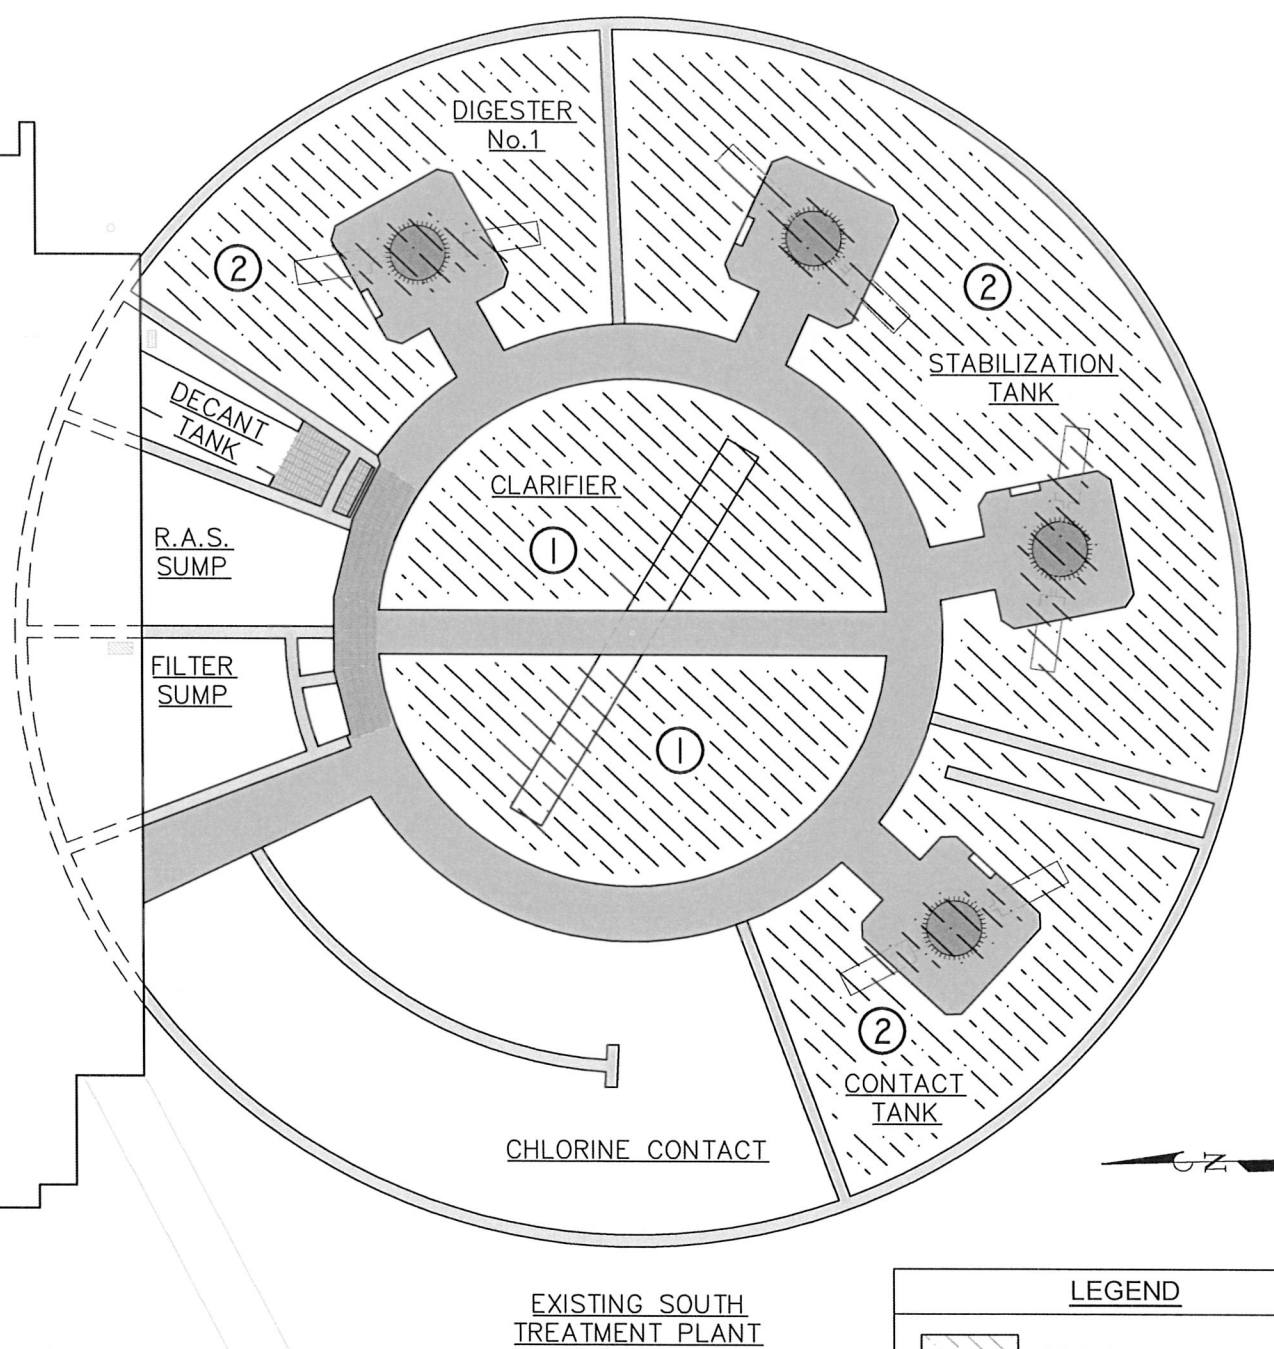

- NO. DEMOLITION NOTES**
- ① **CLARIFIER:** REMOVE ALL EXISTING CLAIRIFIER, EQUIPMENT, AND PIPING TO FIN. FLR. PLUG AND ABANDON IN PLACE.
 - ② **AERATION:** REMOVE EXISTING PIPING, SUPPORTS, AND EQUIPMENT TO FIN. FLR. PLUG AND ABANDON IN PLACE.
MIXER: REMOVE EXISTING MIXER, EQUIPMENT, AND PIPING TO FIN. FLR. PLUG AND ABANDON IN PLACE.
 - ③ **FUEL TANK:** REMOVE EXISTING FUEL TANK, PIPING, SUPPORTS, AND EQUIPMENT TO BE RELOCATED.

- NOTE:**
- 1. SEE M1300 FOR EXISTING PIPING TO REMAIN
 - 2. REMOVE ALL CONDUITS NOT TO BE USED FOR FUTURE.
 - 3. DEMOLITION OF TREATMENT UNITS CAN NOT START UNTIL NEW TREATMENT SYSTEM IS OPERATIONAL.

LEGEND

- DEMO EXISTING
- EXISTING WALL / ACCESS TO REMAIN, TYPICAL.

DEMOLITION PLAN - EXISTING TREATMENT PLANT (NORTH & SOUTH)
SCALE: 1/8" = 1'-0"



DESIGNED:	DRAWN:
---	---
APPROVED BY:	
DATE:	


REVISIONS				
REVISED	DESCRIPTION	SUBMIT.	APPR'D.	DATE

D THE DYER PARTNERSHIP
ENGINEERS & PLANNERS, INC.
1330 TEAKWOOD AVENUE
COOS BAY, OREGON 97420
TELEPHONE: (541) 269-0732
www.dyerpart.com

LINE IS 1 INCH
AT FULL SCALE
IF NOT 1-INCH - SCALE ACCORDINGLY

WASTEWATER TREATMENT PLANT IMPROVEMENTS CITY OF SUTHERLIN		PROJECT NO. 146.38	DRAWING NO. D1300
DEMOLITION EXISTING TREATMENT PLANT		DATE MAY 2016	SHEET NO. 28 OF 70

\\dye\dyer-part\AA\projects\146 Sutherlin\146.38 WWTF Pre-Design Report\dwg\PRE-DESIGN\CIVIL\SITE LAYOUT.dwg, 5/3/2016 4:39:27 PM PLOT DATE May 5, 2016

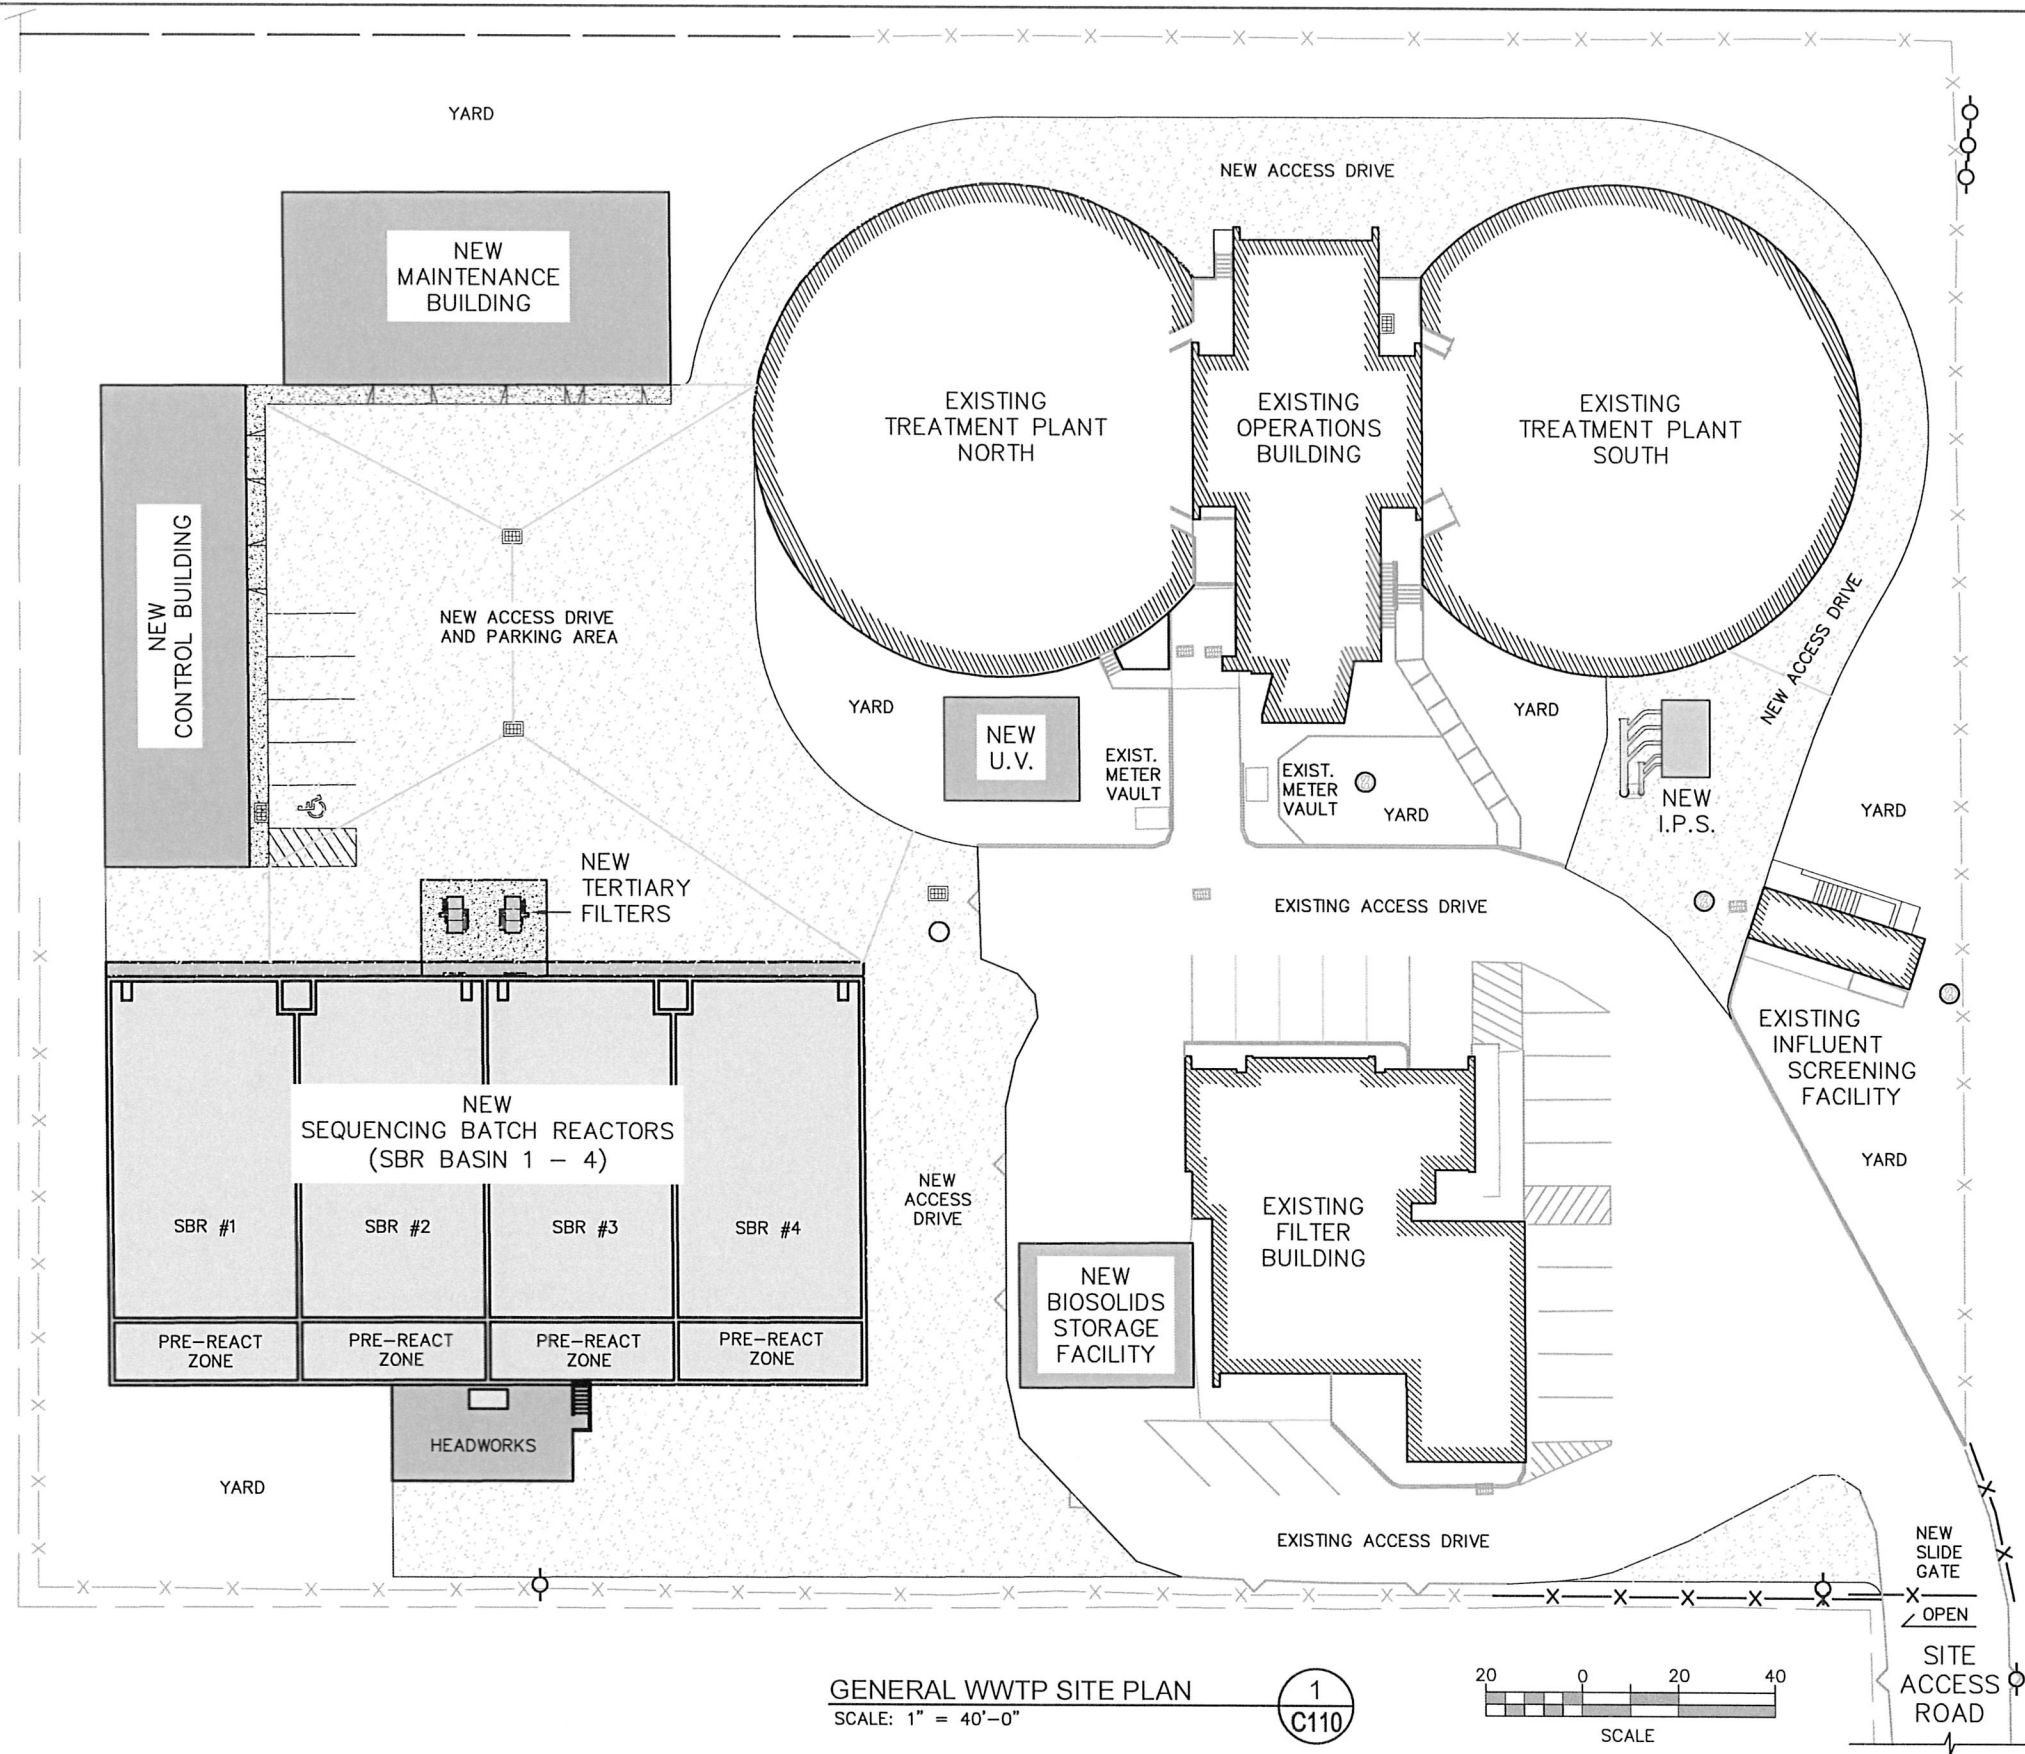

<u>DESIGNED:</u> _____		<u>DRAWN:</u> _____		<u>REVISIONS</u>				
				REVISED	DESCRIPTION	SUBMIT.	APPR'D.	DATE
<u>APPROVED BY:</u> _____								
DATE: _____								




THE DYER PARTNERSHIP
ENGINEERS & PLANNERS, INC.
1330 TEAKWOOD AVENUE
COOS BAY, OREGON 97420
TELEPHONE: (541) 269-0732
www.dyerpart.com

LINE IS 1 INCH
AT FULL SCALE
IF NOT 1-INCH - SCALE ACCORDINGLY

**WASTEWATER TREATMENT PLANT IMPROVEMENTS
CITY OF SUTHERLIN**

**CIVIL
NEW WWTP SITE PLAN**

PROJECT NO. 146.38	DRAWING NO. C100
DATE MAY 2016	SHEET NO. 29 OF 70

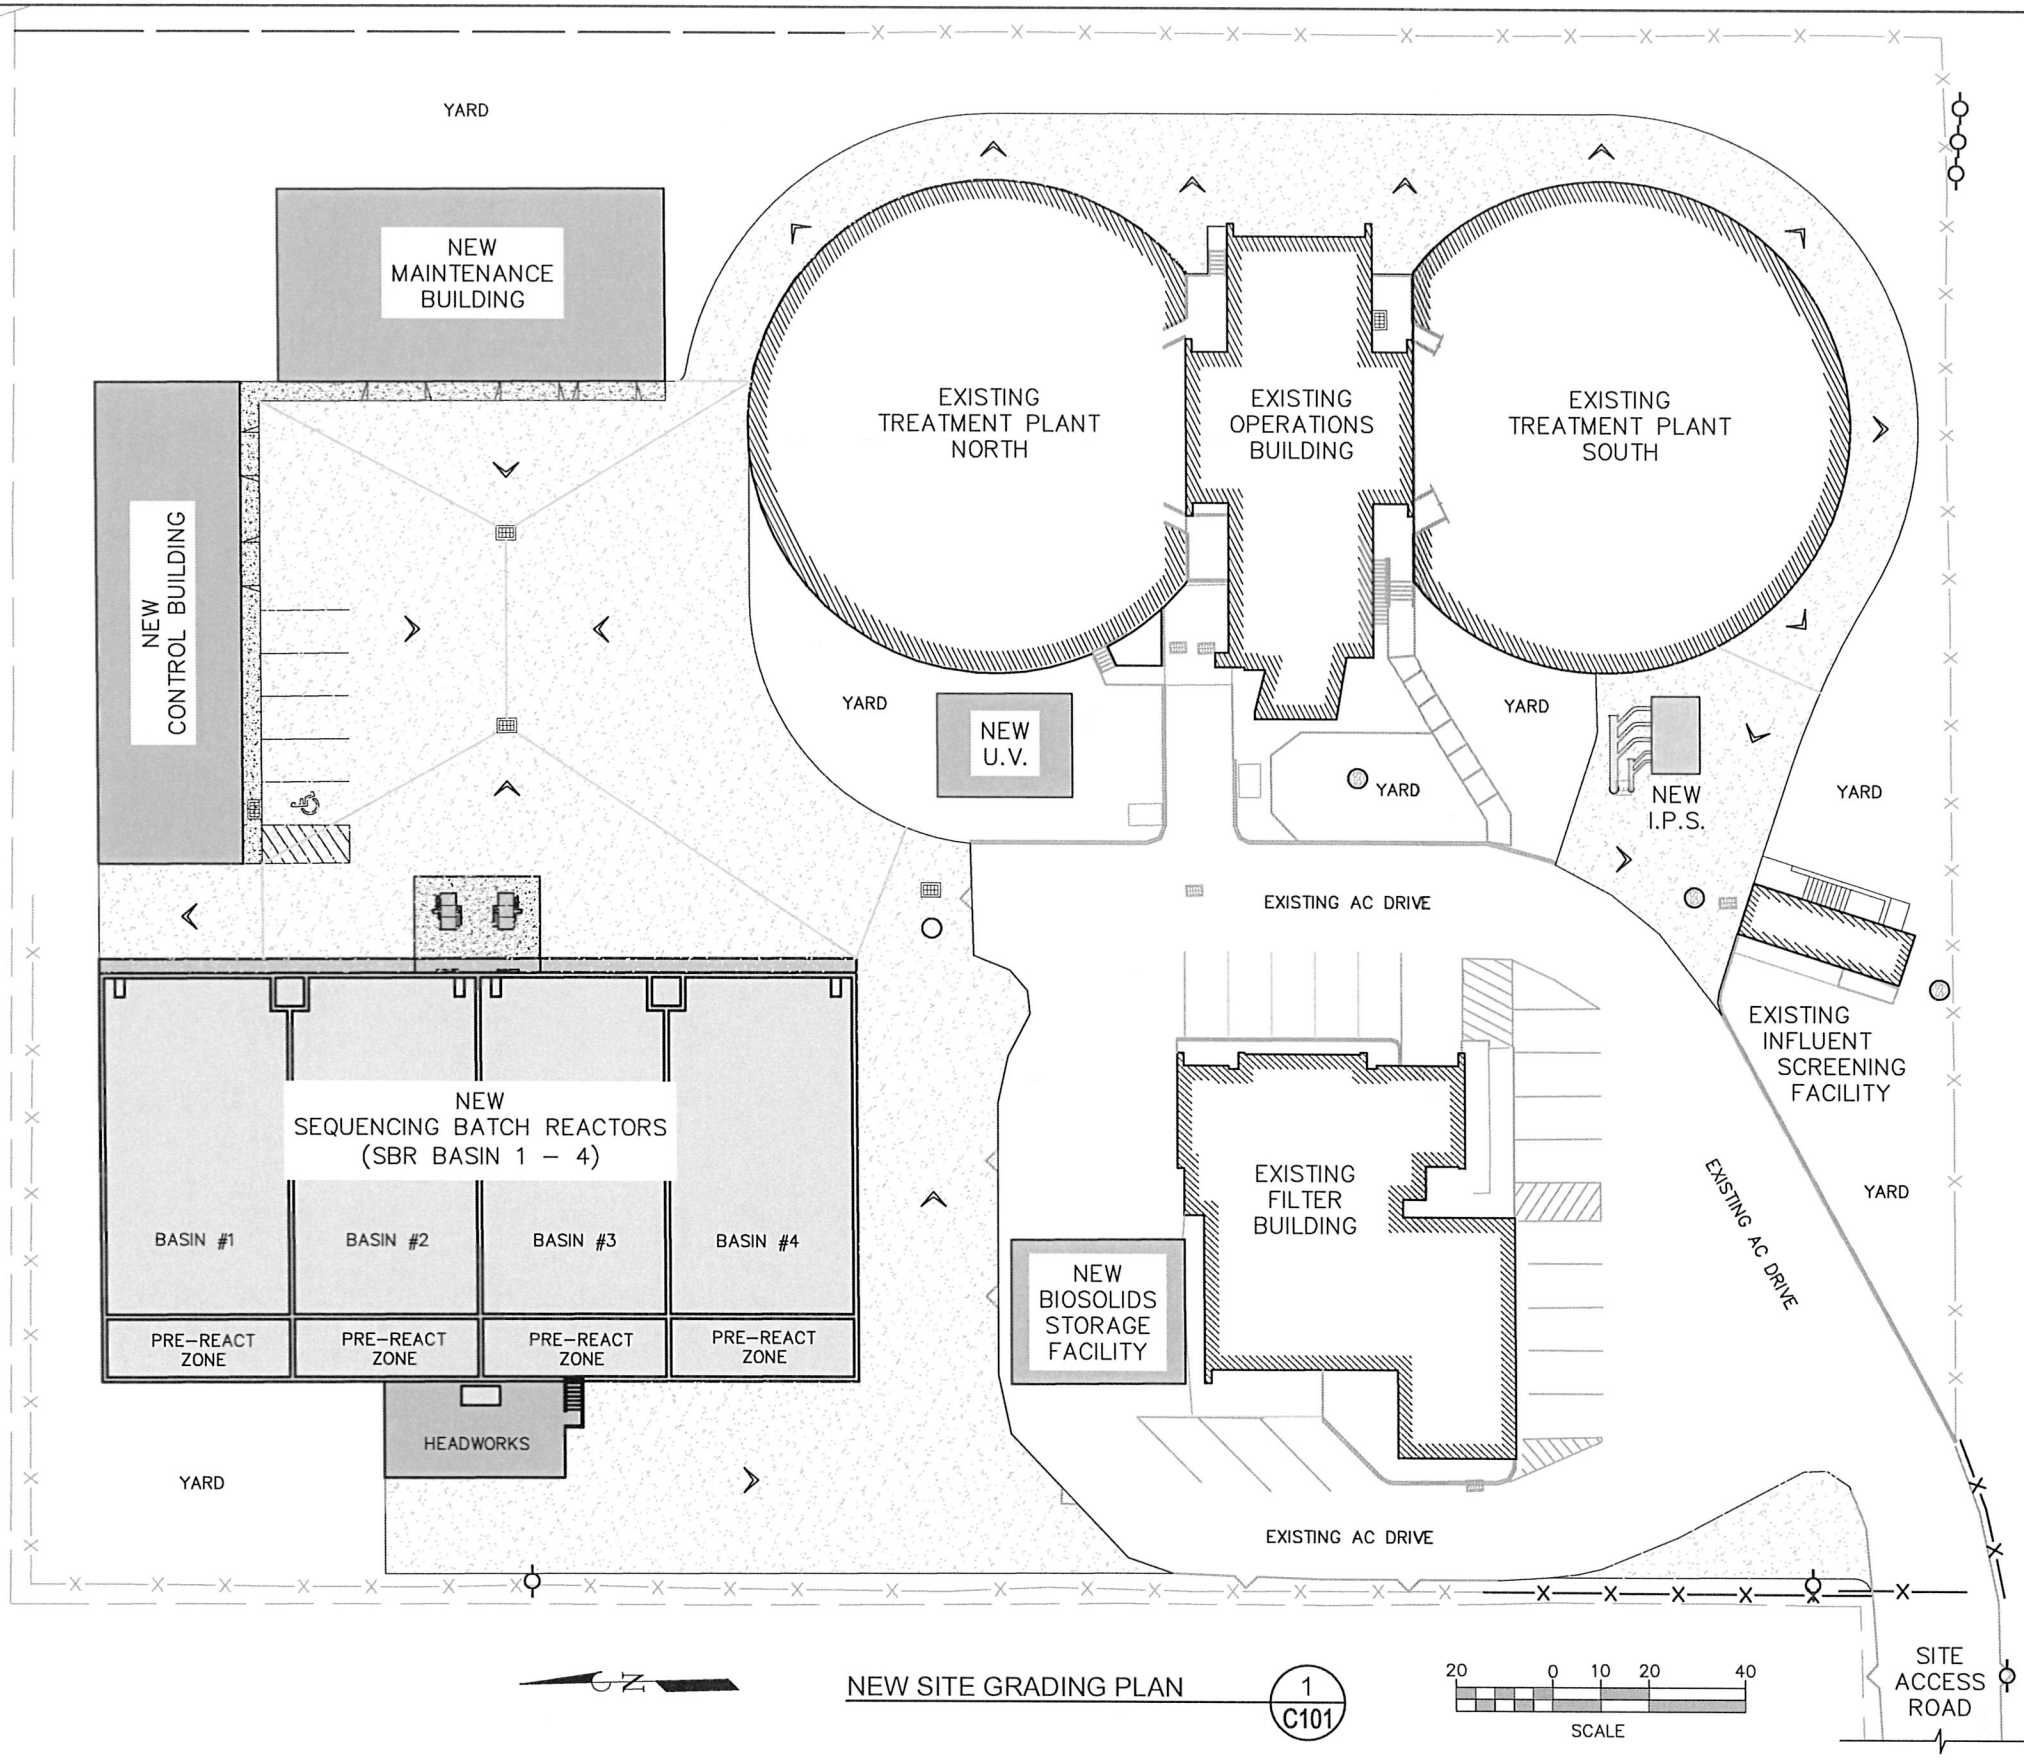

POINT	ELEVATION	DESCRIPTION
1000	X	X
1001		
1002		
1003		
1004		
1005		
1006		
1007		
1008		
1009		
1010		
1011		
1012		
1013		
1014		
1015		

- NOTE:
1. CONTRACTOR TO INSTALL ORANGE CONSTRUCTION FENCING ALONG WETLANDS. CONFIRM EXACT LOCATION INFELD W/ENGINEER. APPROXIMATE LENGTH OF FENCING ALONG WETLANDS IS 700 FEET.
 2. ELEVATIONS ON THIS SHEET REPRESENT EXISTING CONDITIONS.

LEGEND

NEW AC PAVEMENT

SYMBOLS

SLOPE FINISH SURFACE TO DRAIN




DESIGNED:	DRAWN:	REVISIONS			
----	----	REVISED	DESCRIPTION	SUBMIT.	APPR'D.
APPROVED BY:					DATE

DATE: -----					

NEW SITE GRADING PLAN

 1
C101




THE DYER PARTNERSHIP
ENGINEERS & PLANNERS, INC.
1330 TEAKWOOD AVENUE
COOS BAY, OREGON 97420
TELEPHONE: (541) 269-0732
www.dyerpart.com

LINE IS 1 INCH
AT FULL SCALE
IF NOT 1-INCH - SCALE ACCORDINGLY

WASTEWATER TREATMENT PLANT IMPROVEMENTS
CITY OF SUTHERLIN

CIVIL
NEW SITE GRADING PLAN

PROJECT NO.	DRAWING NO.
146.38	C101
DATE	SHEET NO.
MAY 2016	30 OF 70

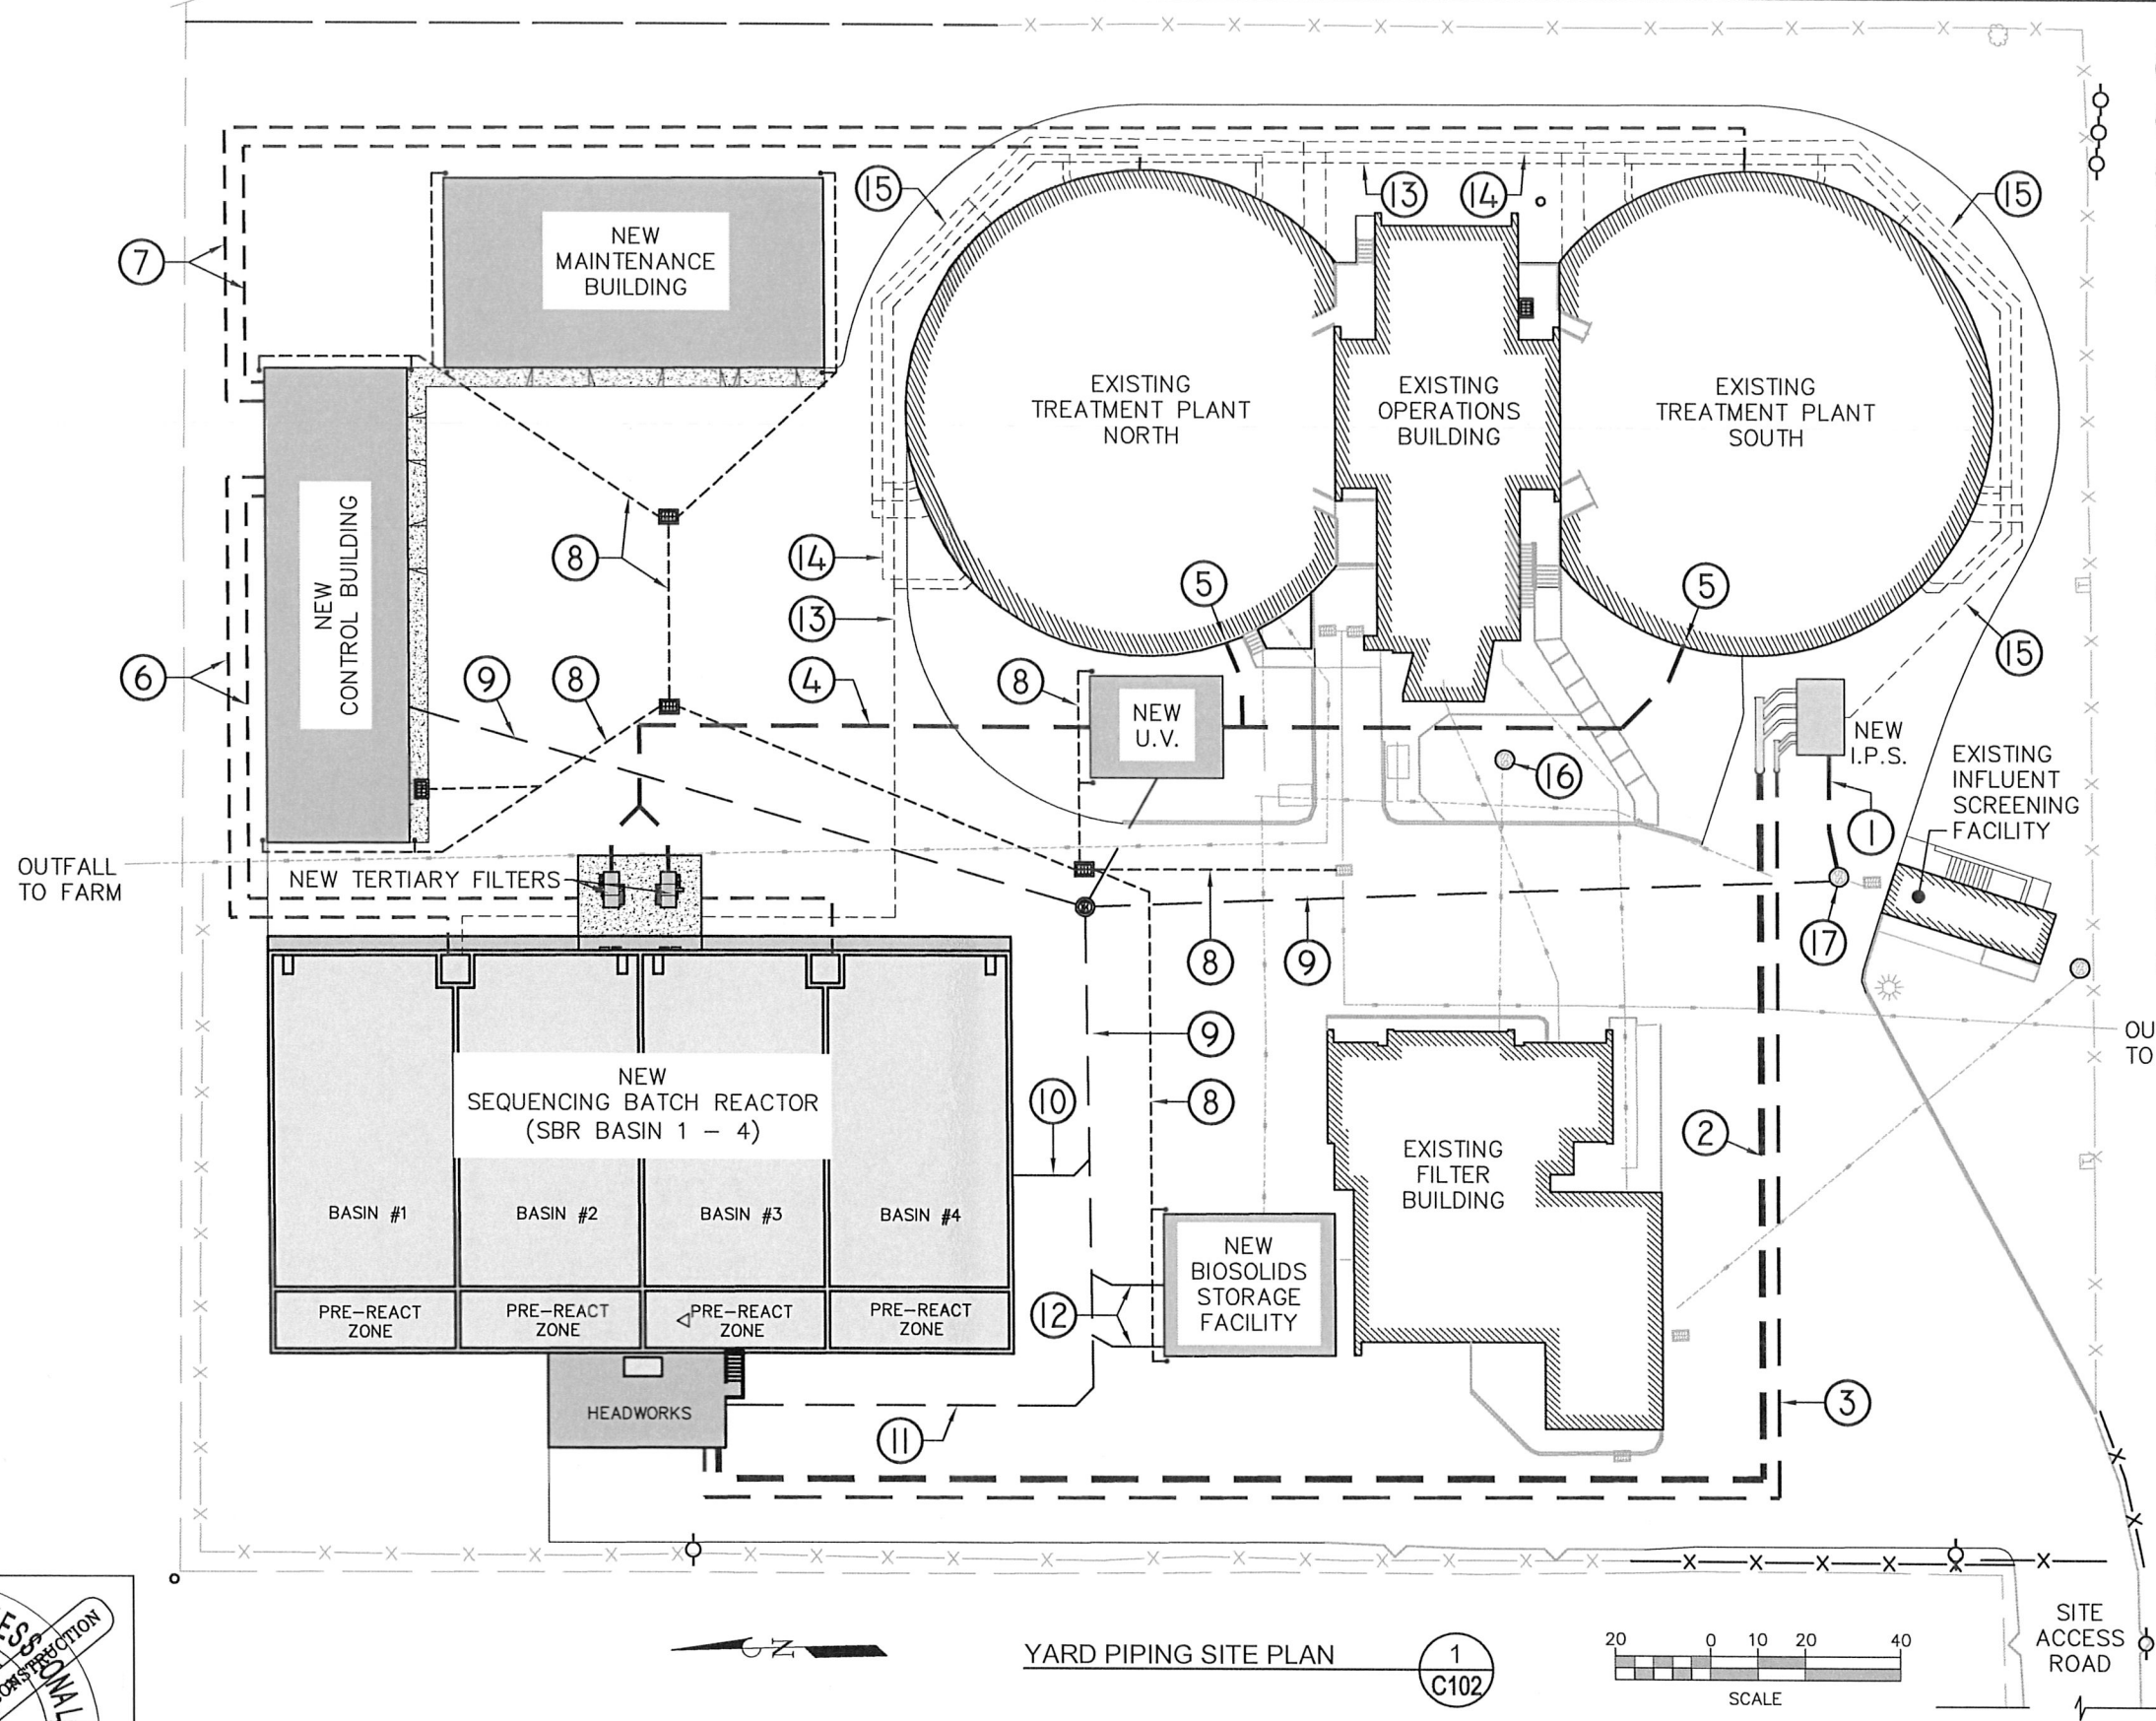OUTFALL
TO FARM

- | NO. | NEW CONSTRUCTION NOTES |
|-----|--|
| 1 | 27"Ø RAW SEWAGE PIPE FROM EXISTING INFLUENT SCREENING FACILITY TO INFLUENT PUMP STATION (IPS). |
| 2 | 18"Ø FORCE MAIN FROM INFLUENT PUMP STATION (IPS) TO HEADWORKS. |
| 3 | 10"Ø FORCE MAIN FROM INFLUENT PUMP STATION (IPS) TO HEADWORKS. |
| 4 | 24"Ø SECONDARY EFFLUENT / TERTIARY EFFLUENT TO ULTRAVIOLET DISINFECTION (UV). |
| 5 | 24"Ø FINAL EFFLUENT FROM ULTRAVIOLET DISINFECTION (UV) TO IRRIGATION CHAMBER LOCATED IN EXISTING TREATMENT PLANT NORTH AND CHLORINE CONTACT CHAMBER LOCATED IN EXISTING TREATMENT PLANT SOUTH. |
| 6 | 8"Ø AIR SUPPLY LINE FROM BLOWER ROOM TO SBR. |
| 7 | 8"Ø AIR SUPPLY LINE FROM BLOWER ROOM TO DIGESTERS. |
| 8 | STORM DRAIN PIPING |
| 9 | CONTROL BUILDING DRAIN / SANITARY LINE |
| 10 | SBR BASIN TANK DRAIN LINE |
| 11 | HEADWORKS DRAIN LINE |
| 12 | BIOSOLIDS STORAGE FACILITY DRAIN LINE |
| 13 | WASTE ACTIVATED SLUDGE (WAS) LINE |
| 14 | SLUDGE TRANSFER PIPING |
| 15 | DIGESTER SUPERNATANT DRAIN LINE |
| 16 | EXISTING INFLUENT MANHOLE |
| 17 | EXISTING INFLUENT SCREENING FACILITY MANHOLE |

OUTFALL
TO CREEKSITE
ACCESS
ROAD

YARD PIPING SITE PLAN

1
C102

DESIGNED:

DRAWN:

REVISIONS

APPROVED BY:

DATE:

REVISED	DESCRIPTION	SUBMIT.	APPR'D.	DATE



THE DYER PARTNERSHIP
ENGINEERS & PLANNERS, INC.
1330 TEAKWOOD AVENUE
COOS BAY, OREGON 97420
TELEPHONE: (541) 269-0732
www.dyerpart.com

LINE IS 1 INCH
AT FULL SCALE
IF NOT 1-INCH - SCALE ACCORDINGLY

WASTEWATER TREATMENT PLANT IMPROVEMENTS CITY OF SUTHERLIN

CIVIL NEW YARD PIPING SITE PLAN

PROJECT NO.

146.38

DRAWING NO.

C102

DATE


MAY 2016

SHEET NO.

31 OF 70


CONVEYOR FROM
SCREW PRESS ABOVE
SHOWN DASHED

EXISTING
FILTER BUILDING

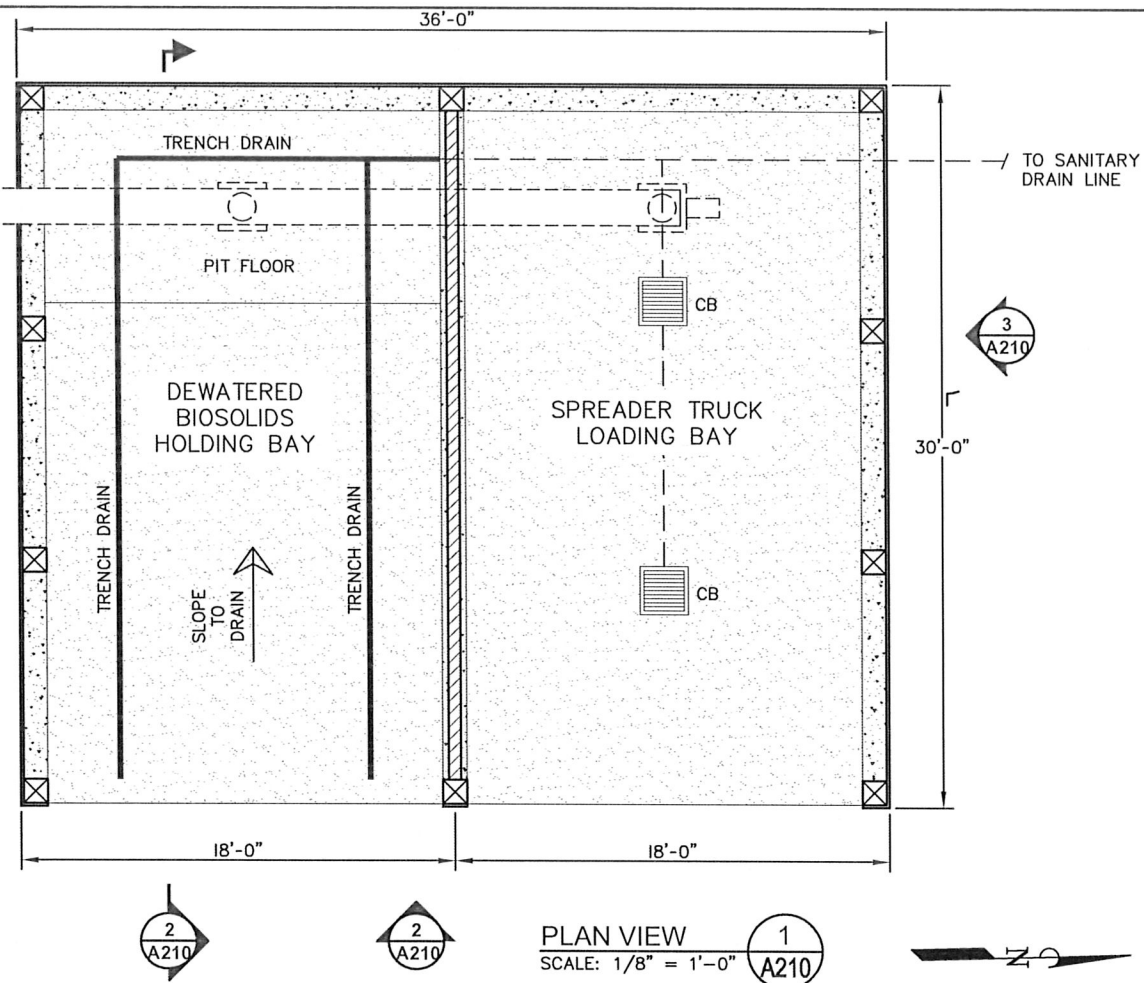



WALL LEGEND	
	2x6 @ 16" O.C.

BUILDING INFORMATION	
OCCUPANCY:	S-I
TYPE OF CONSTRUCTION:	TYPE V FRAMING/ SLAB ON GRADE
BUILDING AREA:	1080 SQ. FT.

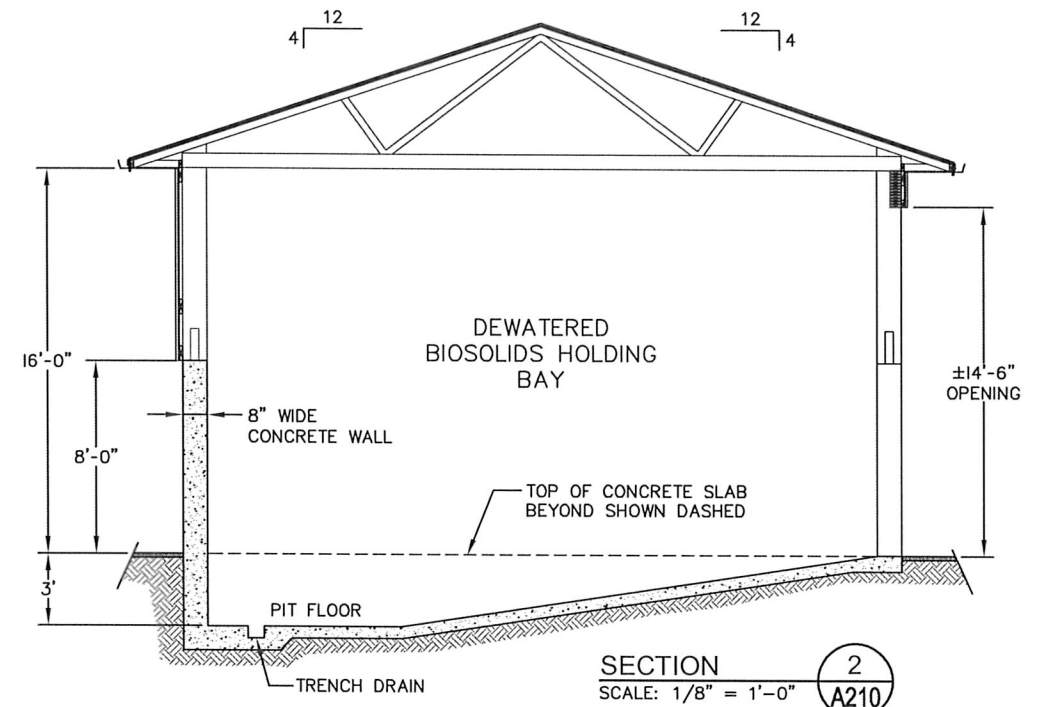

EXISTING
FILTER BUILDING

CONVEYOR FROM
SCREW PRESS SHOWN
DASHED

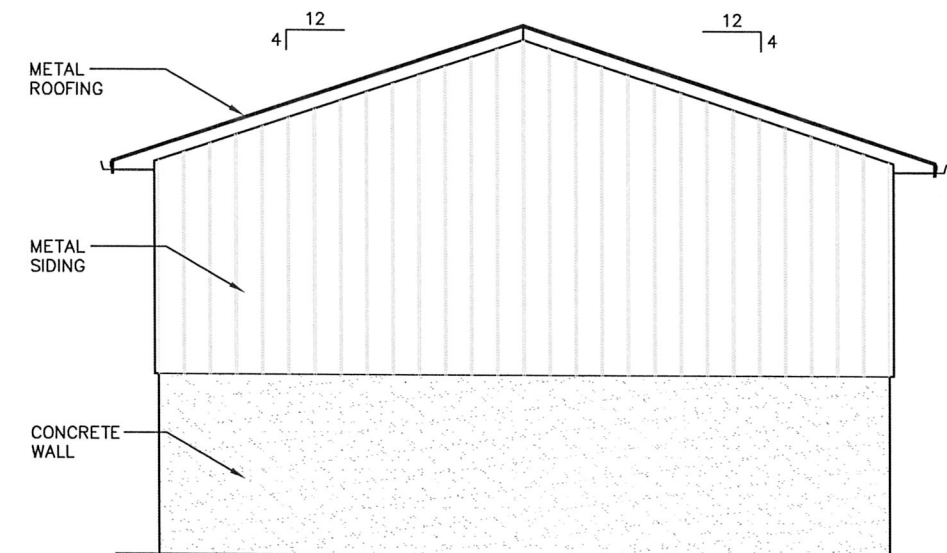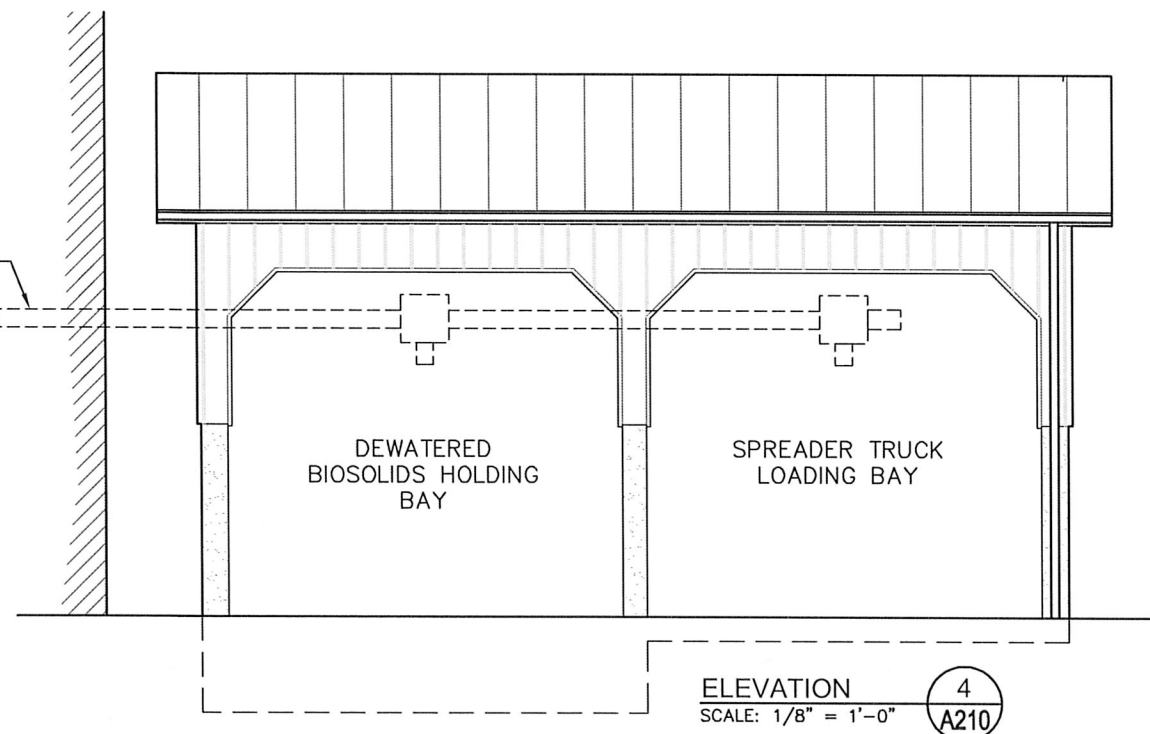

DESIGNED:	DRAWN:
---	---
APPROVED BY:	DATE:
---	---

REVISIONS				
REVISED	DESCRIPTION	SUBMIT.	APPR'D.	DATE


D THE DYER PARTNERSHIP
ENGINEERS & PLANNERS, INC.
1330 TEAKWOOD AVENUE
COOS BAY, OREGON 97420
TELEPHONE: (541) 269-0732
www.dyerpart.com

LINE IS 1/8" AT FULL SCALE
IF NOT 1/8" - SCALE ACCORDINGLY

WASTEWATER TREATMENT PLANT IMPROVEMENTS CITY OF SUTHERLIN		PROJECT NO. 146.38	DRAWING NO. A210
ARCHITECTURAL BIOSOLIDS STORAGE FACILITY		DATE MAY 2016	SHEET NO. 32 OF 70

LOT DATE

\\dyer\dyer-part\A\Projects\146 Sutherlin\146.38 WWTF Pre-Design Report\dwg\PRE-DESIGN\ARCHITECTURAL\CONTROL BUILDING.dwg, 5/4/2016 10:43:34 AMP

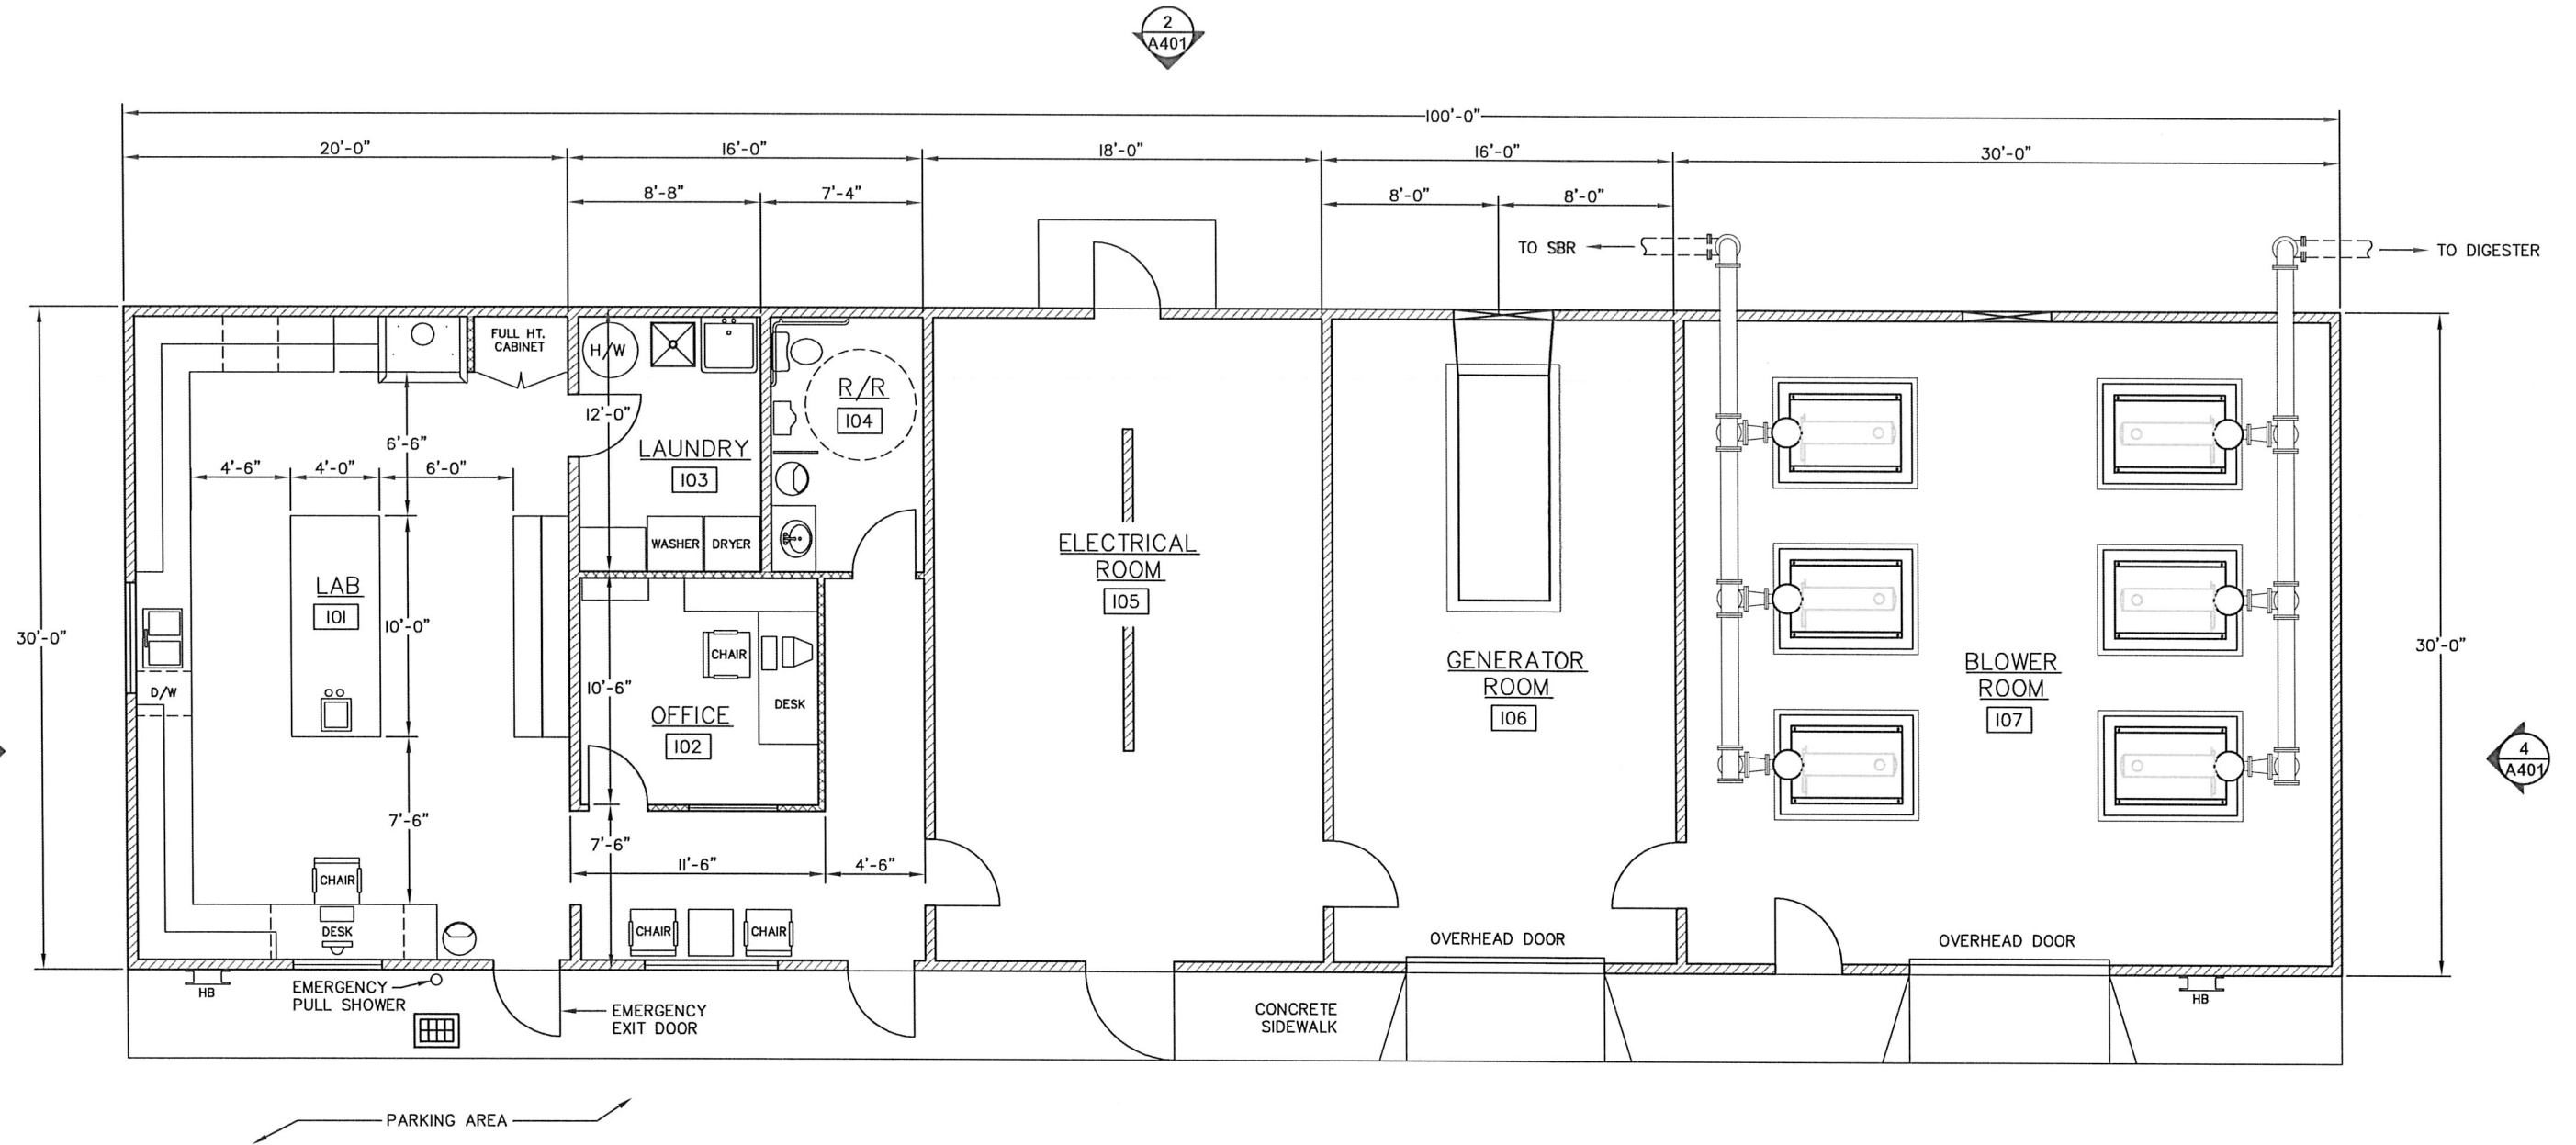

DESIGNED: _____
DRAWN: _____
APPROVED BY: _____
DATE: _____

REVISIONS				
REVISED	DESCRIPTION	SUBMIT.	APPR'D.	DATE

D THE DYER PARTNERSHIP
ENGINEERS & PLANNERS, INC.
1330 TEAKWOOD AVENUE
COOS BAY, OREGON 97420
TELEPHONE: (541) 269-0732
www.dyerpart.com

LINE IS 1/8" AT FULL SCALE
IF NOT 1/8" - SCALE ACCORDINGLY


A
A400

WALL LEGEND	
	2x6 @ 16" O.C.
	2x4 @ 16" O.C.


BUILDING INFORMATION	
OCCUPANCY: B	
TYPE OF CONSTRUCTION:	TYPE V FRAMING/ SLAB ON GRADE
BUILDING AREA:	
LAB:	600 SQ. FT.
OFFICE:	480 SQ. FT.
ELECTRIC:	540 SQ. FT.
GENERATOR:	480 SQ. FT.
BLOWER:	900 SQ. FT.
TOTAL:	3000 SQ. FT.

WASTEWATER TREATMENT PLANT IMPROVEMENTS
CITY OF SUTHERLIN
ARCHITECTURAL
CONTROL BUILDING - FLOOR PLAN


PROJECT NO.	DRAWING NO.
146.38	A400
DATE	SHEET NO.
MAY 2016	33 OF 70

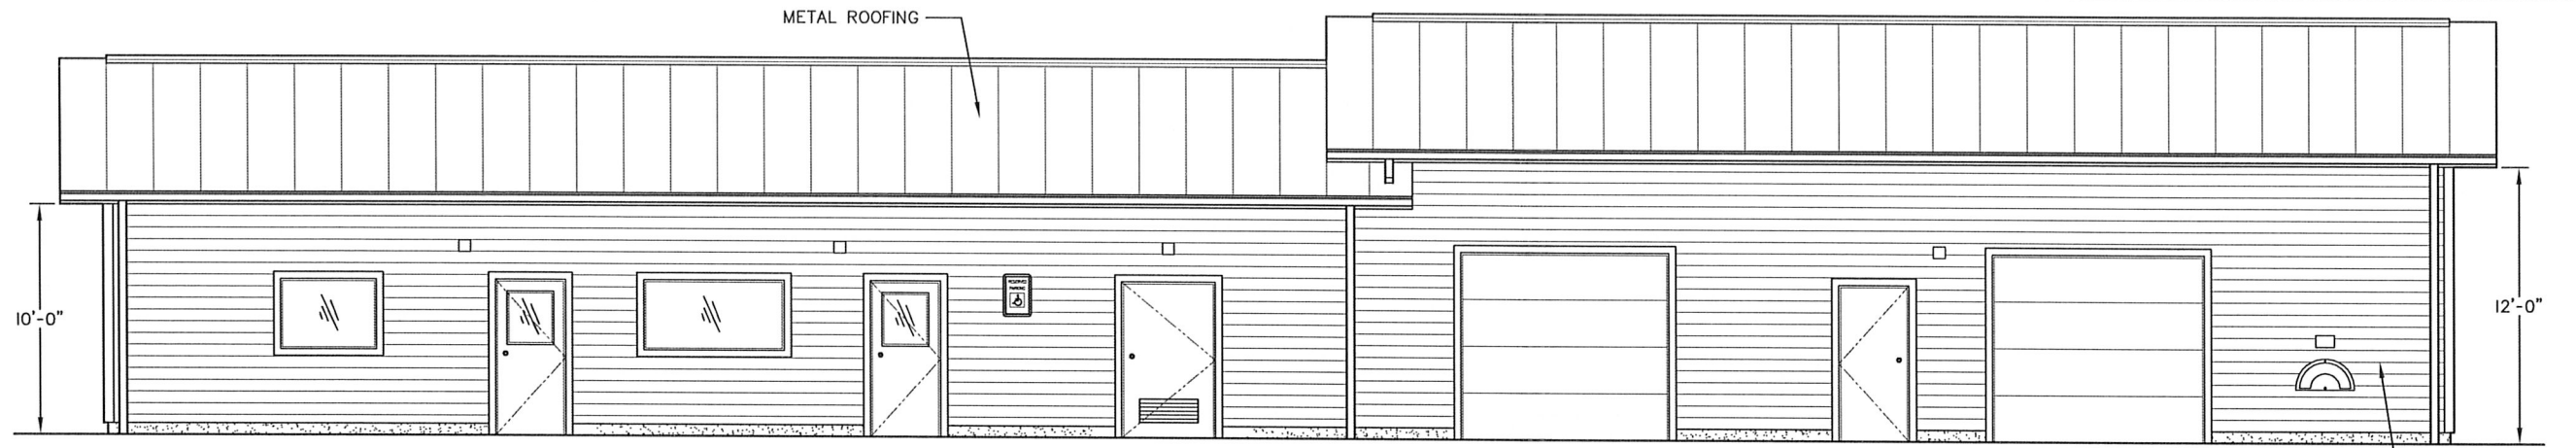


NORTH ELEVATION
SCALE: 1/8" = 1'-0"

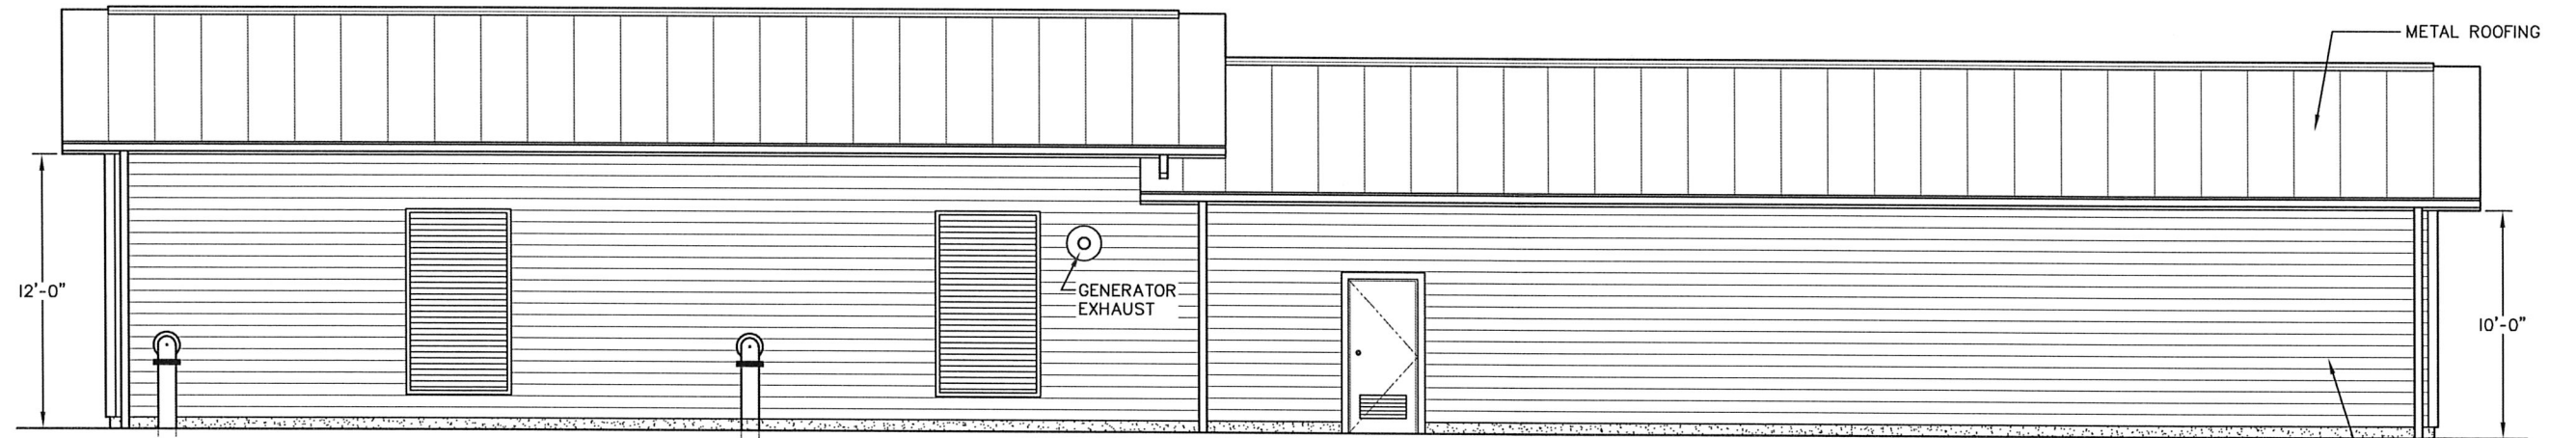

SOUTH ELEVATION
SCALE: 1/8" = 1'-0"

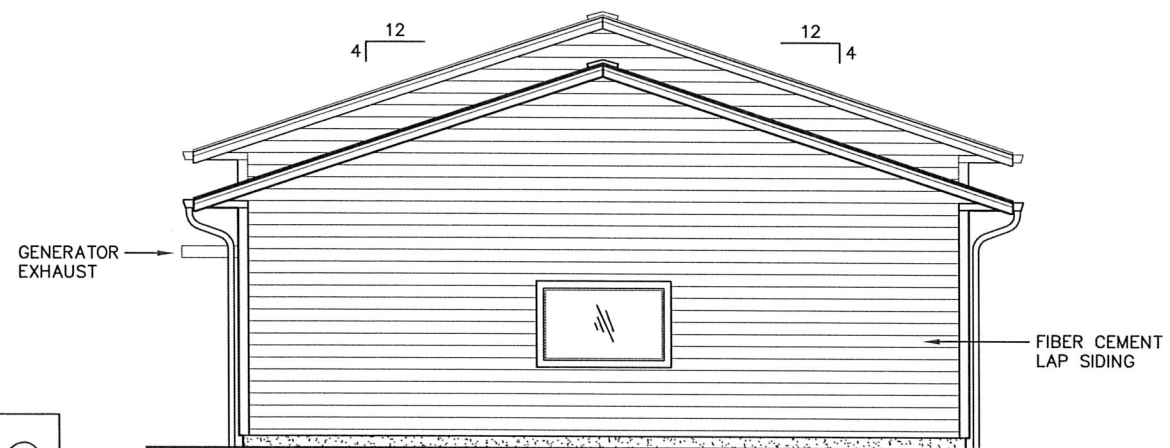

WEST ELEVATION
SCALE: 1/8" = 1'-0"

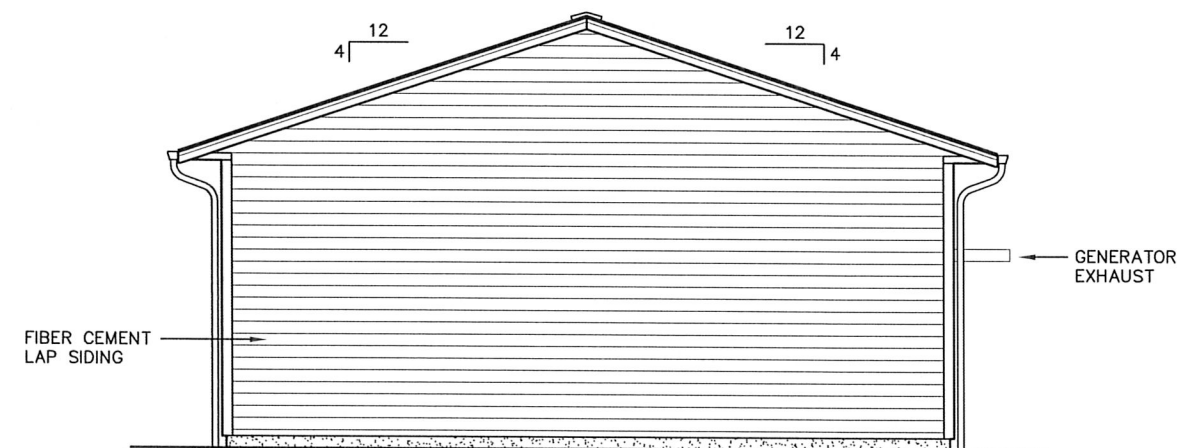

EAST ELEVATION
SCALE: 1/8" = 1'-0"



DESIGNED:	DRAWN:	REVISIONS			
----	----	REVISED	DESCRIPTION	SUBMIT	APPR'D.
APPROVED BY:					
DATE:					


D THE DYER PARTNERSHIP
ENGINEERS & PLANNERS, INC.
1330 TEAKWOOD AVENUE
COOS BAY, OREGON 97420
TELEPHONE: (541) 269-0732
www.dyerpart.com

LINE IS 1 INCH
AT FULL SCALE
IF NOT 1-INCH - SCALE ACCORDINGLY

**WASTEWATER TREATMENT PLANT IMPROVEMENTS
CITY OF SUTHERLIN**

**ARCHITECTURAL
CONTROL BUILDING - ELEVATIONS**

PROJECT NO.	DRAWING NO.
146.38	A401
DATE	SHEET NO.
MAY 2016	34 OF 70

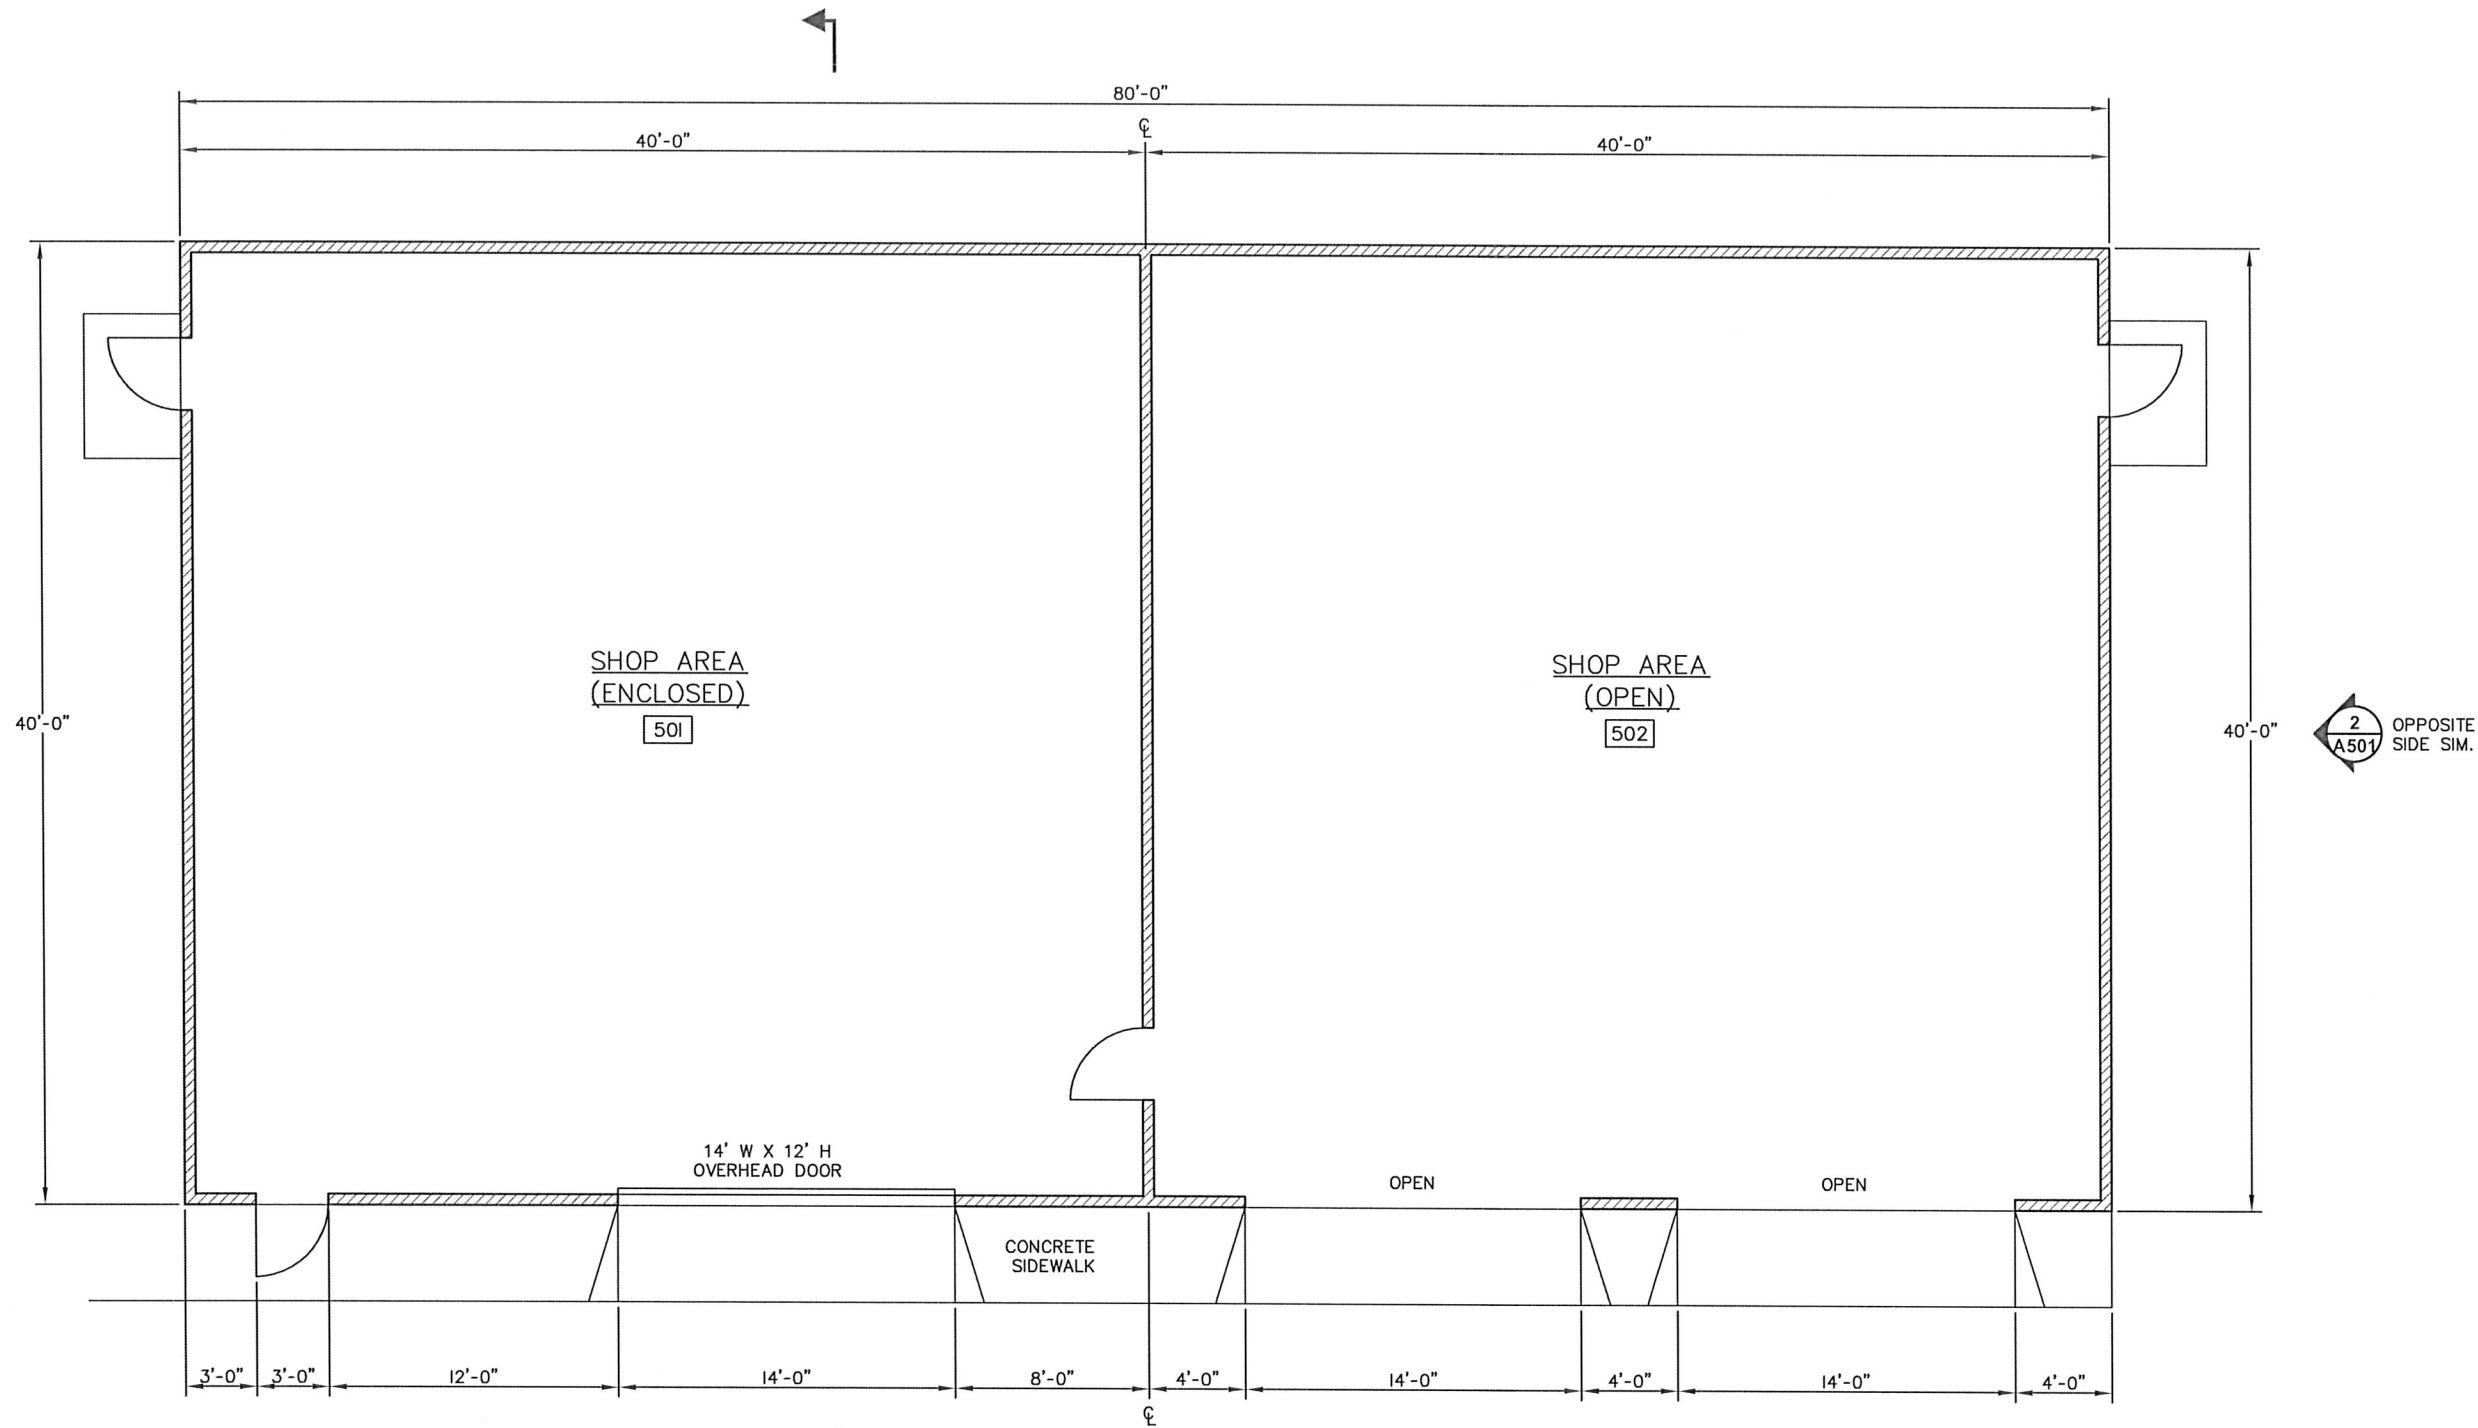

WALL LEGEND	
	2x6 @ 16" O.C.

FLOOR PLAN
SCALE: 1/8" = 1'-0"

1
A500

BUILDING INFORMATION	
OCCUPANCY:	S-I
TYPE OF CONSTRUCTION:	TYPE V FRAMING/ SLAB ON GRADE
BUILDING AREA:	
ENCLOSED:	1600 SQ. FT.
OPEN:	1600 SQ. FT.
TOTAL:	3200 SQ. FT.



DESIGNED:	DRAWN:
---	---
APPROVED BY:	DATE:
---	---

REVISIONS				
REVISED	DESCRIPTION	SUBMIT.	APPR'D.	DATE



THE DYER PARTNERSHIP
ENGINEERS & PLANNERS, INC.
1330 TEAKWOOD AVENUE
COOS BAY, OREGON 97420
TELEPHONE: (541) 269-0732
www.dyerport.com


LINE IS 1/8" INCH
AT FULL SCALE
IF NOT 1/8" INCH - SCALE ACCORDINGLY

WASTEWATER TREATMENT PLANT IMPROVEMENTS
CITY OF SUTHERLIN
ARCHITECTURAL
SHOP BUILDING - FLOOR PLAN

PROJECT NO.	DRAWING NO.
146.38	A500
DATE	SHEET NO.
MAY 2016	35 OF 70


LOT DATE

\\dye\dyer-port\AProjects\146 Sutherlin\146.38 WWTF Pre-Design Report\dwg\PRE-DESIGN\ARCHITECTURAL\CONTROL BUILDING.dwg, 5/4/2016 10:43:34 AMP

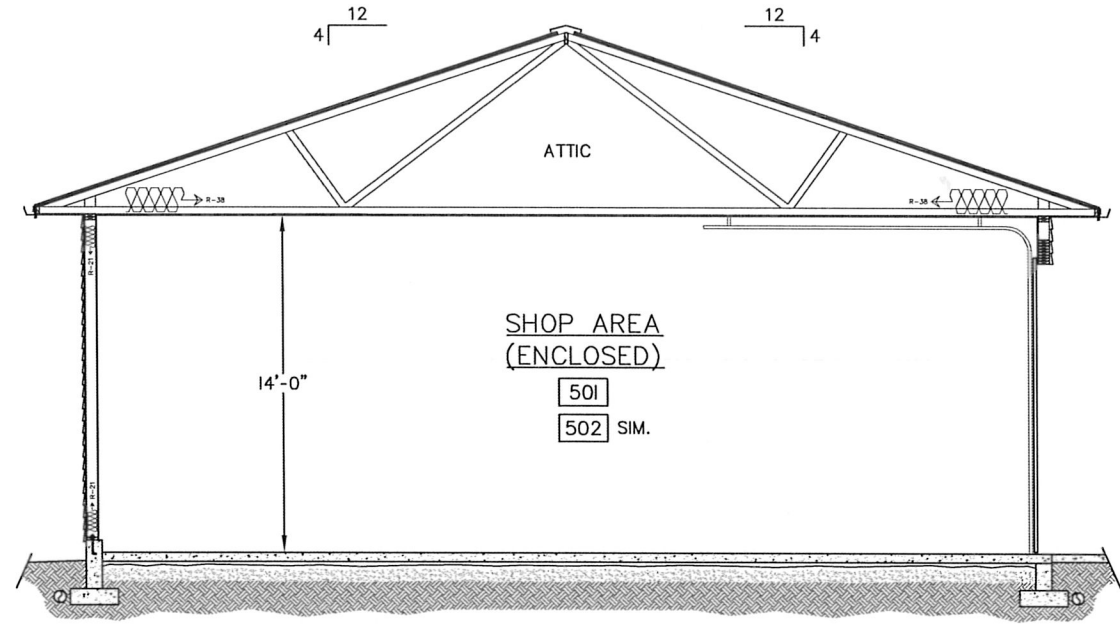

SECTION
SCALE: 1/8" = 1'-0"

1
A501

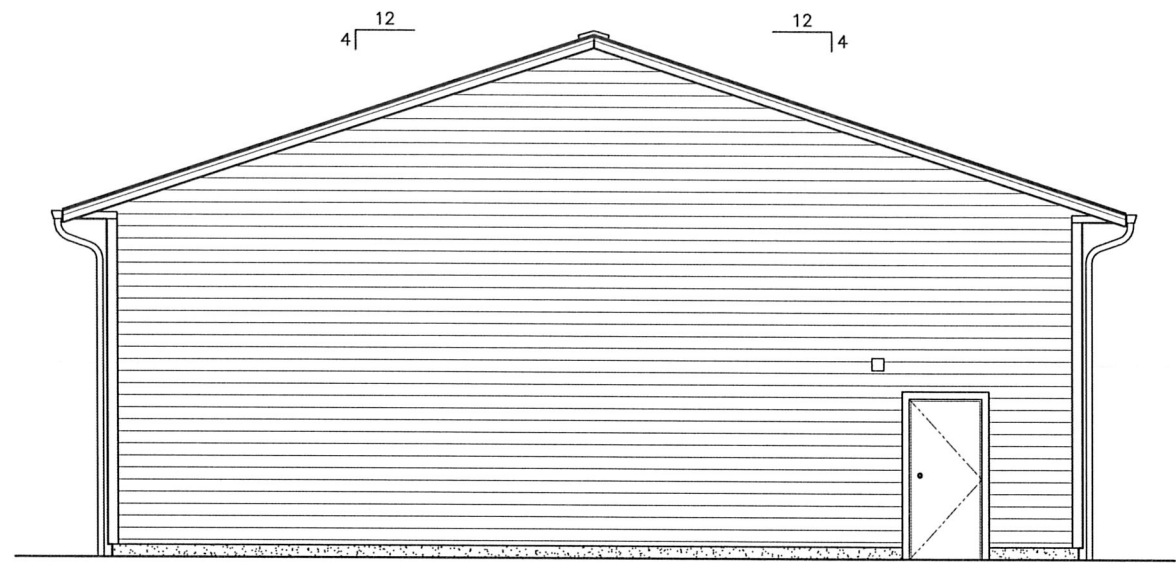

NORTH ELEVATION
SCALE: 1/8" = 1'-0" (OPPOSITE SIDE SIM.)

2
A501



EAST ELEVATION
SCALE: 1/8" = 1'-0" (OPPOSITE SIDE SIM.)

3
A501




<u>DESIGNED:</u> _____	<u>DRAWN:</u> _____	<u>REVISIONS</u>				
		REVISED	DESCRIPTION	SUBMIT.	APPR'D.	DATE



THE DYER PARTNERSHIP
ENGINEERS & PLANNERS, INC.
1330 TEAKWOOD AVENUE
COOS BAY, OREGON 97420
TELEPHONE: (541) 269-0732
www.dyerpart.com

LINE IS 1 INCH
AT FULL SCALE
IF NOT 1-INCH - SCALE ACCORDINGLY

WASTEWATER TREATMENT PLANT IMPROVEMENTS CITY OF SUTHERLIN		PROJECT NO. 146.38	DRAWING NO. A501
ARCHITECTURAL SHOP BUILDING - SECTIONS & ELEVATIONS		DATE MAY 2016	SHEET NO. 36 OF 70

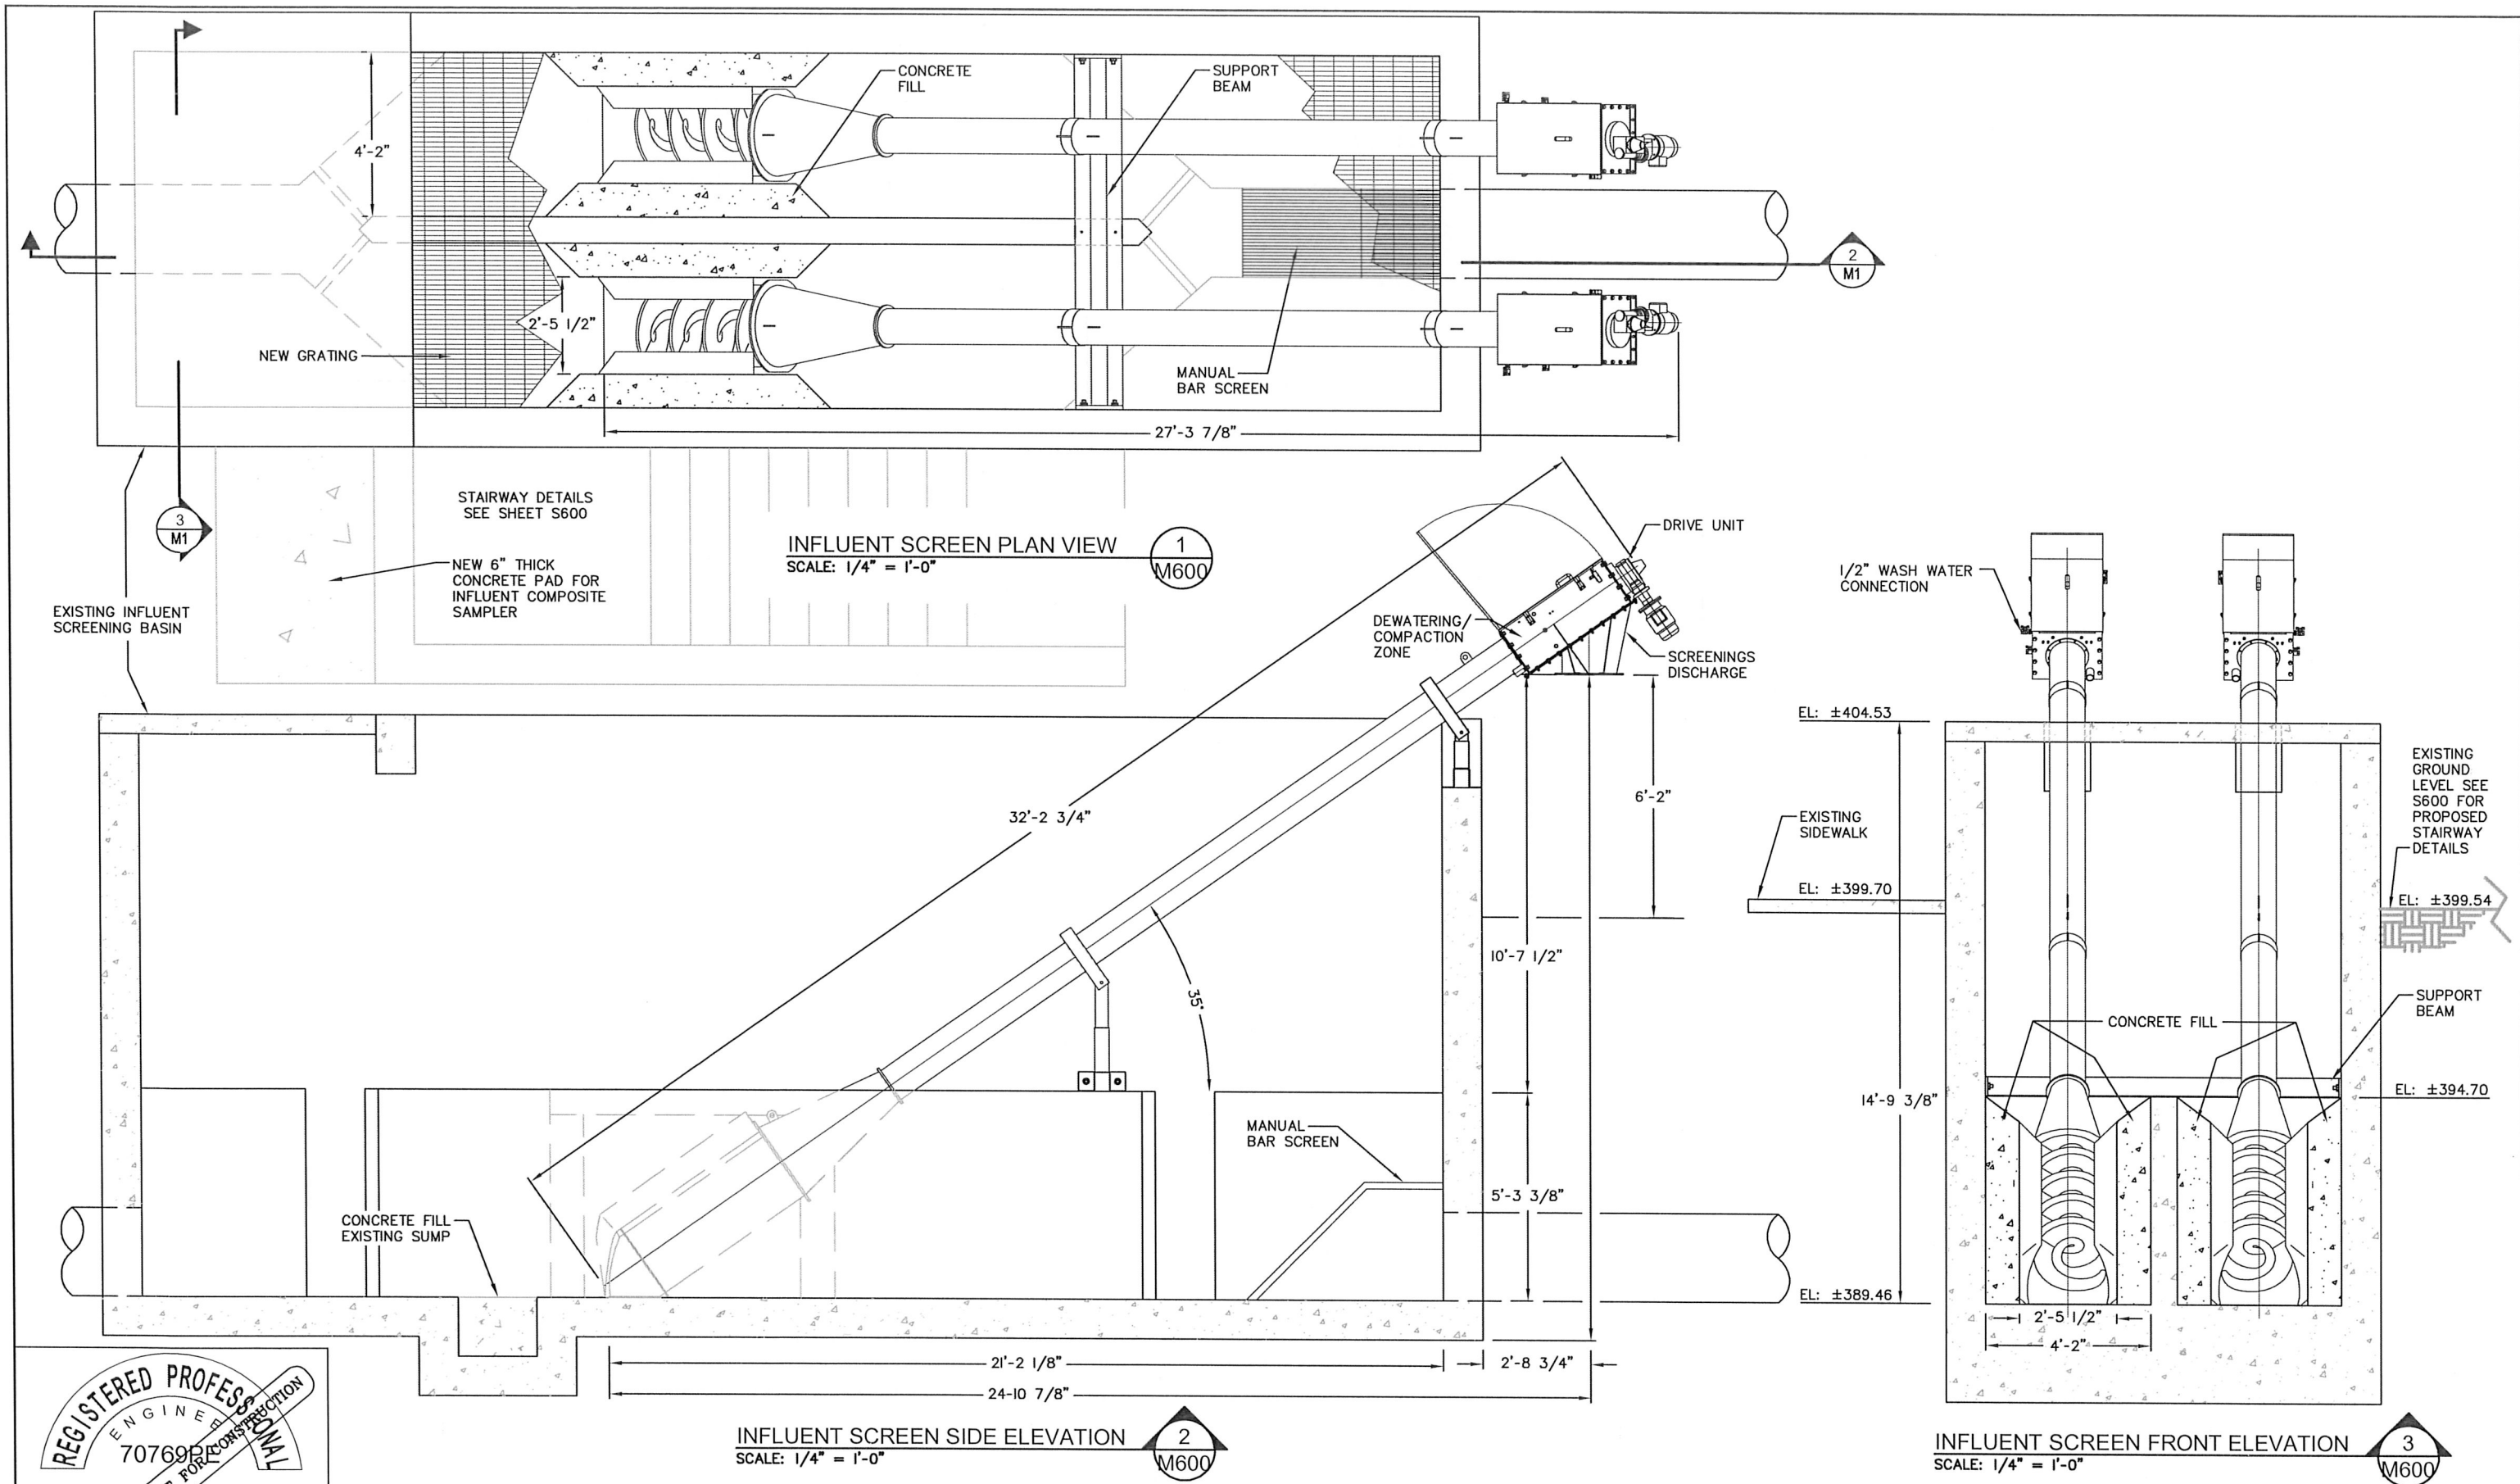

SUBMITTED BY: _____ DATE: _____

APPROVED BY: _____ DATE: _____

REVISIONS				
REVISED	DESCRIPTION	SUBMIT	APPR'D	DATE

DESIGNED: _____

DRAWN: _____

CHECKED: _____

APPROVED: _____




THE DYER PARTNERSHIP
ENGINEERS & PLANNERS, INC.
1330 TEAKWOOD AVENUE
COOS BAY, OREGON 97420
TELEPHONE: (541) 269-0732
www.dyerport.com

LINE IS 1 INCH
AT FULL SCALE
IF NOT 1-INCH - SCALE ACCORDINGLY


WASTEWATER TREATMENT PLANT IMPROVEMENTS
CITY OF SUTHERLIN
SCREENING FACILITY
INFLUENT SCREEN PLAN AND SECTIONS

PROJECT NO. 146.38	DRAWING NO. M600
DATE MAY 2016	SHEET NO. 37 OF 70

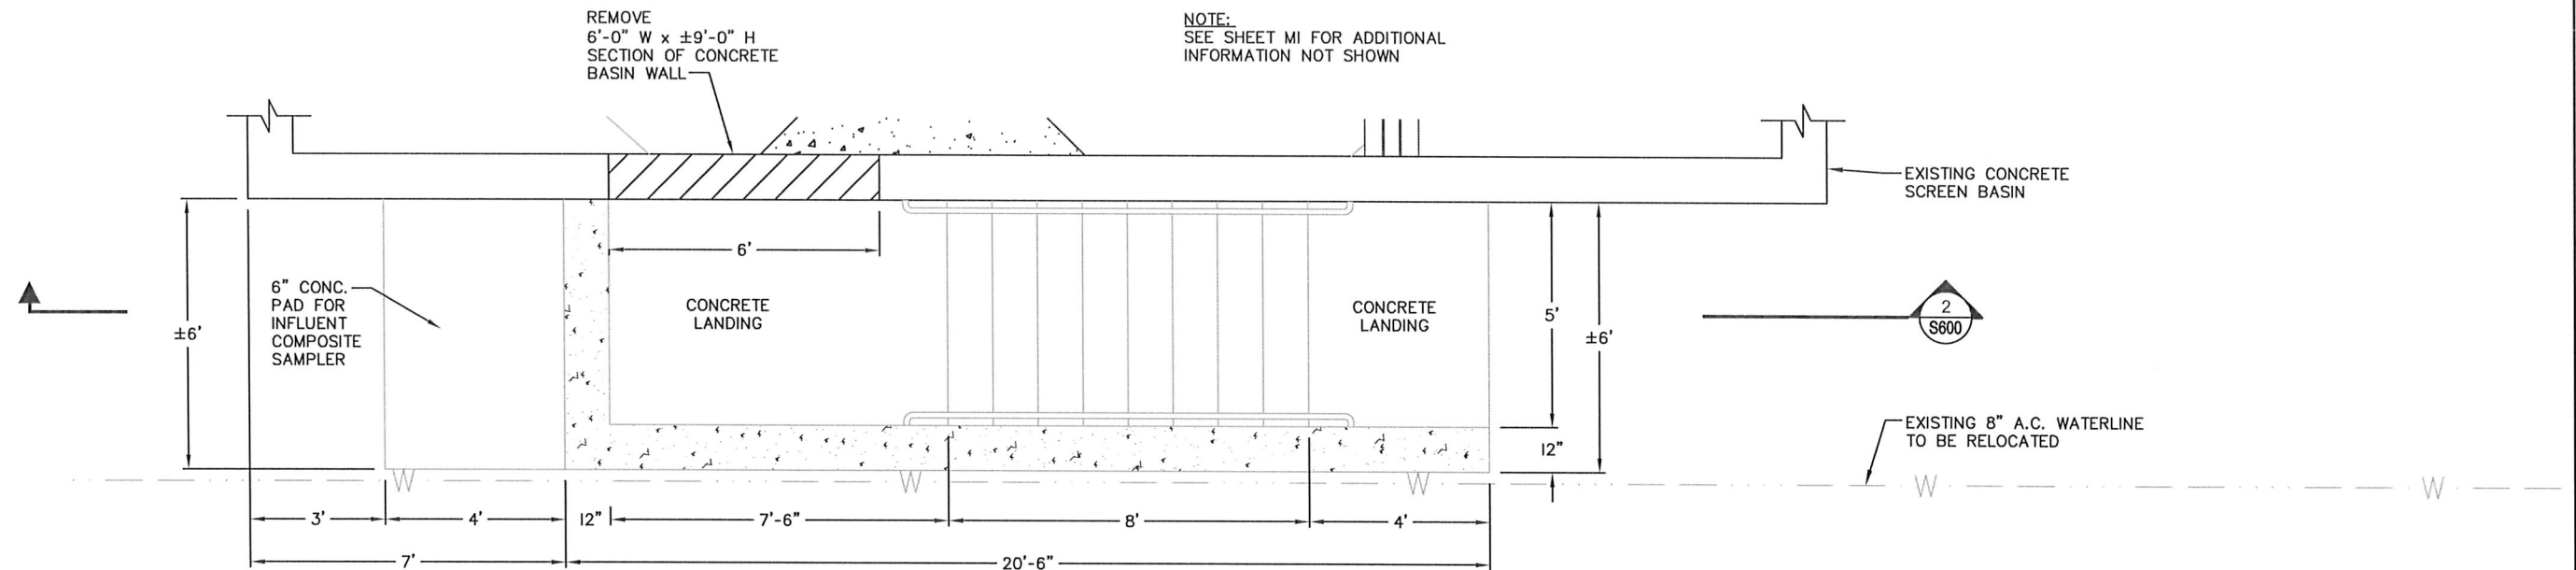

INFLUENT SCREEN - STAIRWAY PLAN
SCALE: 1/4" = 1'-0"

1
S600

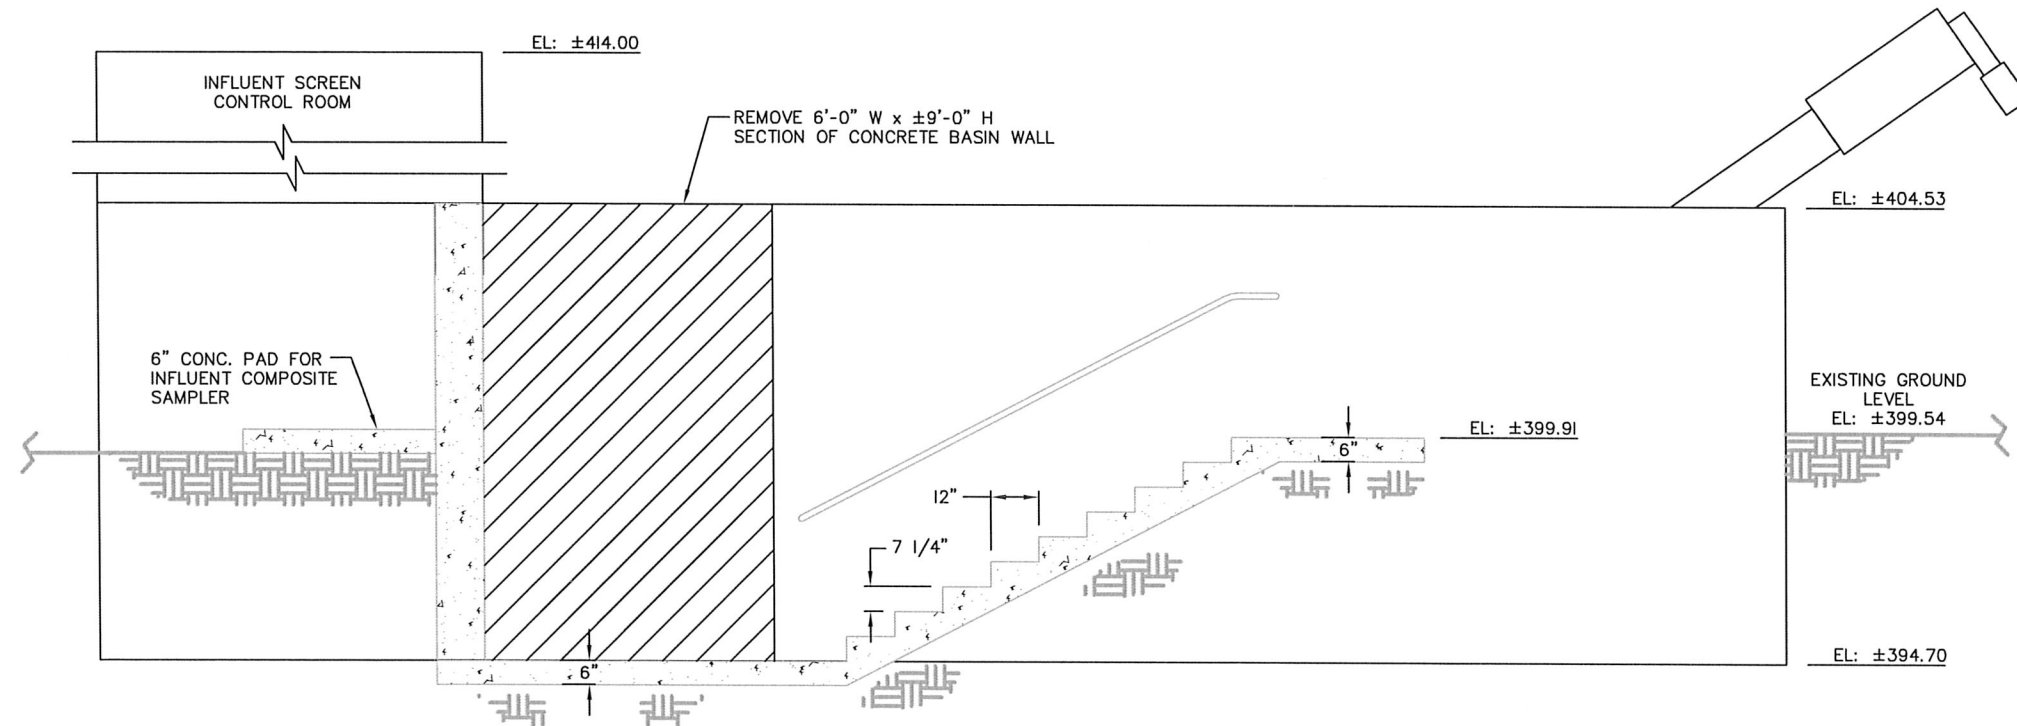

INFLUENT SCREEN - STAIRWAY SECTION
SCALE: 1/4" = 1'-0"

2
S600



DESIGNED:	DRAWN:
---	---
APPROVED BY:	DATE:
---	---


REVISIONS				
REVISED	DESCRIPTION	SUBMIT.	APPR'D.	DATE

D THE DYER PARTNERSHIP
ENGINEERS & PLANNERS, INC.
1330 TEAKWOOD AVENUE
COOS BAY, OREGON 97420
TELEPHONE: (541) 269-0732
www.dyerpart.com

LINE IS 1 INCH
AT FULL SCALE
IF NOT 1-INCH - SCALE ACCORDINGLY

WASTEWATER TREATMENT PLANT IMPROVEMENTS CITY OF SUTHERLIN		PROJECT NO. 146.38	DRAWING NO. S600
SCREENING FACILITY INFLUENT SCREEN STAIRCASE DETAIL		DATE MAY 2016	SHEET NO. 38 OF 70

\\dye\dyer-part\A\projects\146.38 WWTF Pre-Design Report\dwg\PRE-DESIGN\PROCESS AREA 700 IPS\M700.dwg, 3/22/2016 9:22:14 AM May 5, 2016 PLOT DATE

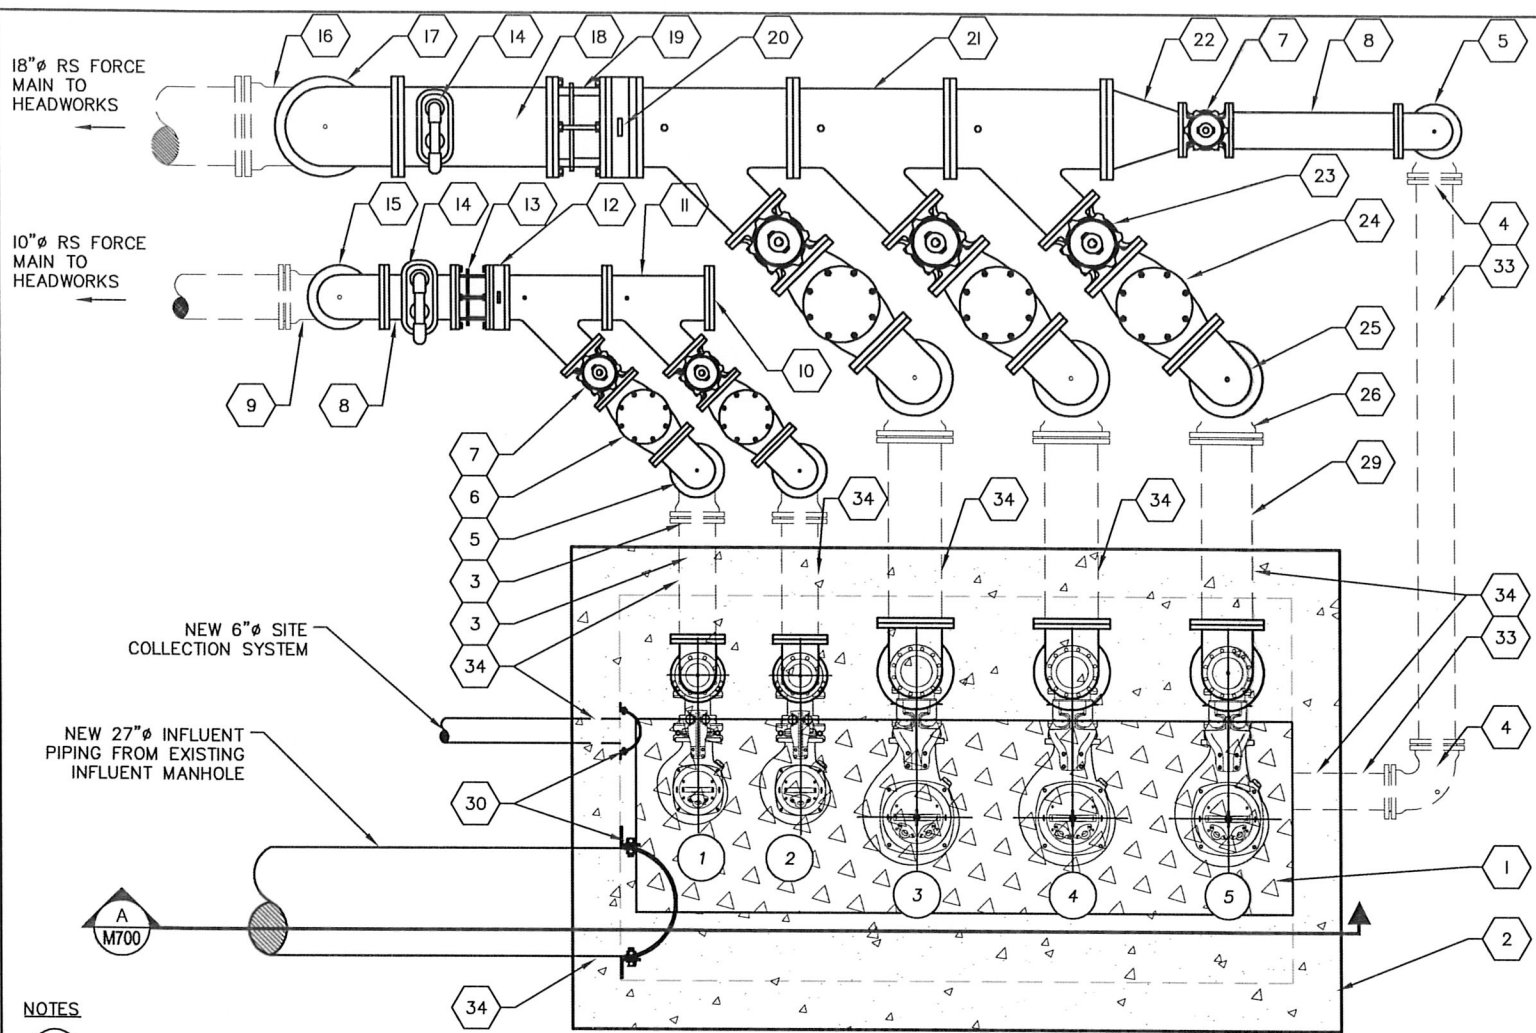

NOTES

DENOTES PUMP

PIPE SUPPORTS NOT SHOWN FOR CLAIRITY. PROVIDE PIPE SUPPORTS AS REQUIRED.


SEE SHEET C??? FOR PLAN VIEW ELEVATIONS

HEADWORKS PUMP STATION WETWELL DESIGN DATA	
RIM ELEVATION:	400.00'
WETWELL DIMENSION:	14'-0" X 8'-00"
OVERFLOW ALARM:	394.50'
8" FM OUT I.E.:(TYP. OF 2)	396.00'
12" FM OUT I.E.:(TYP. OF 3)	396.00'
6" INLET (N)	39X.XX'
27" INLET I.E. (N):	389.08'
HWL: ALARM:	389.50'
SMALL PUMP #1 ON:	385.00'
SMALL PUMP #2 ON:	386.00'
LARGE PUMP #1 ON	387.00'
LARGE PUMP #1 & #2 ON	388.00'
LARGE PUMP #1, #2 & #3 ON	389.00'
ALL PUMPS OFF:	382.00'
LWL: ALARM:	381.50'
BOTTOM OF WELL:	380.00'

PUMP STATION PLAN VIEW 1 M700

SCALE: 1/4" = 1'-0"

- KEY NOTES:**
- | | |
|---|--|
| 1 NEW H-20 LOAD RATED WETWELL HATCH SEE ? M? | 10 NEW 10" BLIND FLANGE |
| 2 NEW 14'-0" X 8'-0" CONCRETE VAULT | 11 NEW FLANGED 10" X 8" WYE, TYP. OF 2. |
| 3 NEW 8" FLG X PE PIPE SPOOL LENGTH AS REQUIRED, TYP. OF 2. | 12 NEW 10" WAFER STYLE PRESSURE SENSOR. SEE ? M? |
| 4 NEW 8" MJ 90° ELBOW, TYP. OF 4 | 13 10" DISMANTLING JNT. W/TIE RODS |
| 5 NEW 8" FLG 90° ELBOW. TYP. OF 3. | 14 NEW COMBINATION AIR RELEASE VALVE, TYP. OF 2. |
| 6 NEW FLG 8" CHECK VALVE, TYP. OF 2. | 15 NEW 10" FLG 90° ELBOW. |
| 7 NEW FLG 8" PLUG VALVE, TYP. OF 3. | 16 NEW 18" MJ 90° ELBOW |
| 8 NEW 8" FLG PIPE SPOOL, LENGTH AS REQUIRED | 17 NEW 18" FLG 90° ELBOW |
| 9 NEW 10" MJ 90° ELBOW | 18 NEW 18" FLG PIPE SPOOL, LENGTH AS REQUIRED |

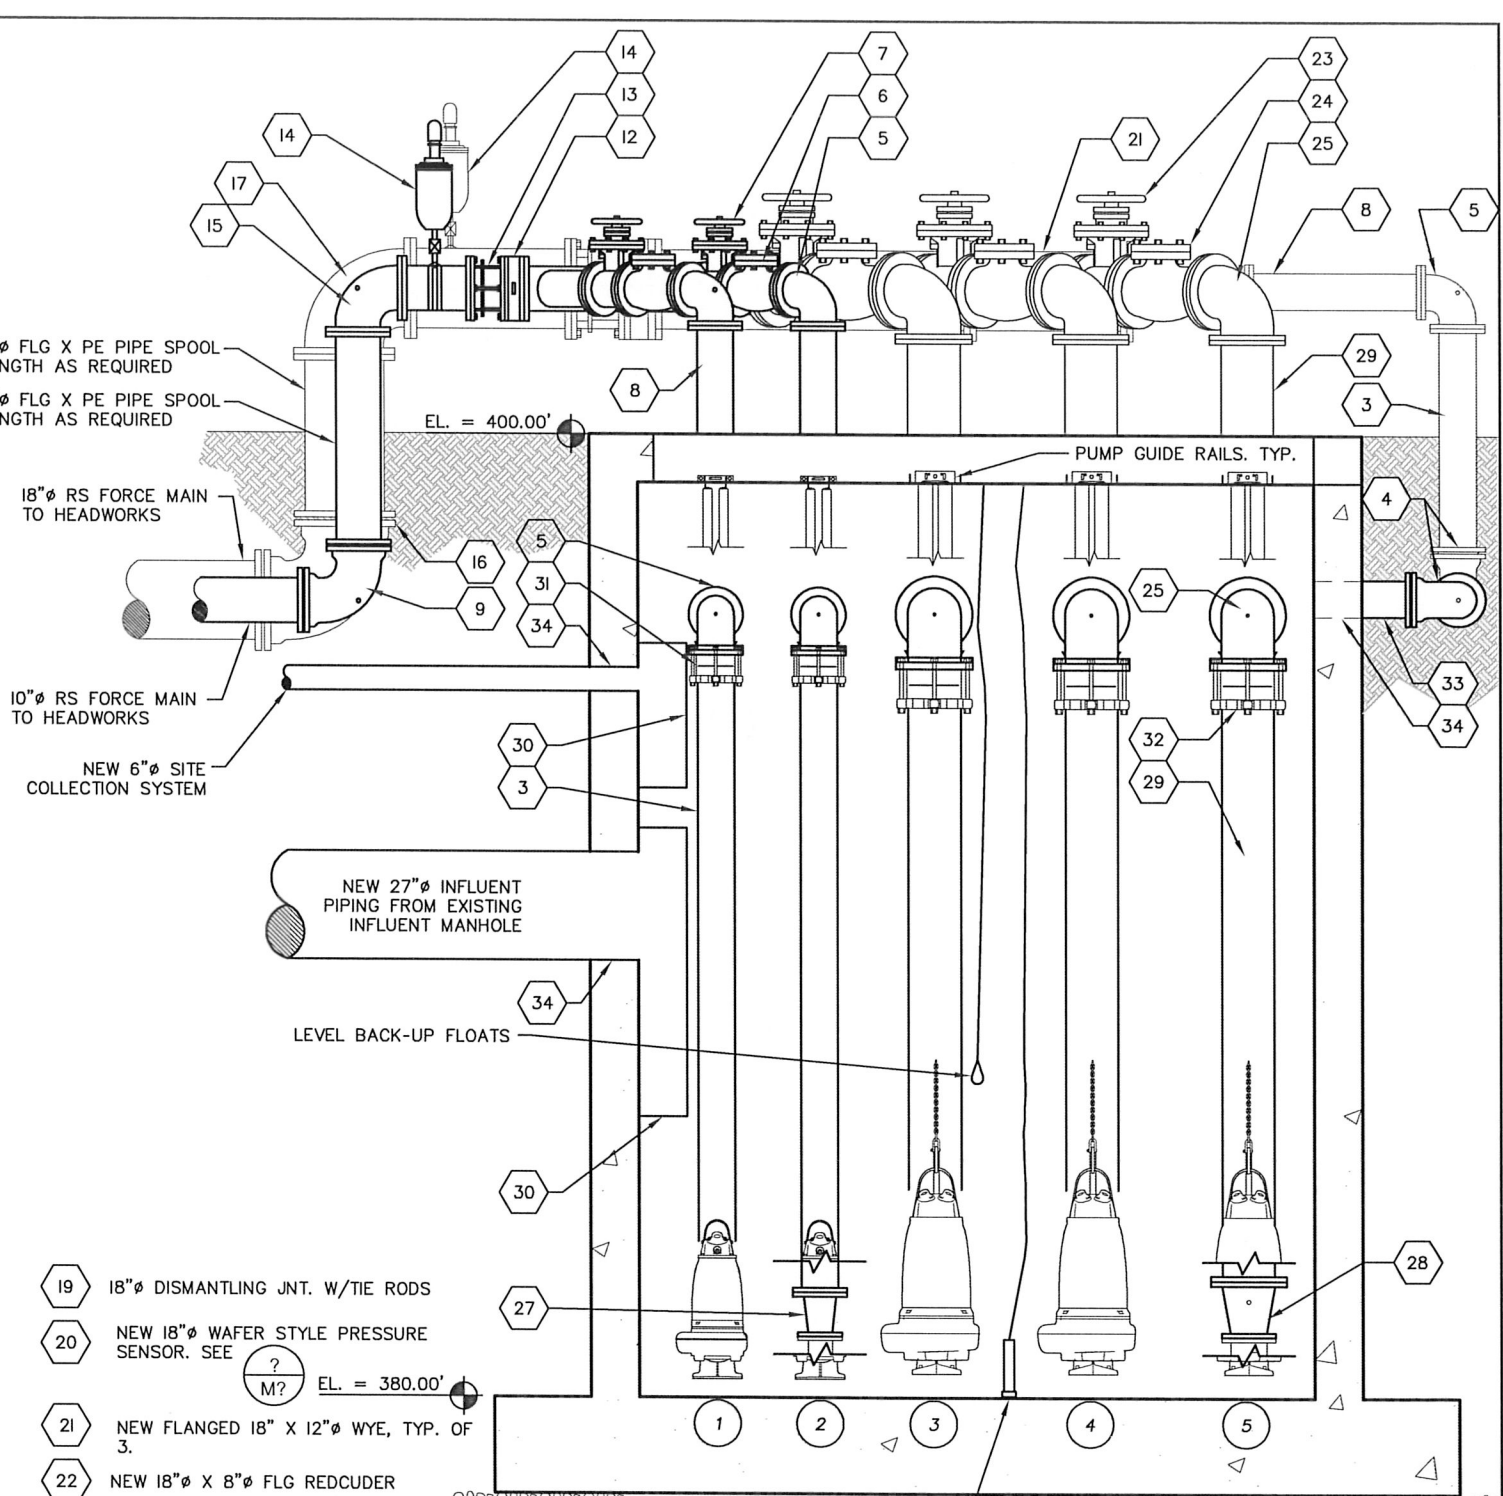

- | | | |
|--|--|---|
| 19 18" DISMANTLING JNT. W/TIE RODS | 27 NEW 8" X 6" FLG REDUCER, TYP. OF 2. | 32 NEW 12" FLANGED COUPLING ADAPTOR, TYP. OF 3 |
| 20 NEW 18" WAFER STYLE PRESSURE SENSOR. SEE ? M? EL. = 380.00' | | 33 NEW 8" PIPE SPOOL, LENGTH AS REQUIRED |
| 21 NEW FLANGED 18" X 12" WYE, TYP. OF 3. | | 34 PIPE PENETRATION, SEE TYPICAL FOR ALL PIPES ? M? |
| 22 NEW 18" X 8" FLG REDUCER | | |
| 23 NEW FLG 12" PLUG VALVE, TYP. OF 3. | | |
| 24 NEW FLG 12" CHECK VALVE, TYP. OF 3. | | |
| 25 NEW 12" FLG 90° ELBOW. TYP. OF 3. | | |
| 26 NEW 12" MJ 90° ELBOW, TYP. OF 3 | | |
| 28 NEW 12" X 8" FLG REDUCER, TYP. OF 3 | | |
| 29 NEW 12" FLG X PE PIPE SPOOL, LENGTH AS REQUIRED | | |
| 30 INFLUENT DEFLECTOR, SEE ? M? | | |
| 31 NEW 8" FLANGED COUPLING ADAPTOR, TYP. OF 2. | | |




SUBMITTED BY:	DATE:	REVISIONS					DESIGNED:
		REVISED	DESCRIPTION	SUBMIT	APPR'D	DATE	
							CGP
							DRAWN: CGP
							CHECKED: AJS
							APPROVED: SBM

THE DYER PARTNERSHIP ENGINEERS & PLANNERS, INC.
1330 TEAKWOOD AVENUE
COOS BAY, OREGON 97420
TELEPHONE: (541) 269-0732
www.dyerpart.com

LINE IS 1 INCH AT FULL SCALE
IF NOT 1-INCH - SCALE ACCORDINGLY

WASTEWATER TREATMENT PLANT IMPROVEMENTS		PROJECT NO.	DRAWING NO.
CITY OF SUTHERLIN		146.38	M700
INFLUENT PUMP STATION		DATE	SHEET NO.
MECHANICAL PLAN AND ELEVATION VIEW		MAY 2016	39 OF 70

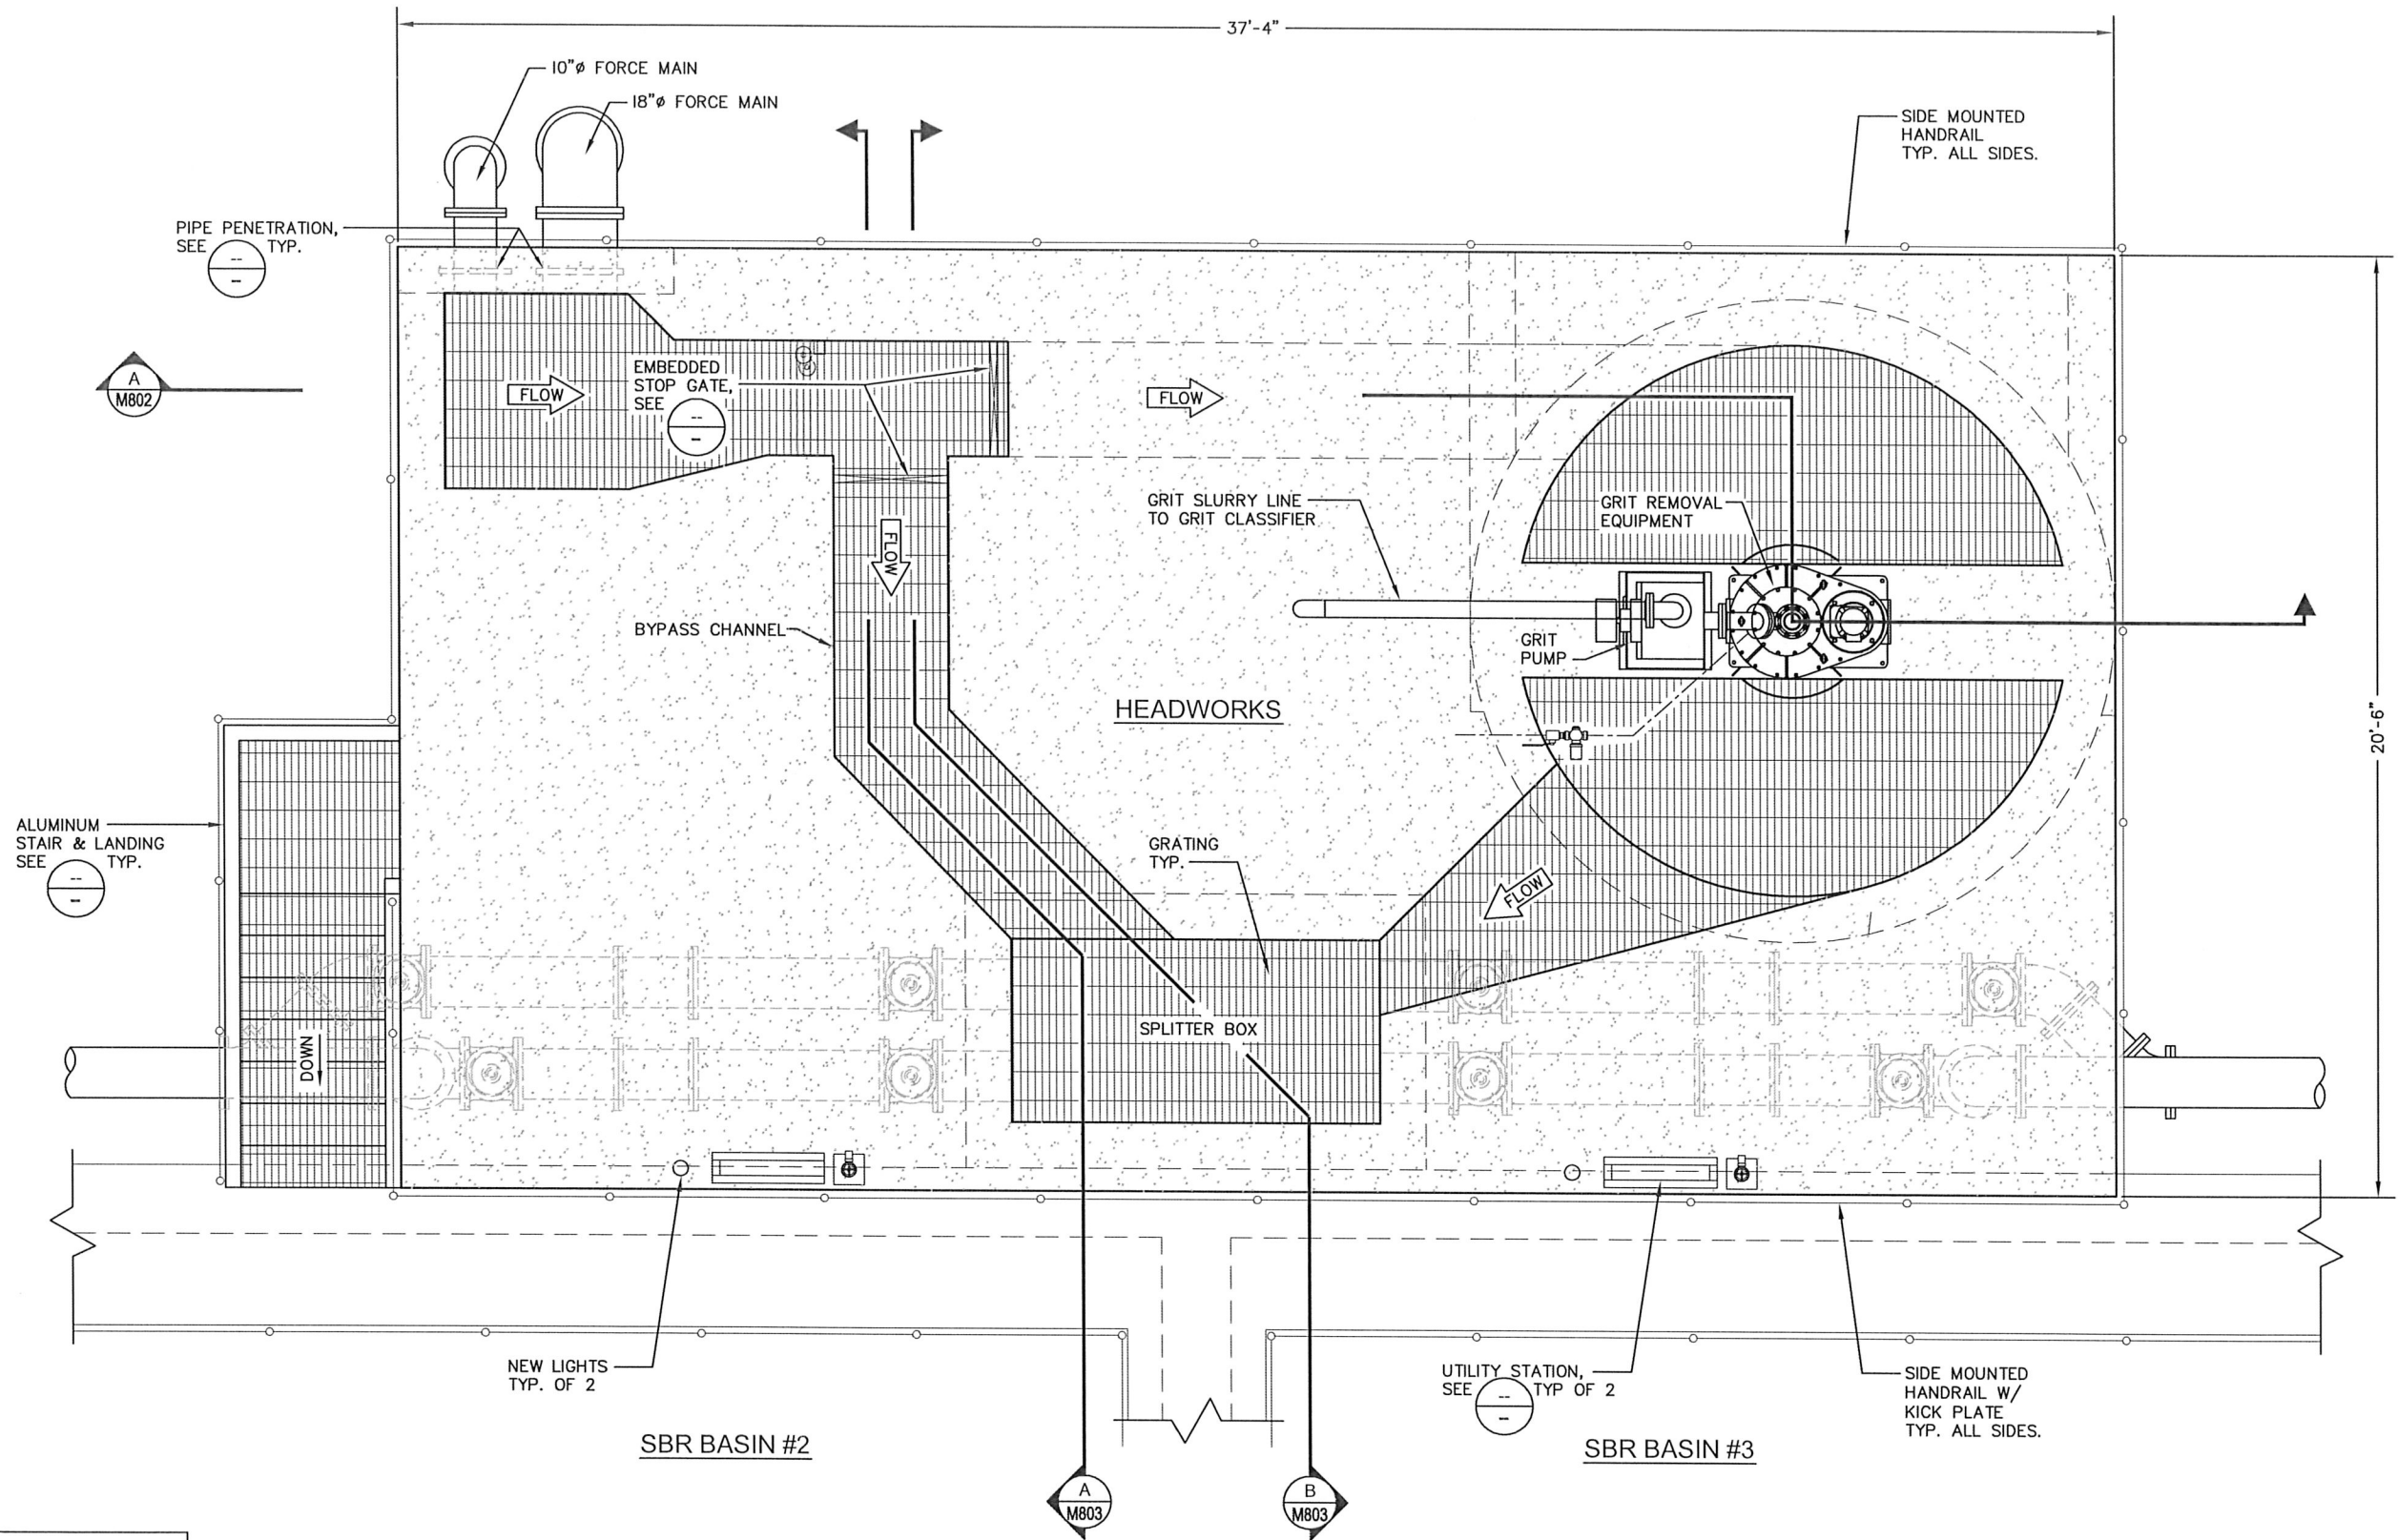

HEADWORKS - UPPER PLAN
SCALE: 1" = 4'-0"



SUBMITTED BY: _____ DATE: _____

APPROVED BY: _____ DATE: _____

REVISIONS				
REVISED	DESCRIPTION	SUBMIT	APPR'D	DATE

DESIGNED: AJS

DRAWN: DLS

CHECKED: SBM

APPROVED: _____




THE DYER PARTNERSHIP
ENGINEERS & PLANNERS, INC.
1330 TEAKWOOD AVENUE
COOS BAY, OREGON 97420
TELEPHONE: (541) 269-0732
www.dyerpart.com

LINE IS 1 INCH
AT FULL SCALE
IF NOT 1-INCH - SCALE ACCORDINGLY

WASTEWATER TREATMENT PLANT IMPROVEMENTS
CITY OF SUTHERLIN

HEADWORKS
MECHANICAL-UPPER PLAN VIEW

PROJECT NO.	DRAWING NO.
146.38	M800
DATE	SHEET NO.
MAY 2016	40 OF 70

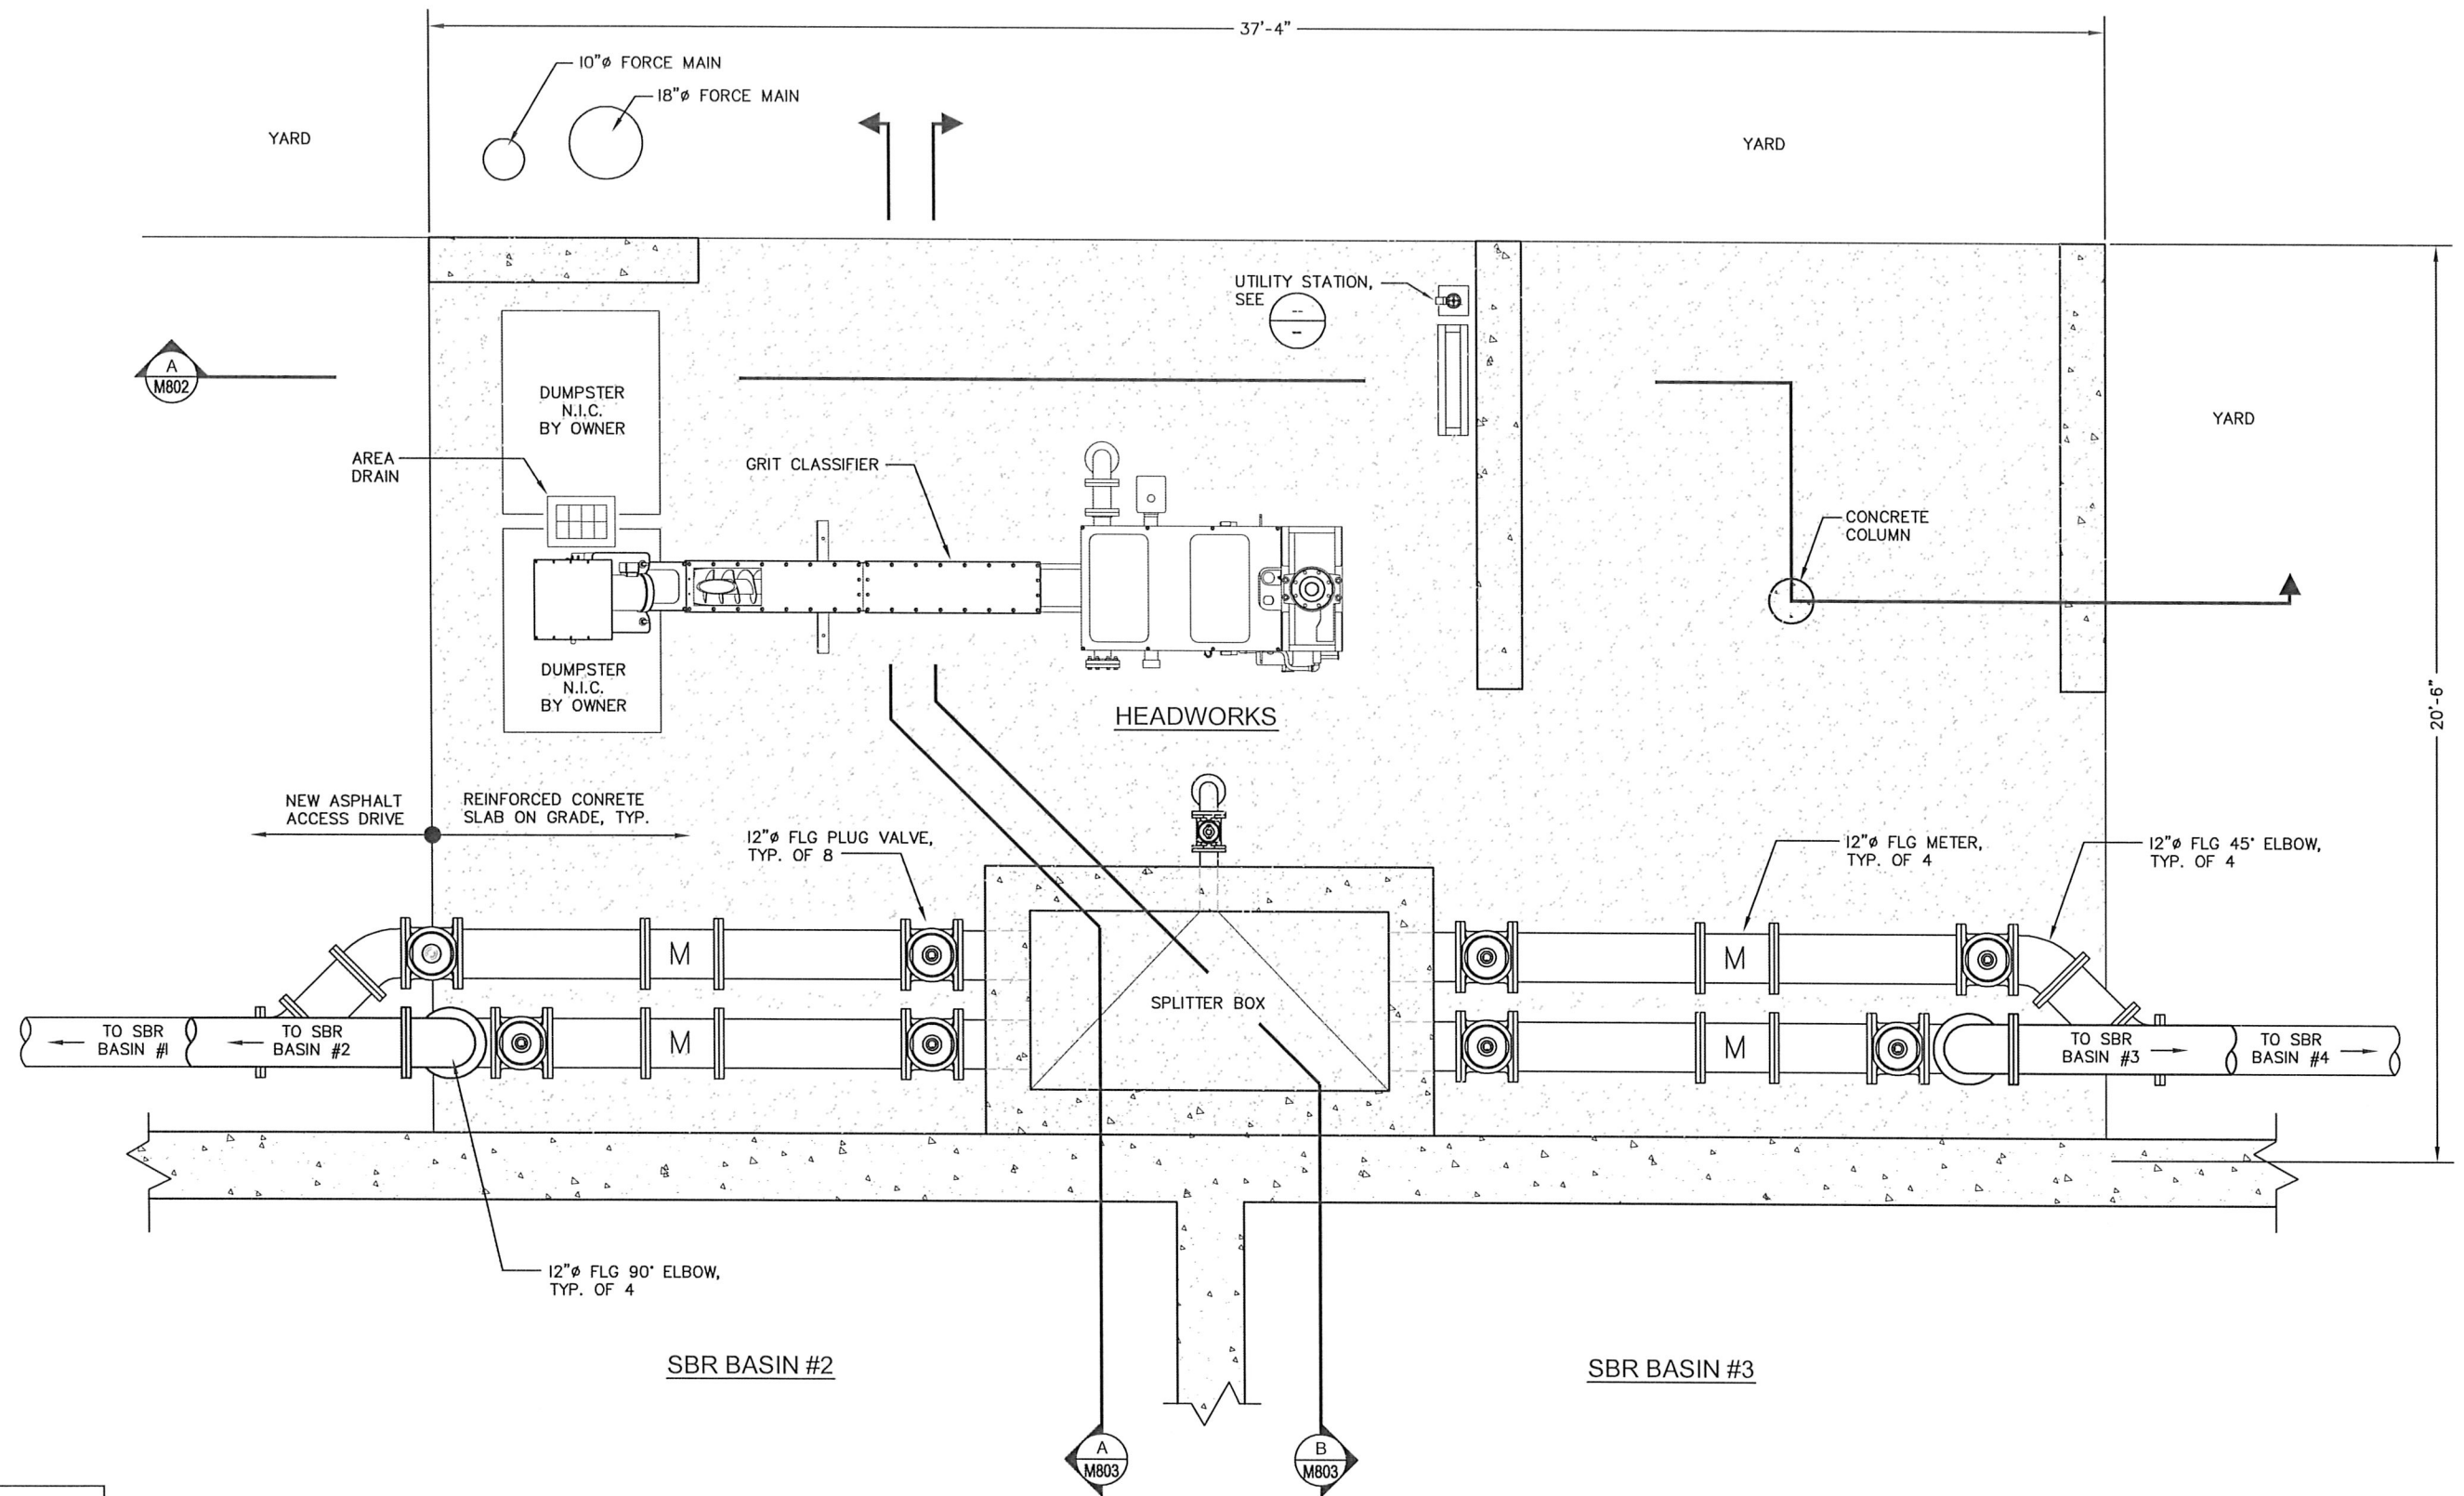

HEADWORKS - LOWER PLAN
SCALE: 1" = 4'-0"

1
M801



SUBMITTED BY: _____ DATE: _____
APPROVED BY: _____ DATE: _____

REVISIONS				
REVISED	DESCRIPTION	SUBMIT	APPR'D	DATE

DESIGNED:
AJS
DRAWN:
DLS
CHECKED:
SBM
APPROVED:




THE DYER PARTNERSHIP
ENGINEERS & PLANNERS, INC.
1330 TEAKWOOD AVENUE
COOS BAY, OREGON 97420
TELEPHONE: (541) 269-0732
www.dyerpart.com

LINE IS 1 INCH
AT FULL SCALE
IF NOT 1-INCH - SCALE ACCORDINGLY

WASTEWATER TREATMENT PLANT IMPROVEMENTS
CITY OF SUTHERLIN
HEADWORKS
MECHANICAL- LOWER PLAN VIEW

PROJECT NO.	DRAWING NO.
146.38	M801
DATE	SHEET NO.
MAY 2016	41 OF 70

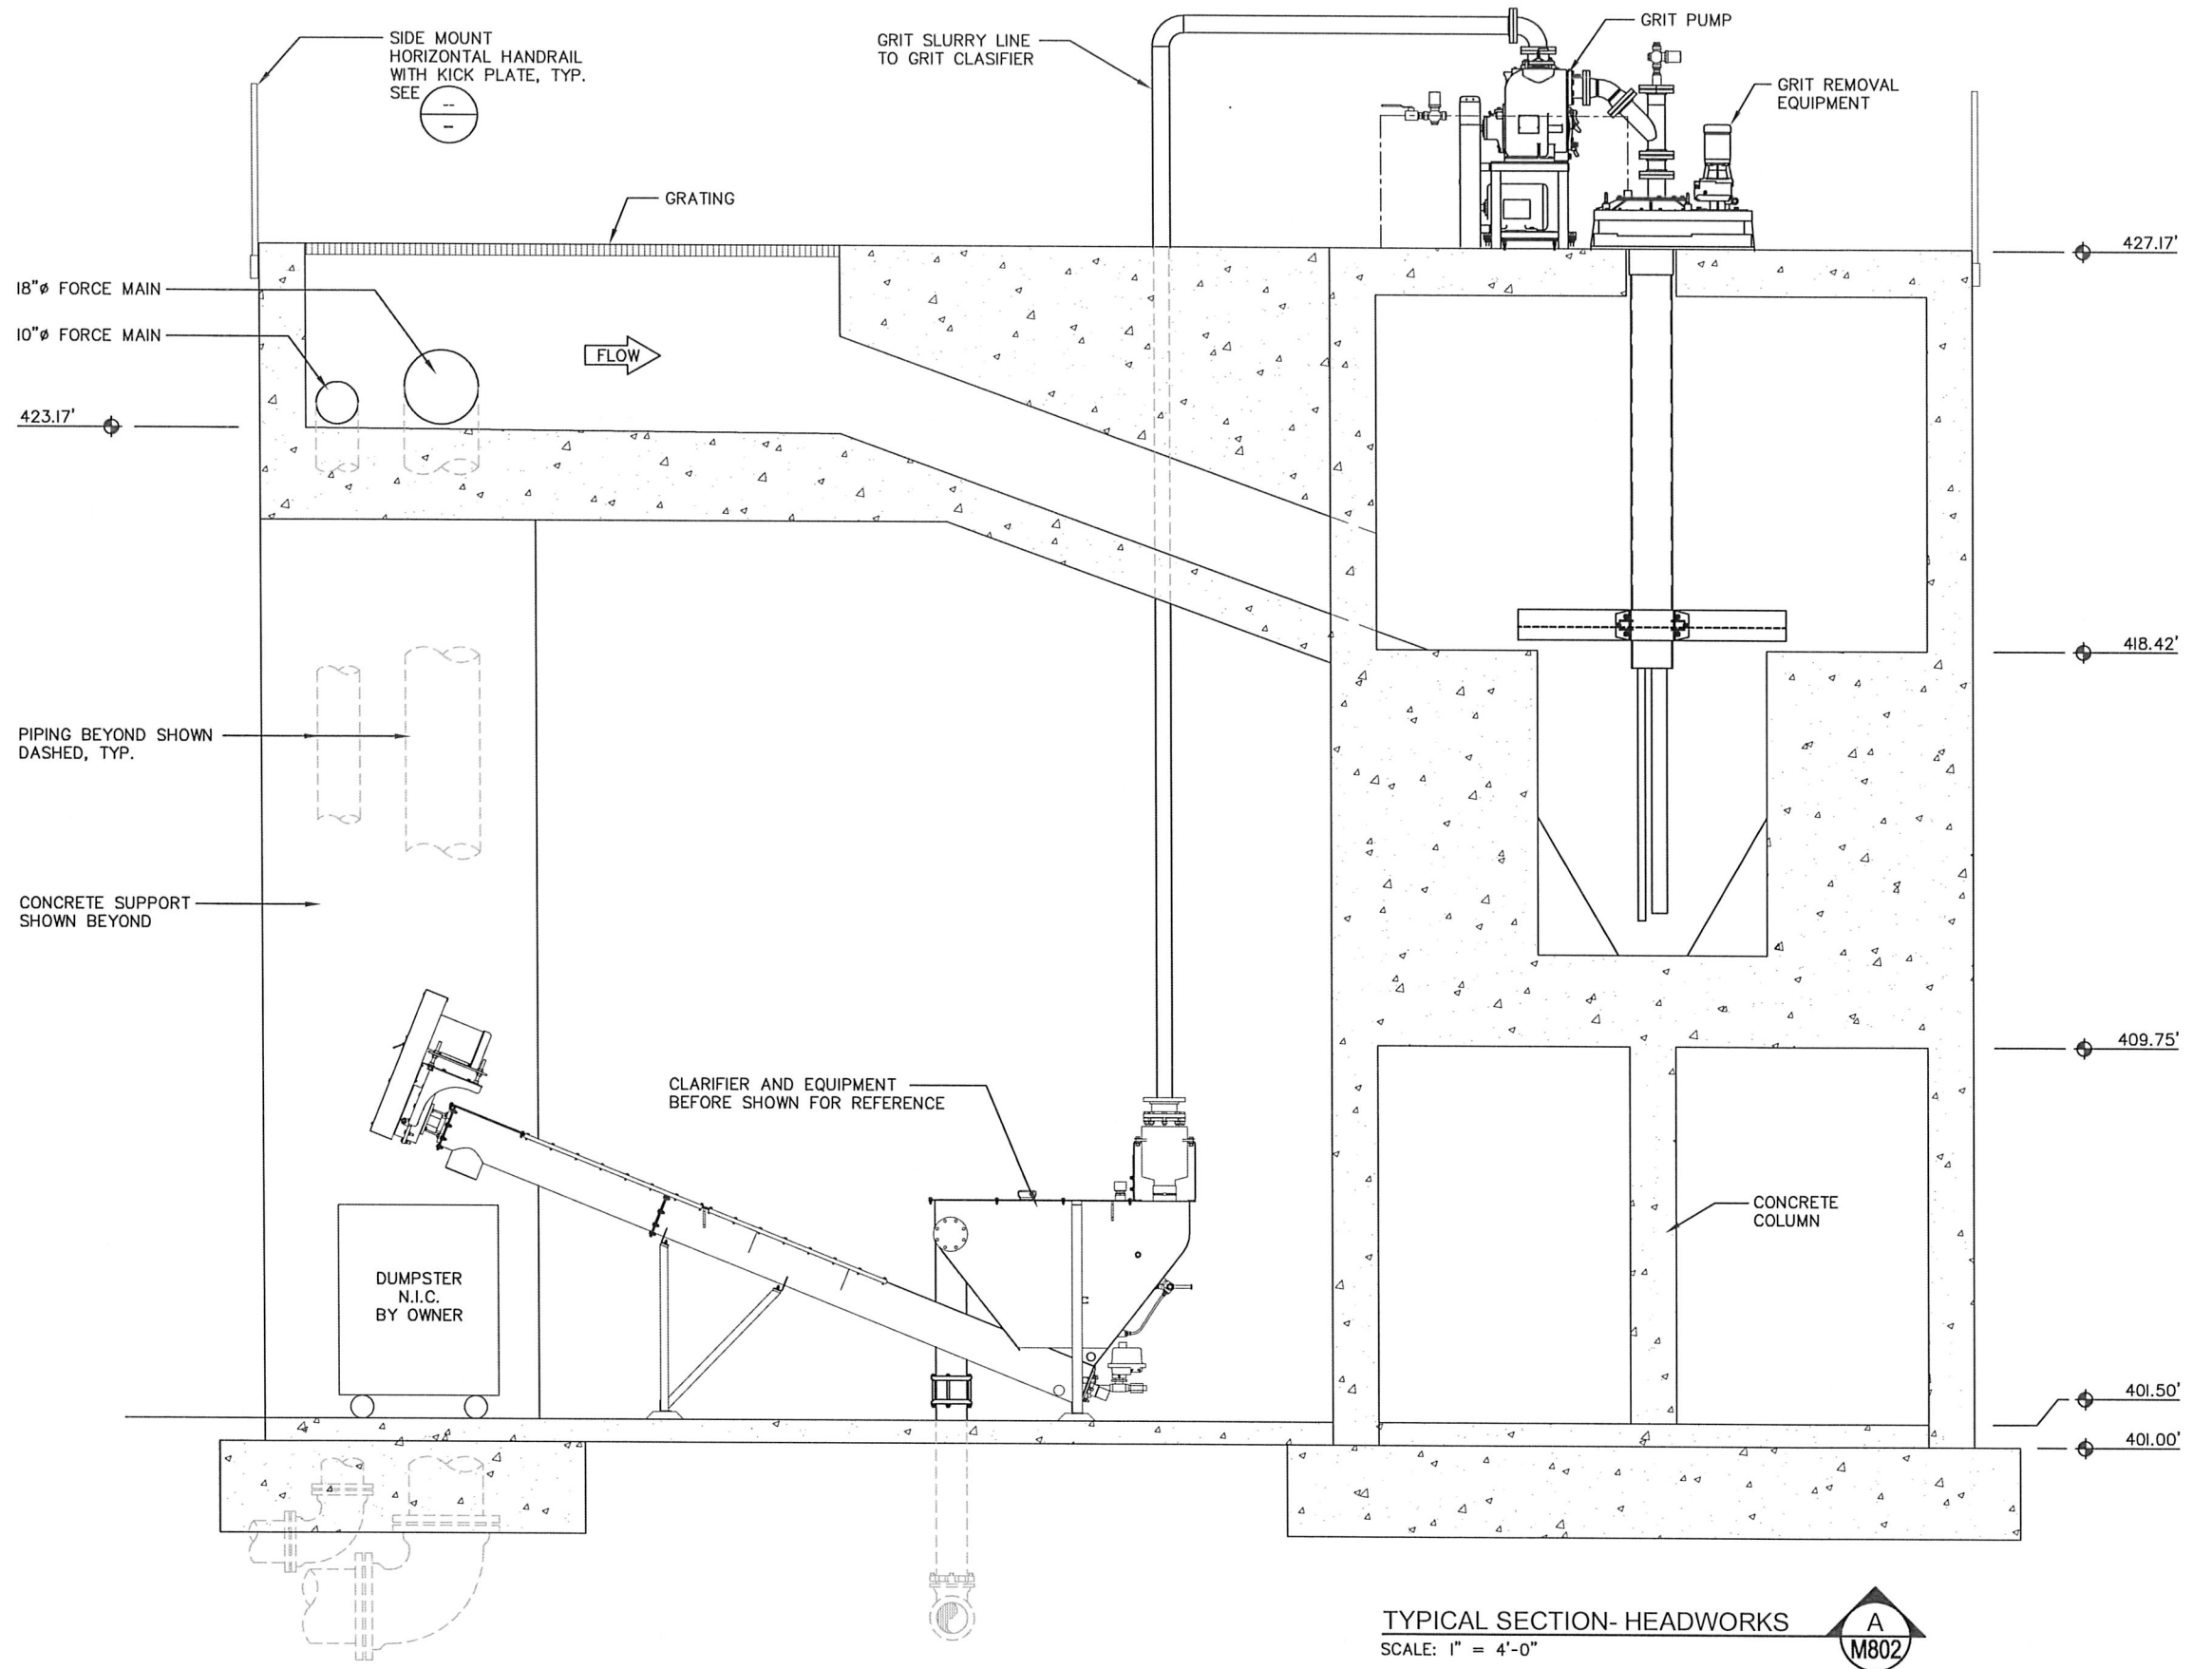

SUBMITTED BY: _____ DATE: _____
APPROVED BY: _____ DATE: _____

REVISIONS				
REVISED	DESCRIPTION	SUBMIT	APPR'D	DATE



DESIGNED: AJS
DRAWN: DLS
CHECKED: SBM
APPROVED: _____



THE DYER PARTNERSHIP
ENGINEERS & PLANNERS, INC.
1330 TEAKWOOD AVENUE
COOS BAY, OREGON 97420
TELEPHONE: (541) 269-0732
www.dyerpart.com

LINE IS 1 INCH
AT FULL SCALE
IF NOT 1-INCH - SCALE ACCORDINGLY

WASTEWATER TREATMENT PLANT IMPROVEMENTS CITY OF SUTHERLIN		PROJECT NO. 146.38	DRAWING NO. M802
HEADWORKS MECHANICAL- TYPICAL SECTION		DATE MAY 2016	SHEET NO. 42 OF 70

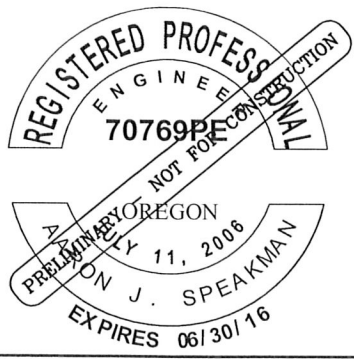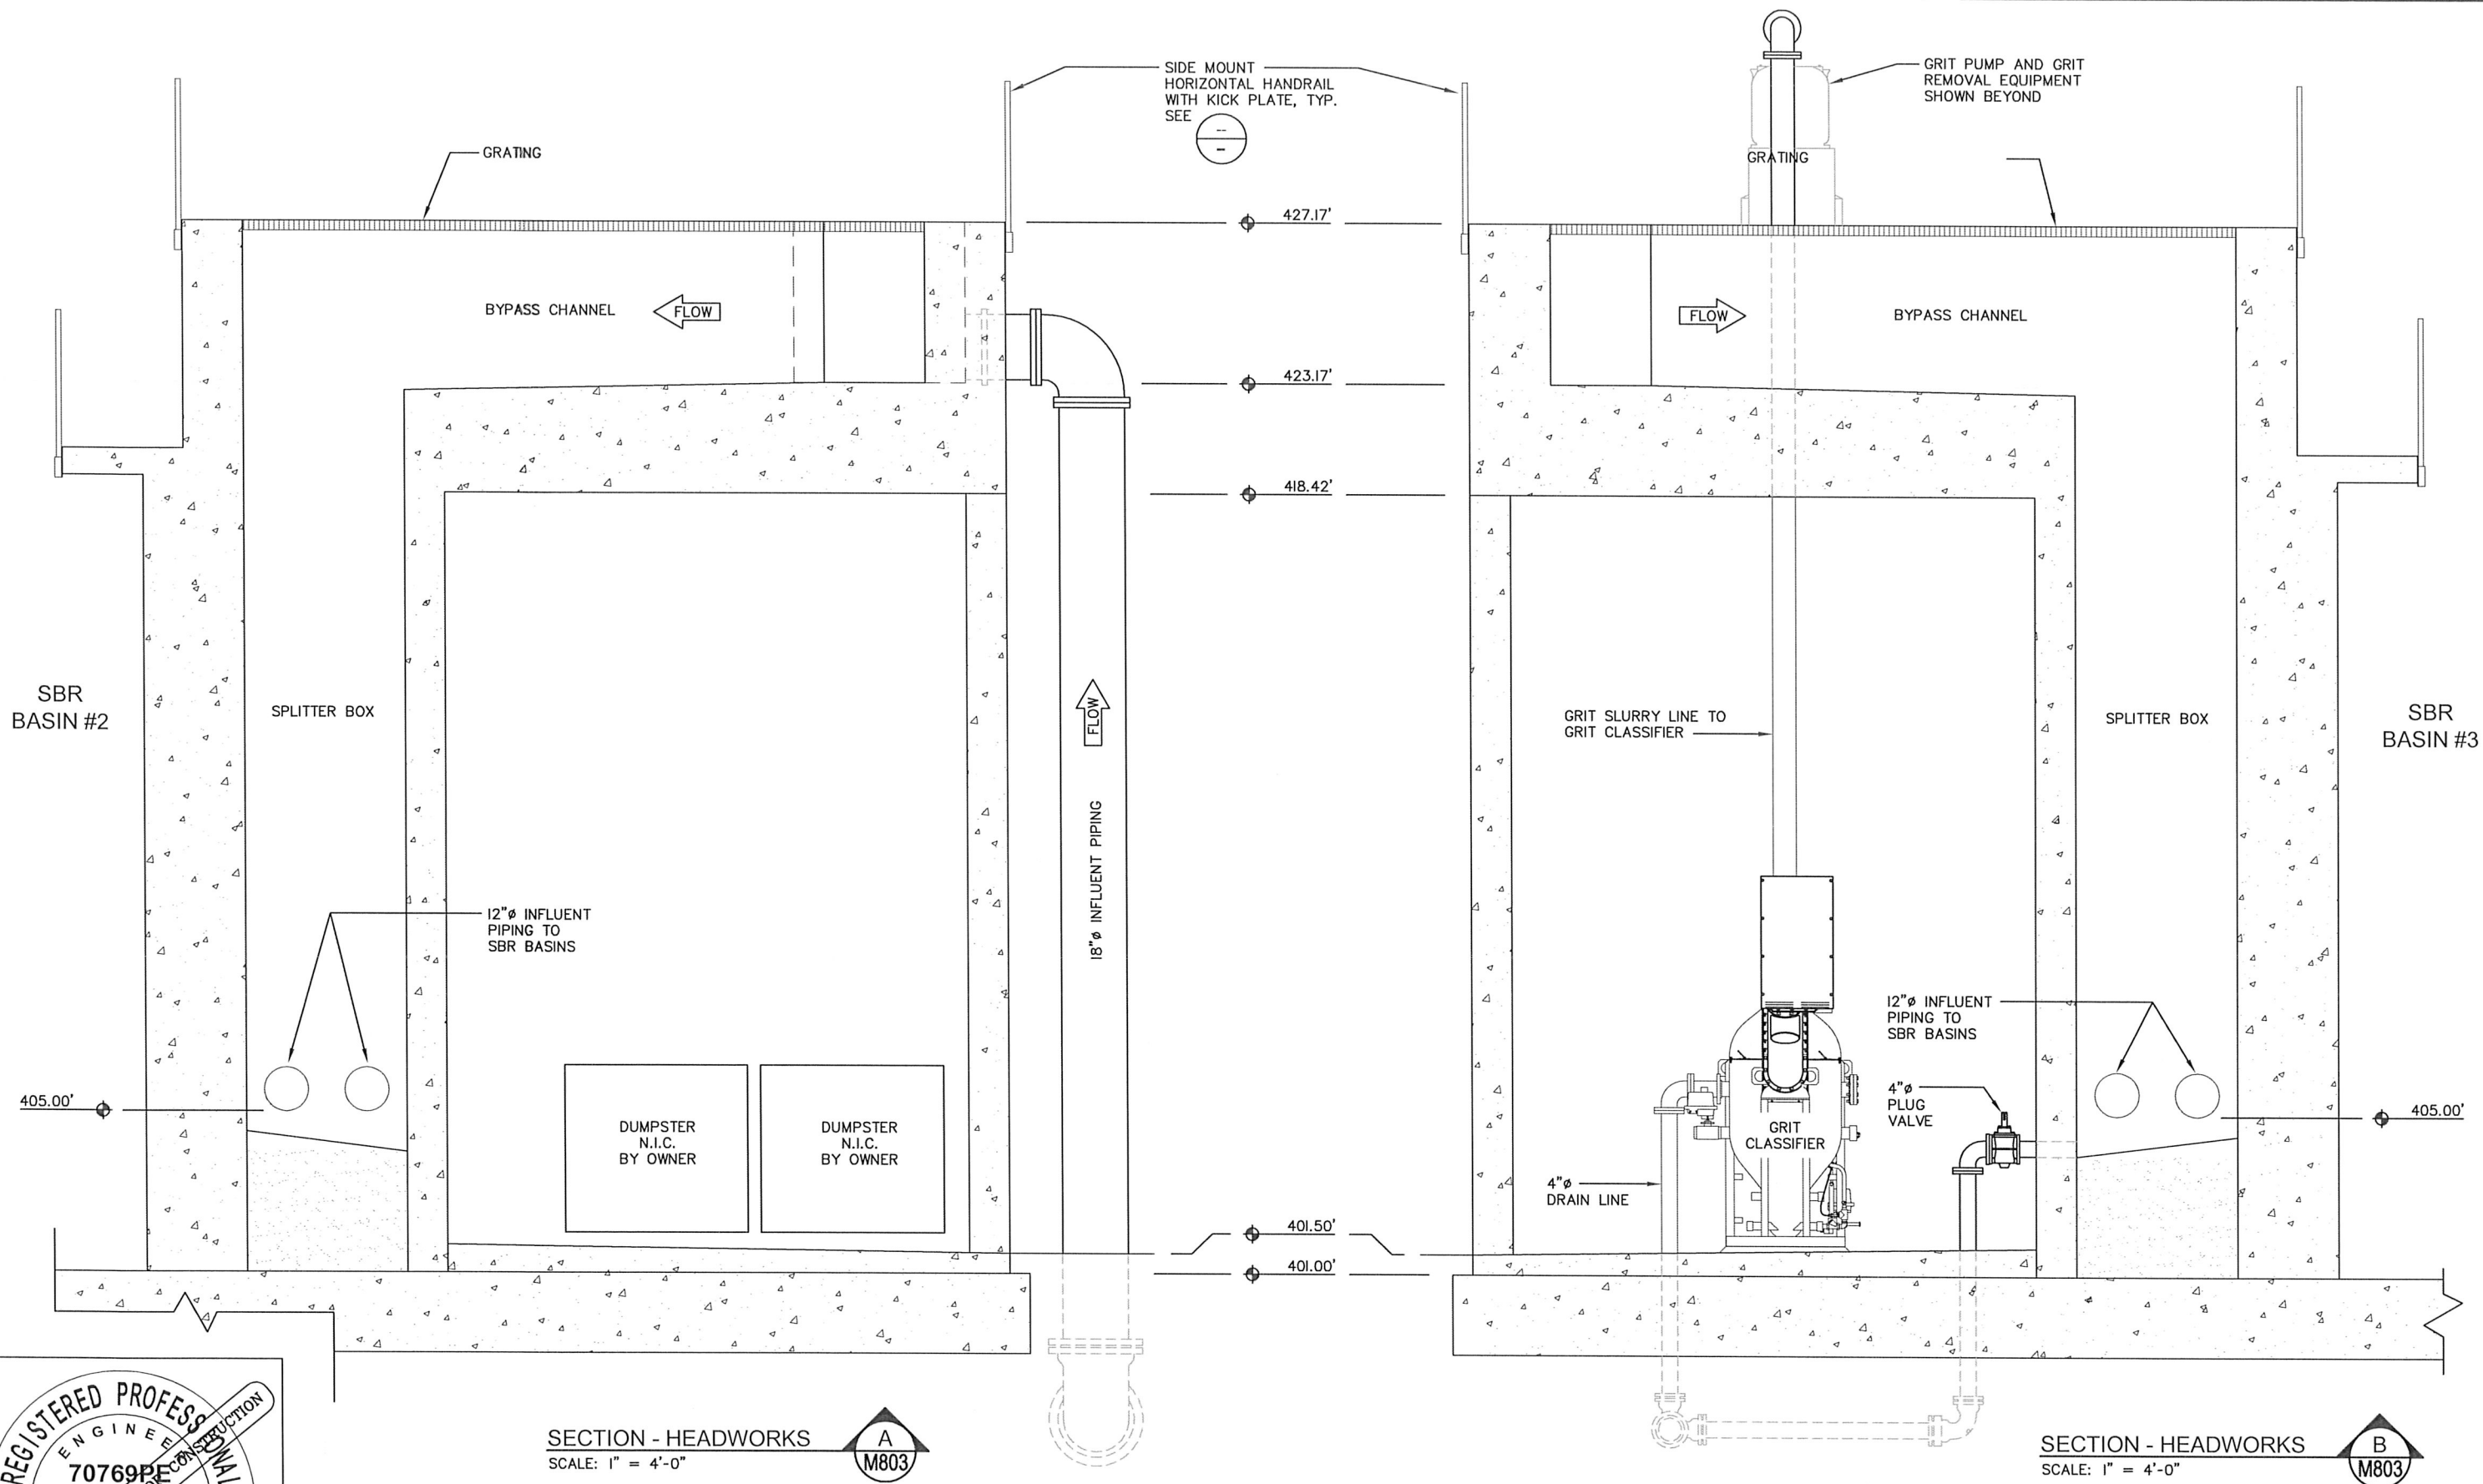

SECTION - HEADWORKS
SCALE: 1" = 4'-0"

A
M803

SECTION - HEADWORKS
SCALE: 1" = 4'-0"

B
M803


SUBMITTED BY:	DATE:	REVISIONS					DESIGNED: AJS
		REVISED	DESCRIPTION	SUBMIT	APPR'D	DATE	
APPROVED BY:	DATE:						DRAWN: DLS
							CHECKED: SBM
							APPROVED:



THE DYER PARTNERSHIP
ENGINEERS & PLANNERS, INC.
1330 TEAKWOOD AVENUE
COOS BAY, OREGON 97420
TELEPHONE: (541) 269-0732
www.dyerpart.com

LINE IS 1 INCH
AT FULL SCALE
IF NOT 1-INCH - SCALE ACCORDINGLY

WASTEWATER TREATMENT PLANT IMPROVEMENTS CITY OF SUTHERLIN		PROJECT NO. 146.38	DRAWING NO. M803
HEADWORKS MECHANICAL- TYPICAL SECTION		DATE MAY 2016	SHEET NO. 43 OF 70

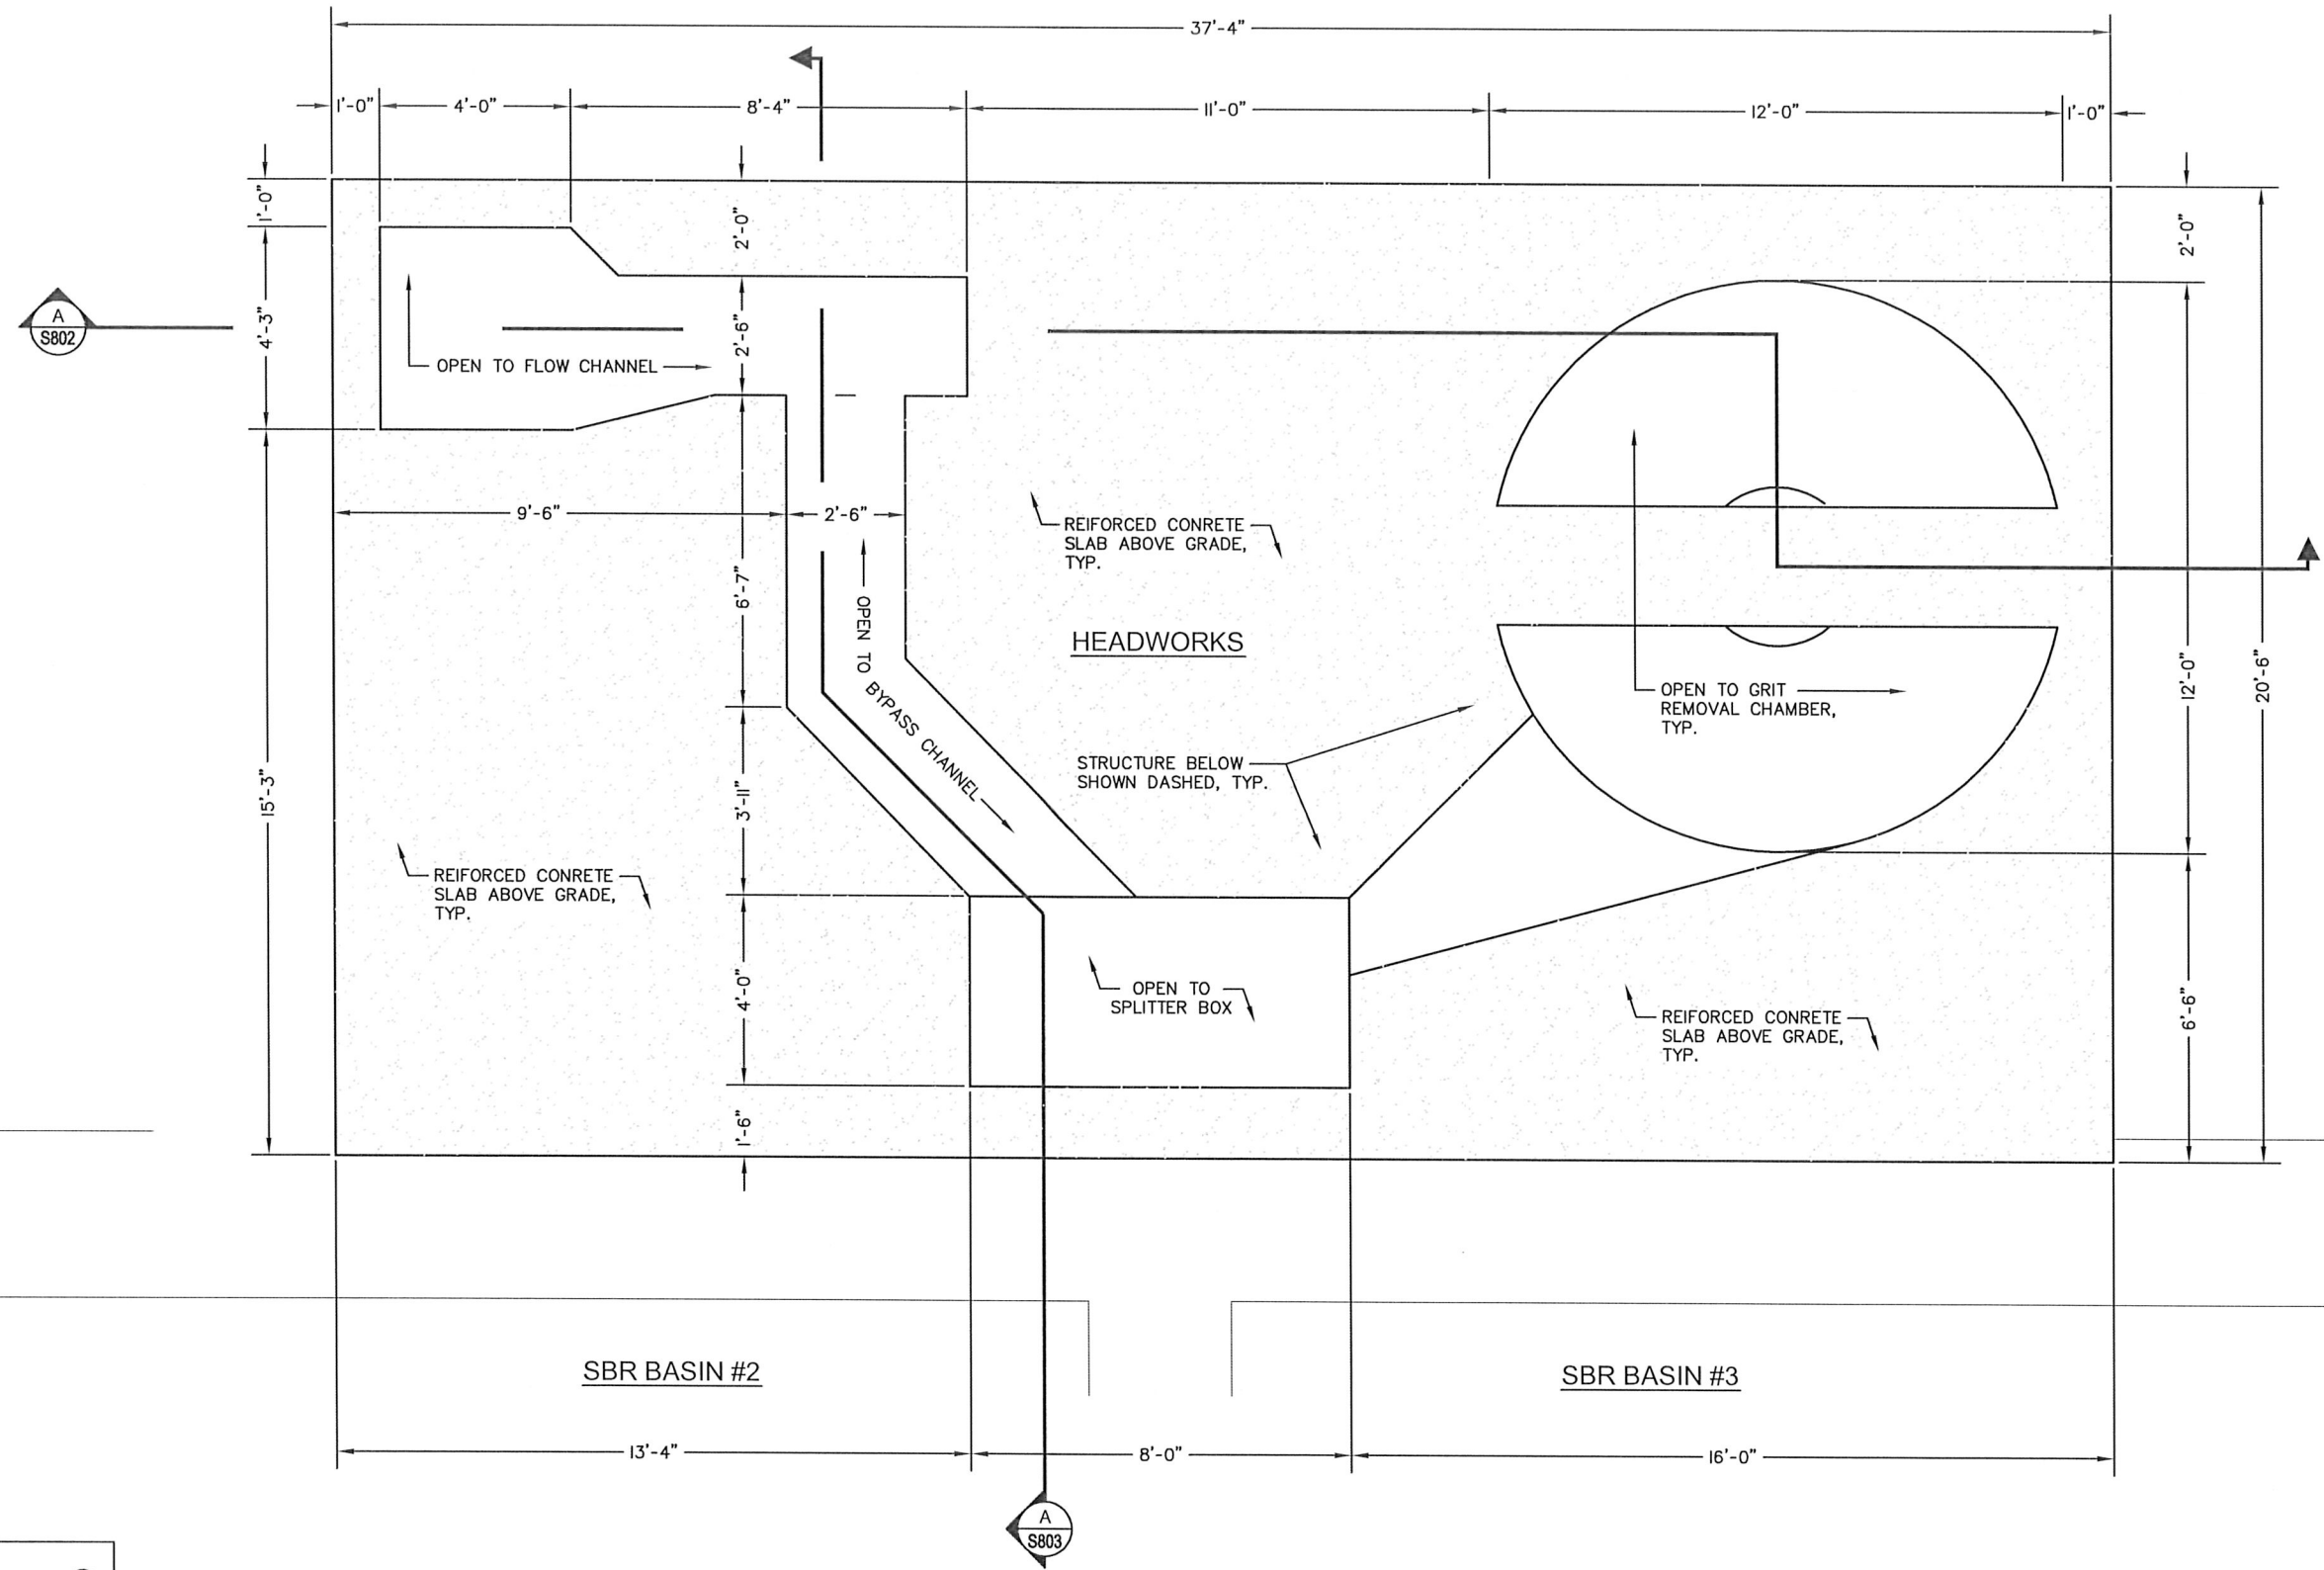

HEADWORKS - UPPER PLAN
SCALE: 1" = 4'-0"

1
S800



SUBMITTED BY: _____ DATE: _____
APPROVED BY: _____ DATE: _____

REVISIONS					
REVISED	DESCRIPTION	SUBMIT	APPR'D	DATE	

DESIGNED: AJS
DRAWN: DLS
CHECKED: SBM
APPROVED: _____




THE DYER PARTNERSHIP
ENGINEERS & PLANNERS, INC.
1330 TEAKWOOD AVENUE
COOS BAY, OREGON 97420
TELEPHONE: (541) 269-0732
www.dyerpart.com

LINE IS 1 INCH
AT FULL SCALE
IF NOT 1-INCH - SCALE ACCORDINGLY

WASTEWATER TREATMENT PLANT IMPROVEMENTS
CITY OF SUTHERLIN
HEADWORKS
STRUCTURAL- UPPER PLAN VIEW

PROJECT NO. 146.38	DRAWING NO. S800
DATE MAY 2016	SHEET NO. 44 OF 70

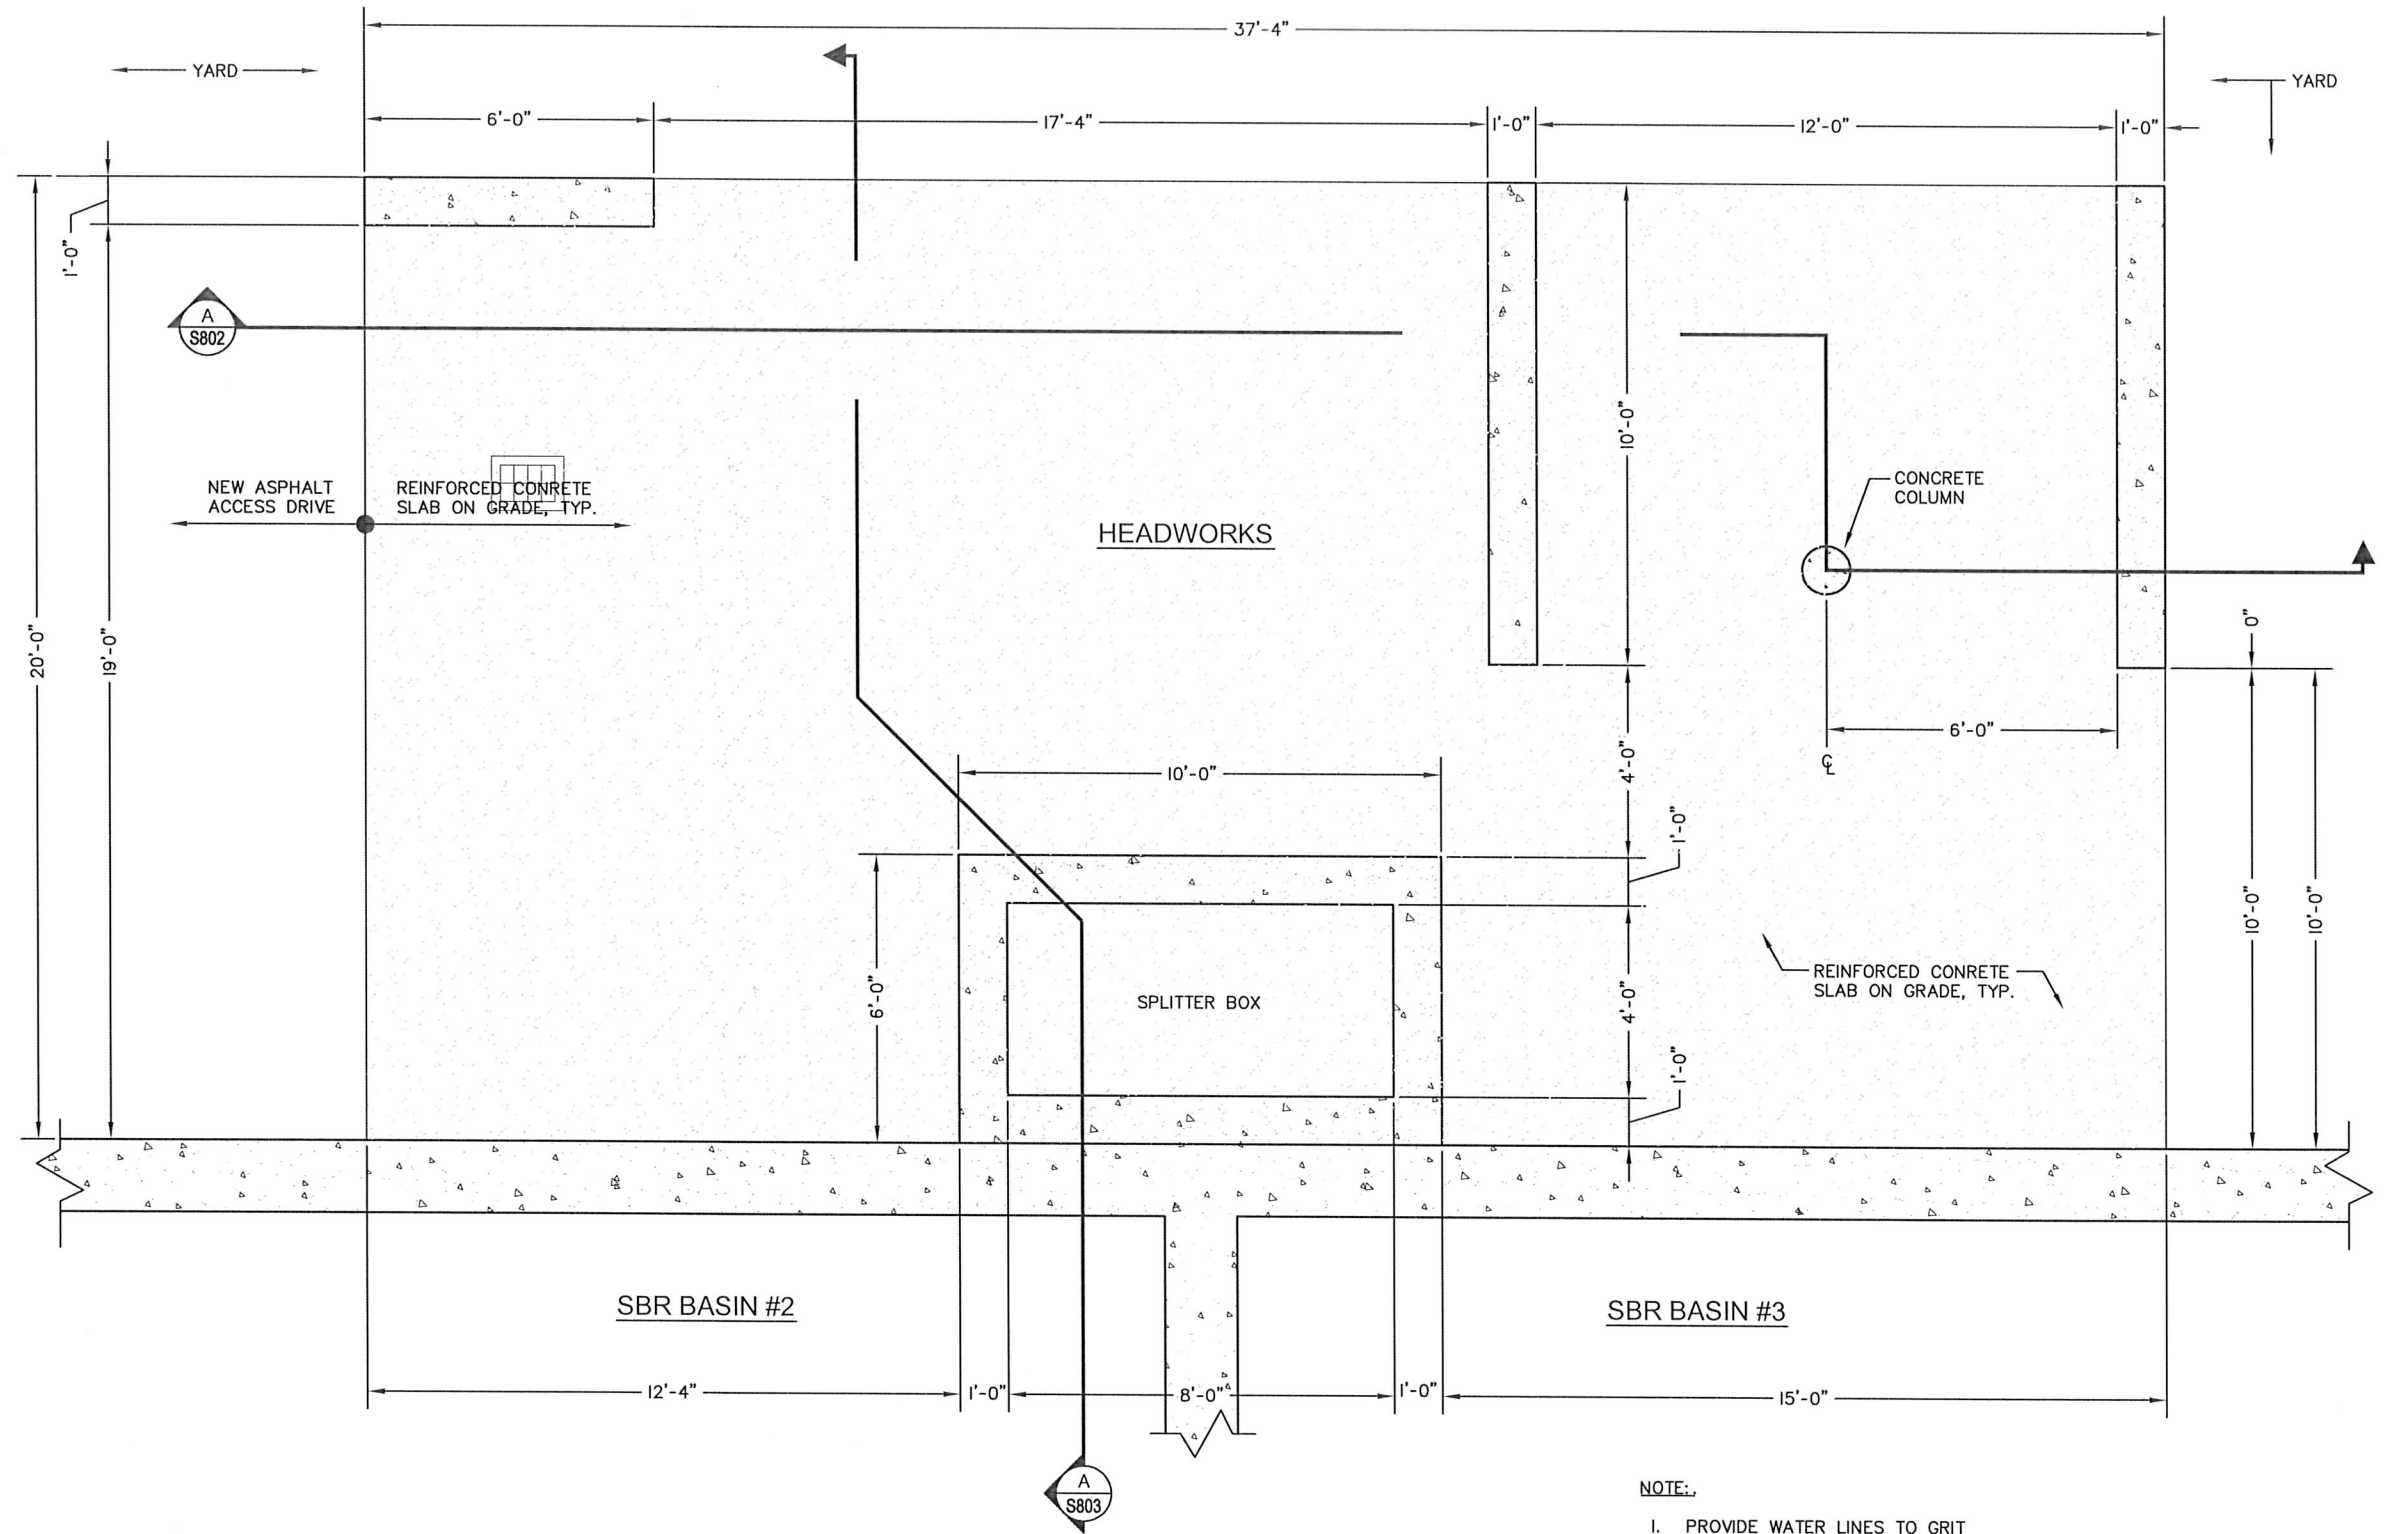

HEADWORKS - LOWER PLAN
SCALE: 1" = 4'-0"

1
S801

NOTE:

1. PROVIDE WATER LINES TO GRIT CLASSIFIER AND VORTEX GRIT REMOVAL EQUIPMENT. COORDINATE WITH MANUFACTURER.
2. PROVIDE MIN. OF TWO TRANSITION COUPLINGS ON ALL PIPES TRANSITIONING FROM SBR TO GROUND FOR SEISMIC ADJUSTMENT, TYPICAL.



SUBMITTED BY:	DATE:
APPROVED BY:	DATE:

REVISIONS				
REVISED	DESCRIPTION	SUBMIT	APPR'D	DATE


DESIGNED:	AJS
DRAWN:	DLS
CHECKED:	SBM
APPROVED:	



THE DYER PARTNERSHIP
ENGINEERS & PLANNERS, INC.
1330 TEAKWOOD AVENUE
COOS BAY, OREGON 97420
TELEPHONE: (541) 269-0732
www.dyerpart.com

LINE IS 1 INCH
AT FULL SCALE
IF NOT 1-INCH - SCALE ACCORDINGLY

WASTEWATER TREATMENT PLANT IMPROVEMENTS CITY OF SUTHERLIN		PROJECT NO. 146.38	DRAWING NO. S801
HEADWORKS STRUCTURAL- LOWER PLAN VIEW		DATE MAY 2016	SHEET NO. 45 OF 70

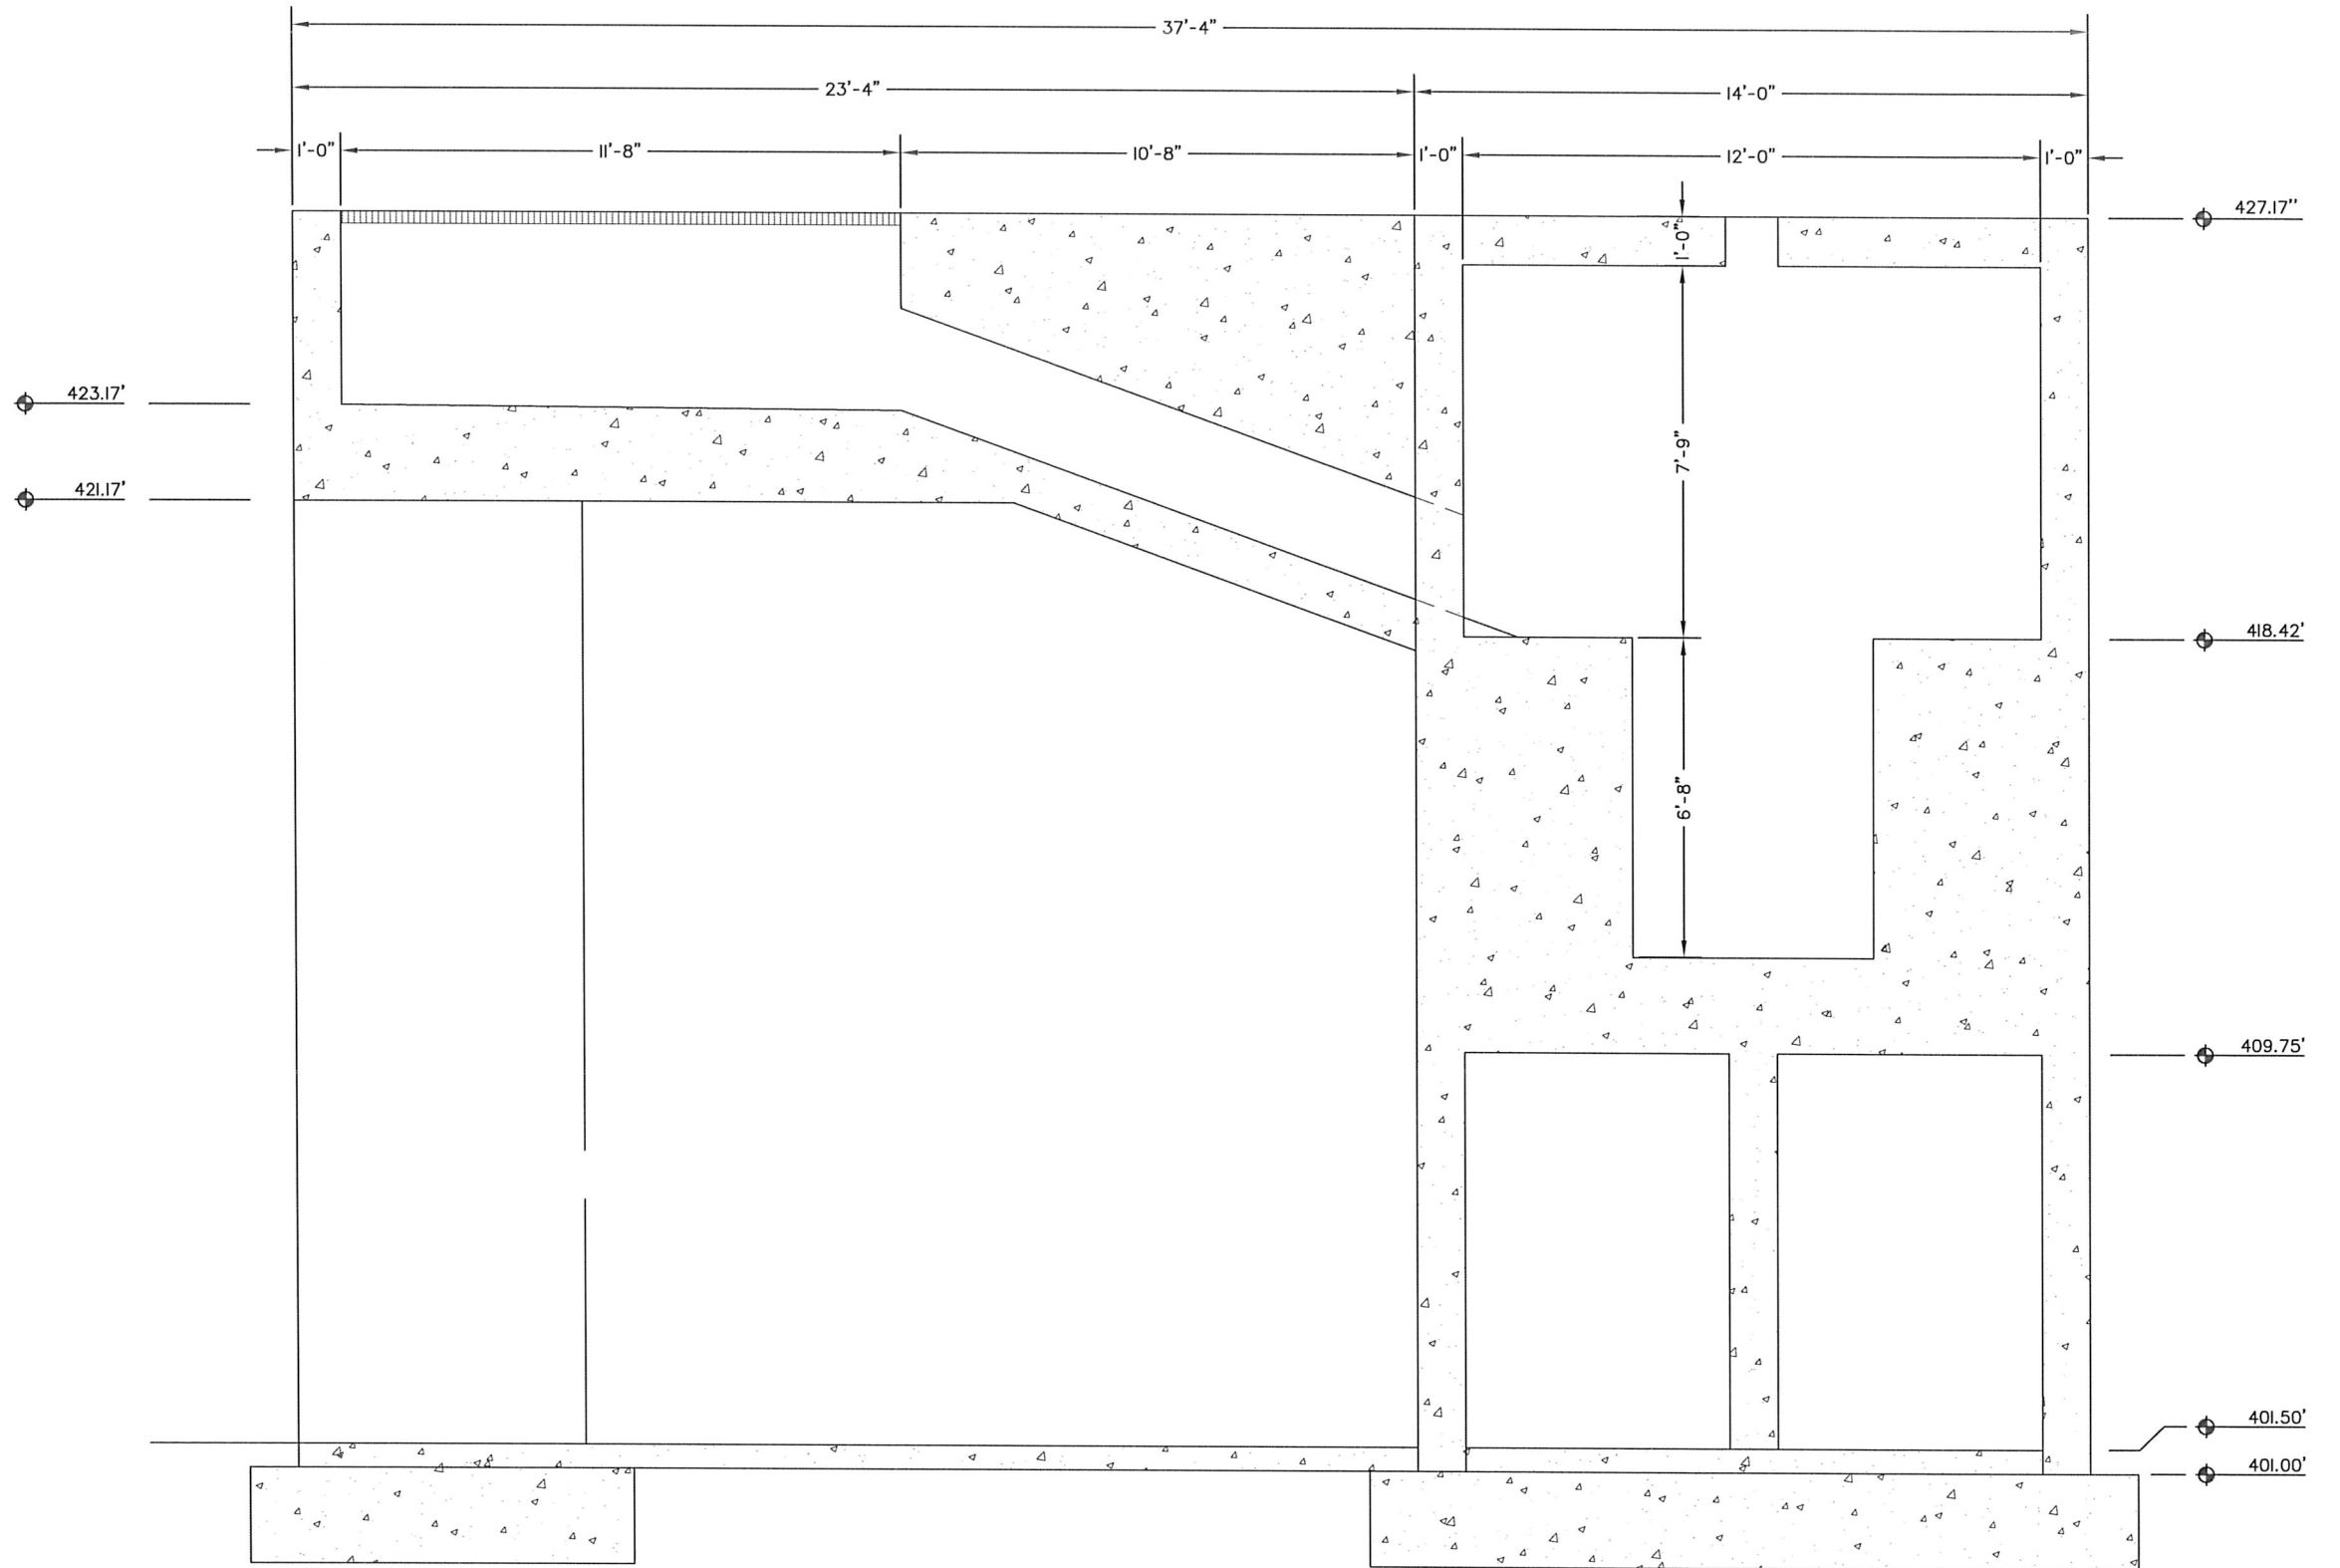

TYPICAL SECTION- HEADWORKS
SCALE: 1" = 4'-0"



SUBMITTED BY:	DATE:
APPROVED BY:	DATE:

REVISIONS				
REVISED	DESCRIPTION	SUBMIT	APPR'D	DATE


DESIGNED:	AJS
DRAWN:	DLS
CHECKED:	SBM
APPROVED:	



THE DYER PARTNERSHIP
ENGINEERS & PLANNERS, INC.
1330 TEAKWOOD AVENUE
COOS BAY, OREGON 97420
TELEPHONE: (541) 269-0732
www.dyerpart.com

LINE IS 1 INCH
AT FULL SCALE
IF NOT 1-INCH - SCALE ACCORDINGLY

WASTEWATER TREATMENT PLANT IMPROVEMENTS CITY OF SUTHERLIN		PROJECT NO. 146.38	DRAWING NO. S802
HEADWORKS STRUCTURAL- TYPICAL SECTION		DATE MAY 2016	SHEET NO. 46 OF 70

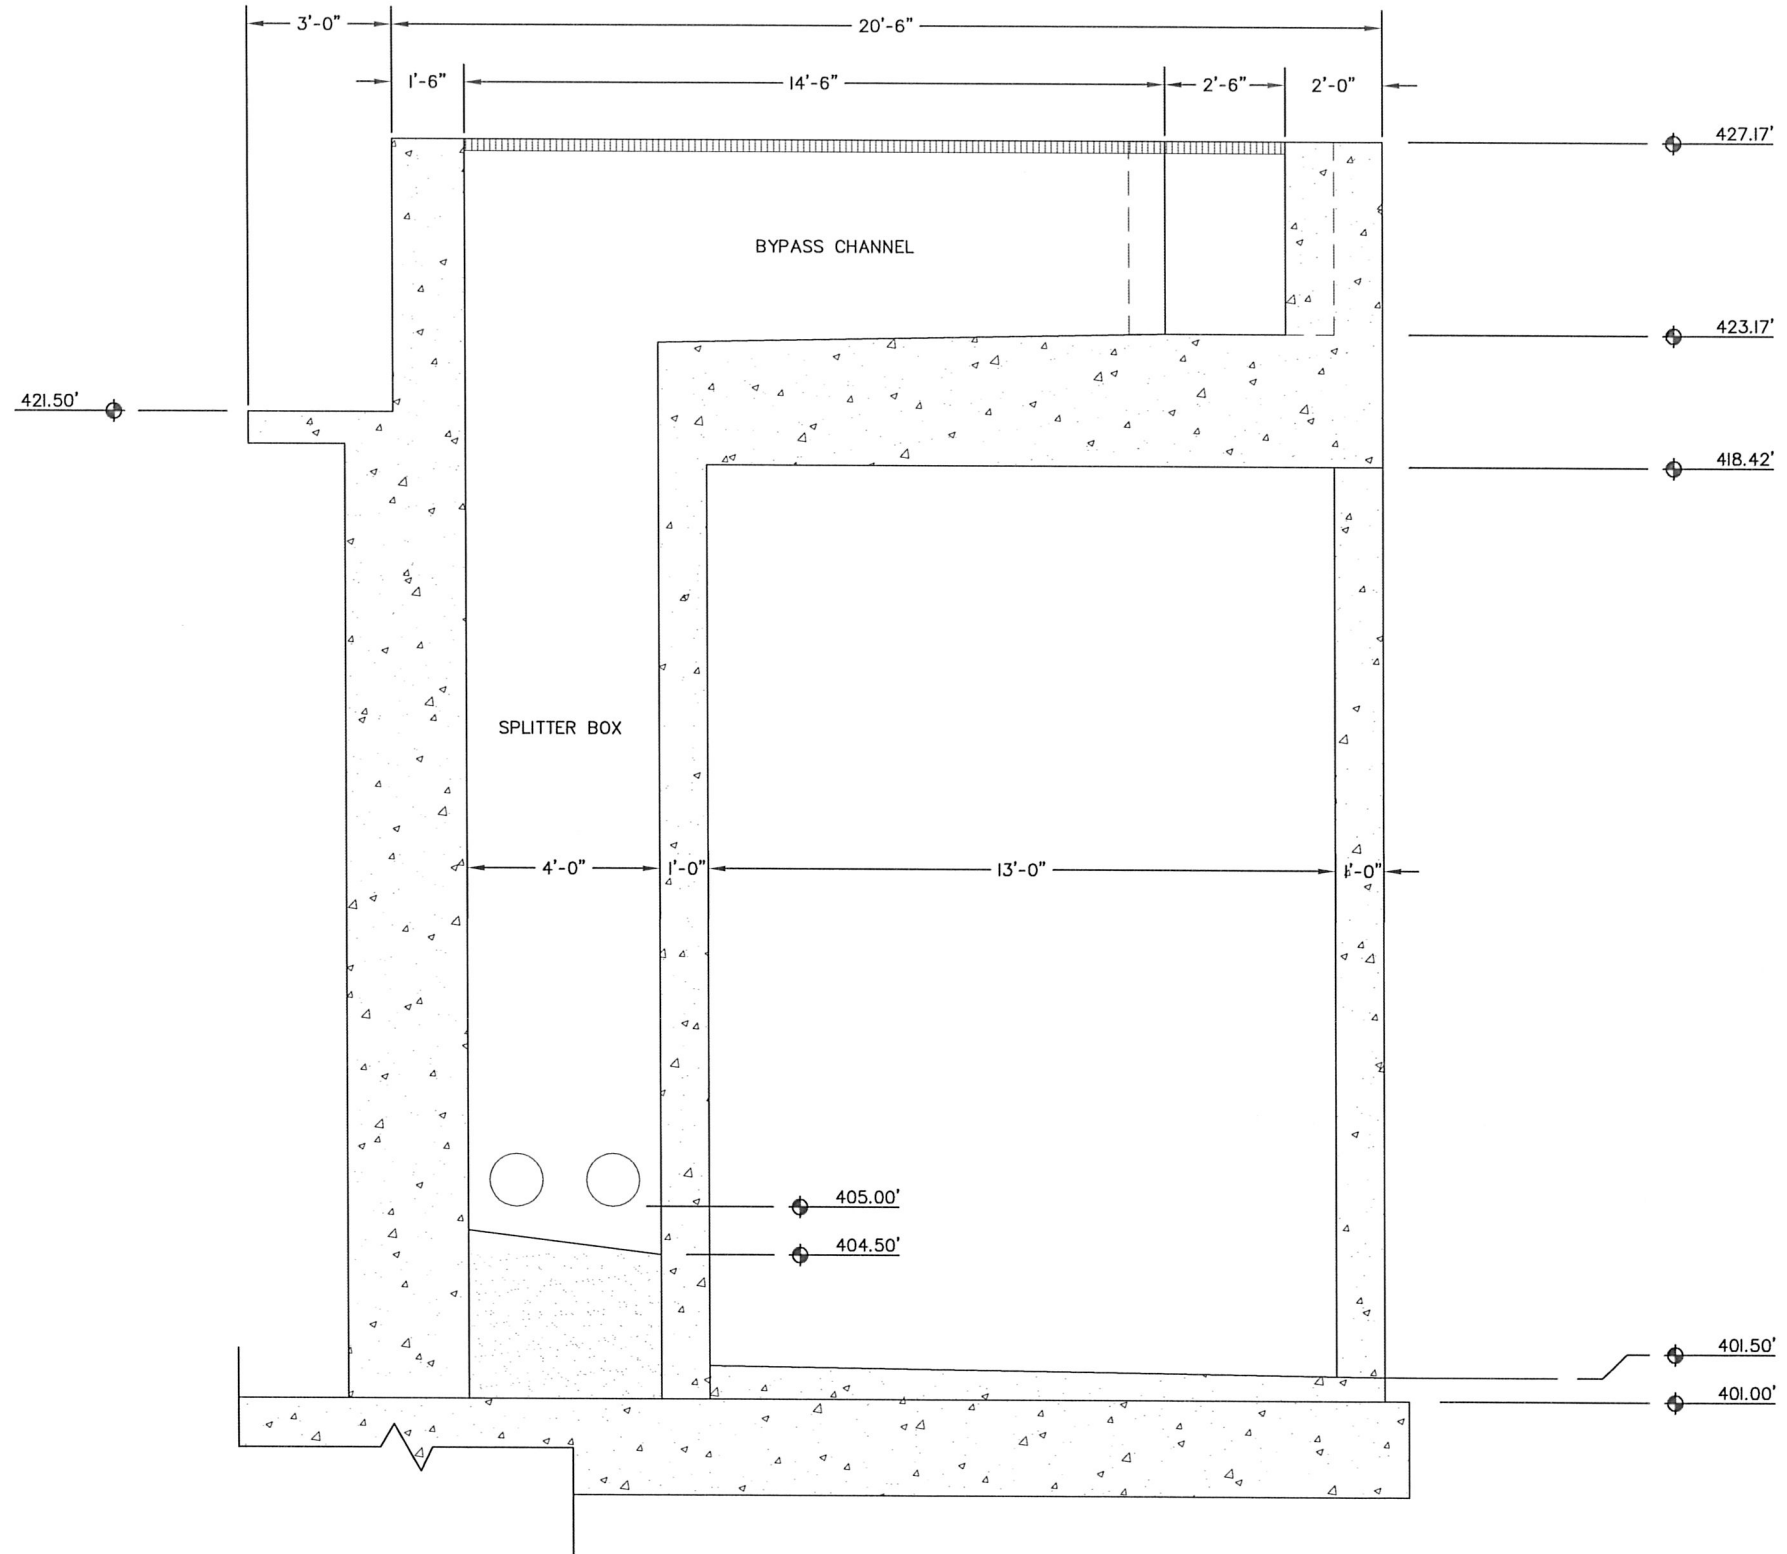

TYPICAL SECTION- HEADWORKS
SCALE: 1" = 4'-0"



SUBMITTED BY:	DATE:
APPROVED BY:	DATE:

REVISIONS					
REVISED	DESCRIPTION	SUBMIT	APPR'D	DATE	


DESIGNED:	AJS
DRAWN:	DLS
CHECKED:	SBM
APPROVED:	



THE DYER PARTNERSHIP
ENGINEERS & PLANNERS, INC.
1330 TEAKWOOD AVENUE
COOS BAY, OREGON 97420
TELEPHONE: (541) 269-0732
www.dyerpart.com


LINE IS 1 INCH
AT FULL SCALE
IF NOT 1-INCH - SCALE ACCORDINGLY

WASTEWATER TREATMENT PLANT IMPROVEMENTS CITY OF SUTHERLIN		PROJECT NO.	DRAWING NO.
HEADWORKS STRUCTURAL- TYPICAL SECTION		146.38	S803
		DATE MAY 2016	SHEET NO. 47 OF 70

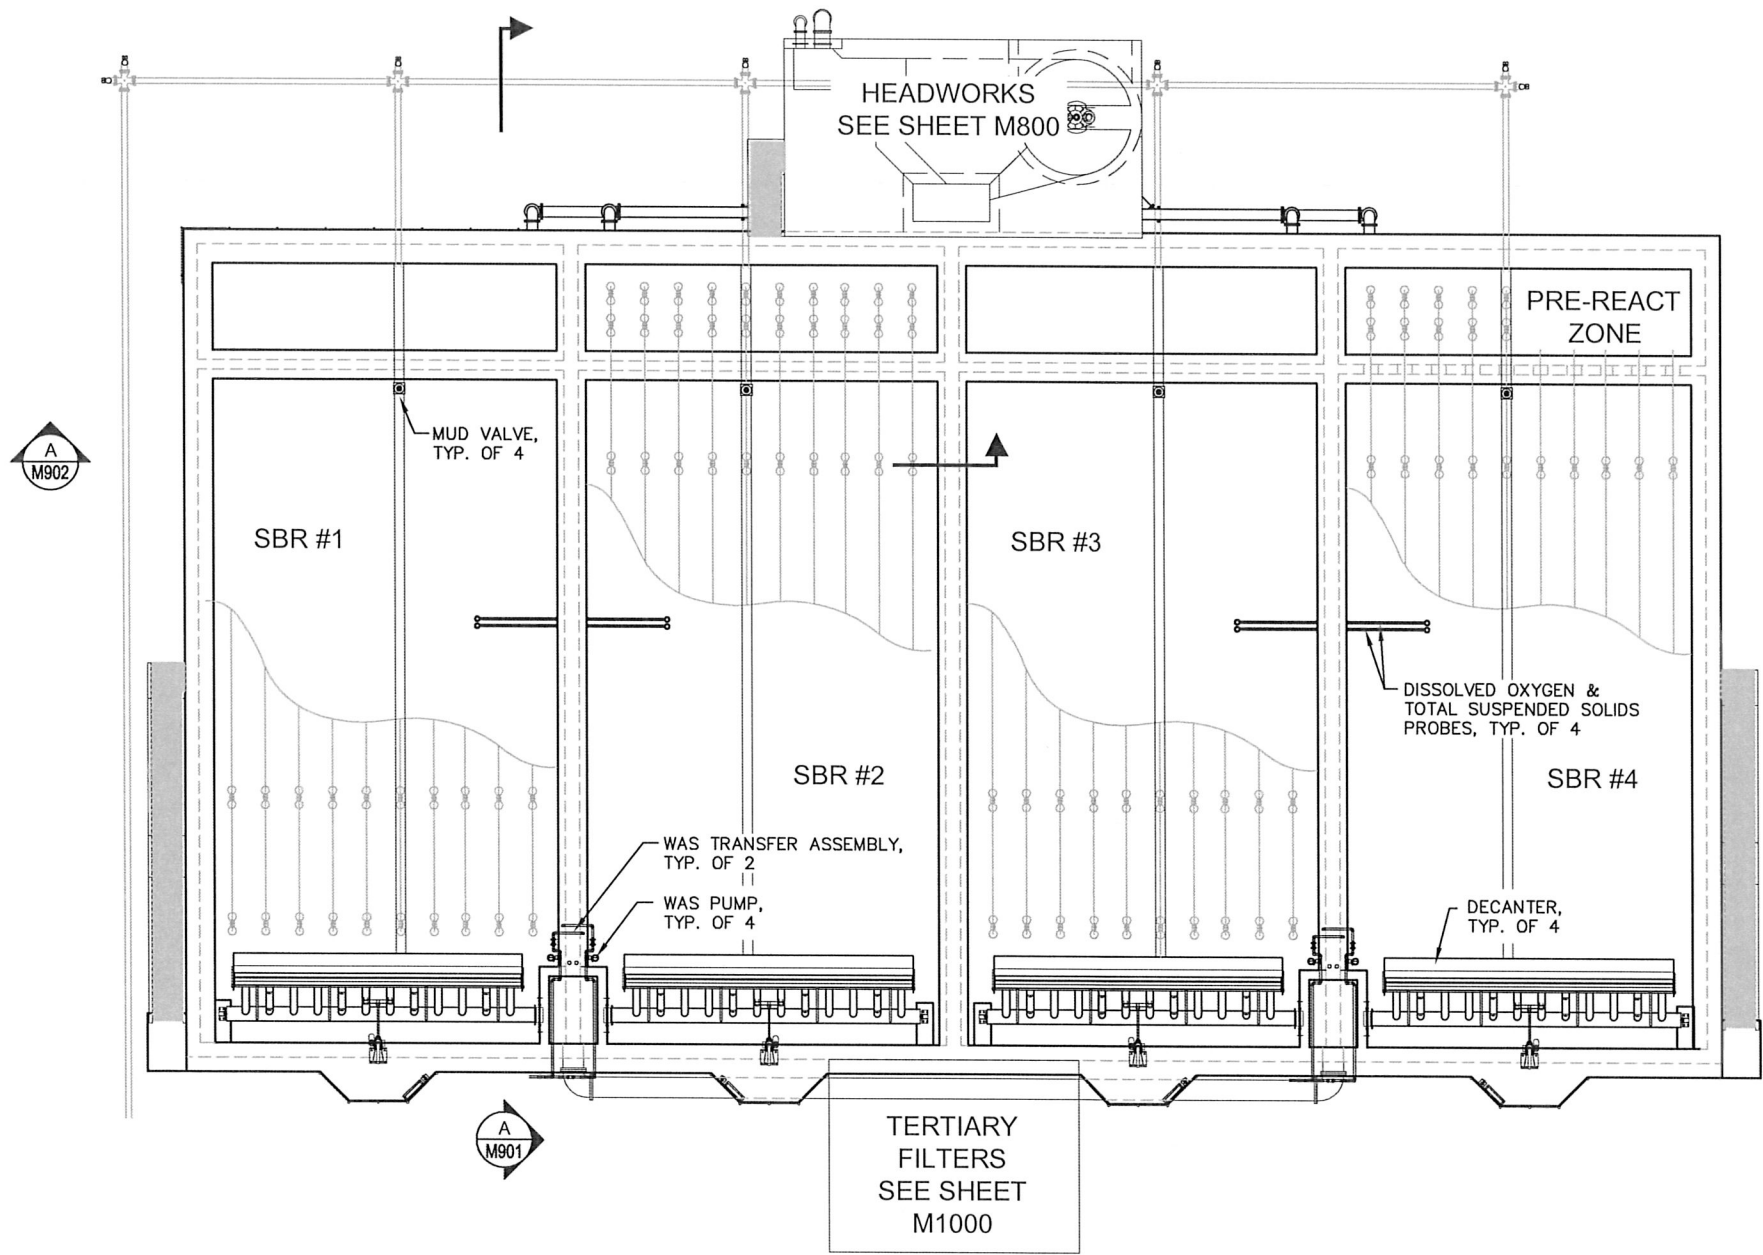

SBR - PLAN VIEW
SCALE: 1" = 20'-0"

 1
M900



SUBMITTED BY: _____ DATE: _____
APPROVED BY: _____ DATE: _____

REVISIONS				
REVISED	DESCRIPTION	SUBMIT	APPR'D	DATE

DESIGNED: AJS
DRAWN: DLS
CHECKED: AJS
APPROVED: SBM




THE DYER PARTNERSHIP
ENGINEERS & PLANNERS, INC.
1330 TEAKWOOD AVENUE
COOS BAY, OREGON 97420
TELEPHONE: (541) 269-0732
www.dyerpart.com

LINE IS 1 INCH
AT FULL SCALE
IF NOT 1-INCH - SCALE ACCORDINGLY

WASTEWATER TREATMENT PLANT IMPROVEMENTS
CITY OF SUTHERLIN
SBR
MECHANICAL-PLAN VIEW

PROJECT NO.	DRAWING NO.
146.38	M900
DATE	SHEET NO.
MAY 2016	48 OF 70

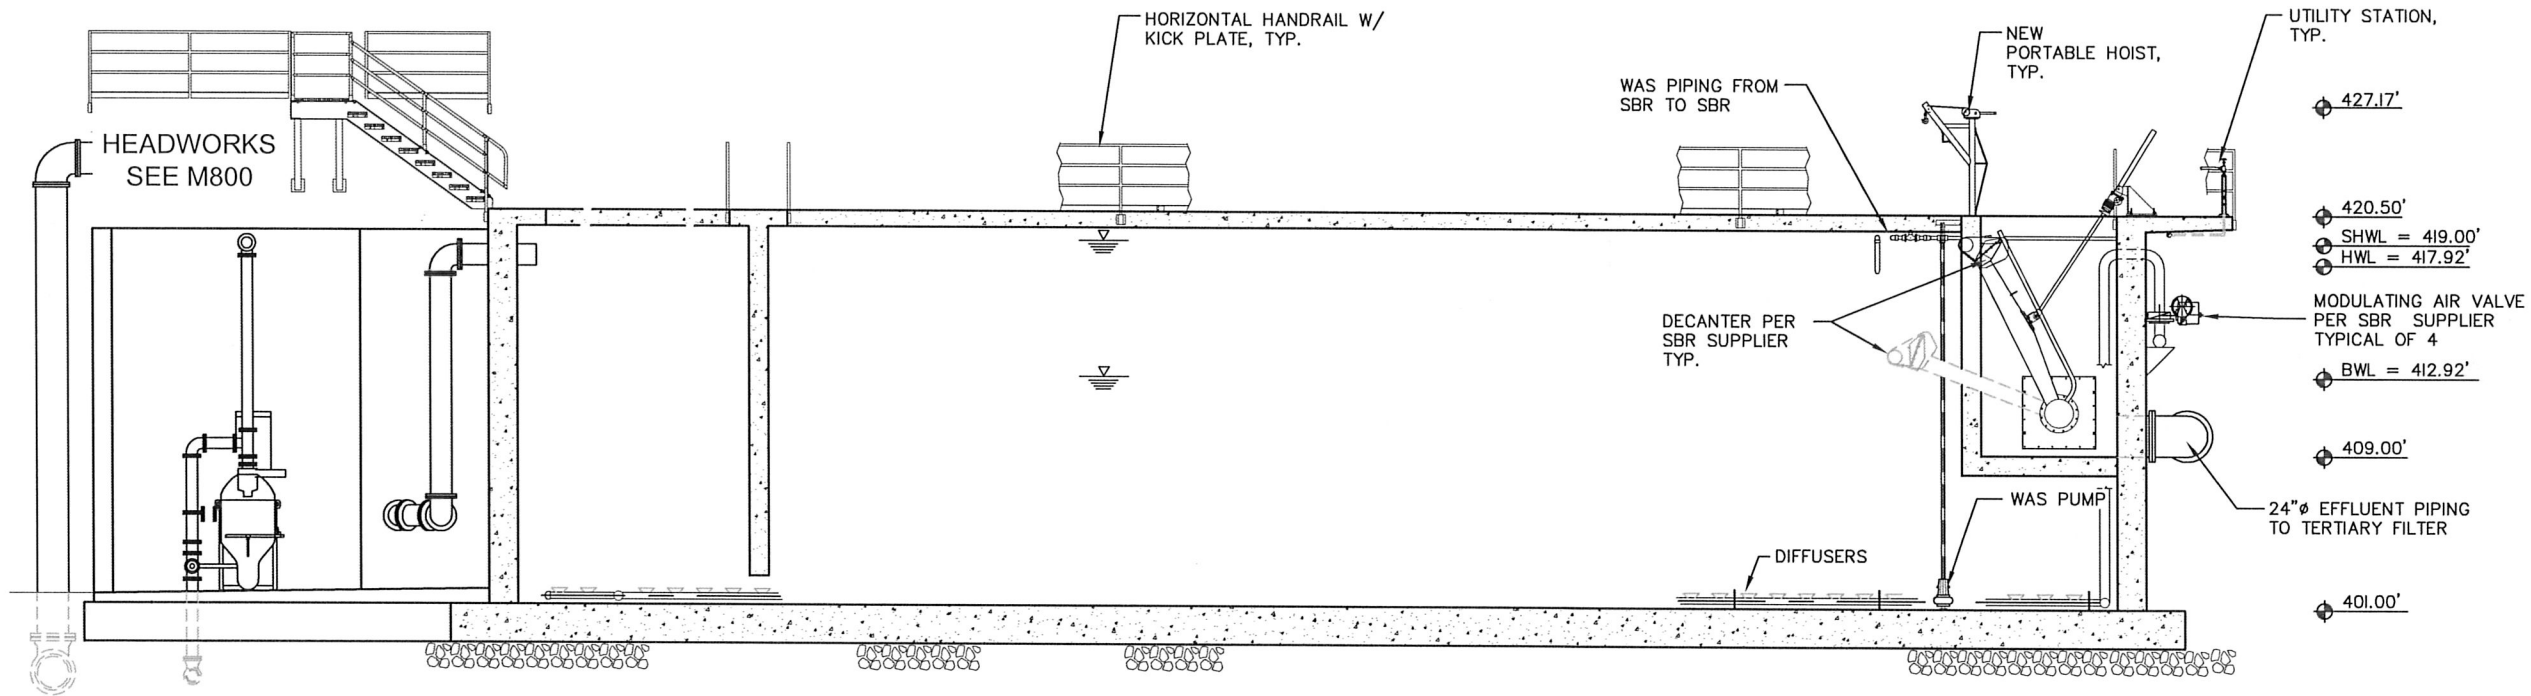

SBR-TYPICAL SECTION
SCALE: 1" = 10'-0"



SUBMITTED BY: _____ DATE: _____
APPROVED BY: _____ DATE: _____

REVISIONS				
REVISED	DESCRIPTION	SUBMIT	APPR'D	DATE

DESIGNED: AJS
DRAWN: DLS
CHECKED: AJS
APPROVED: SBM




THE DYER PARTNERSHIP
ENGINEERS & PLANNERS, INC.
1330 TEAKWOOD AVENUE
COOS BAY, OREGON 97420
TELEPHONE: (541) 269-0732
www.dyerpart.com

LINE IS 1 INCH
AT FULL SCALE
IF NOT 1-INCH - SCALE ACCORDINGLY

WASTEWATER TREATMENT PLANT IMPROVEMENTS
CITY OF SUTHERLIN
SBR
MECHANICAL- SECTION

PROJECT NO. 146.38	DRAWING NO. M901
DATE MAY 2016	SHEET NO. 49 OF 70

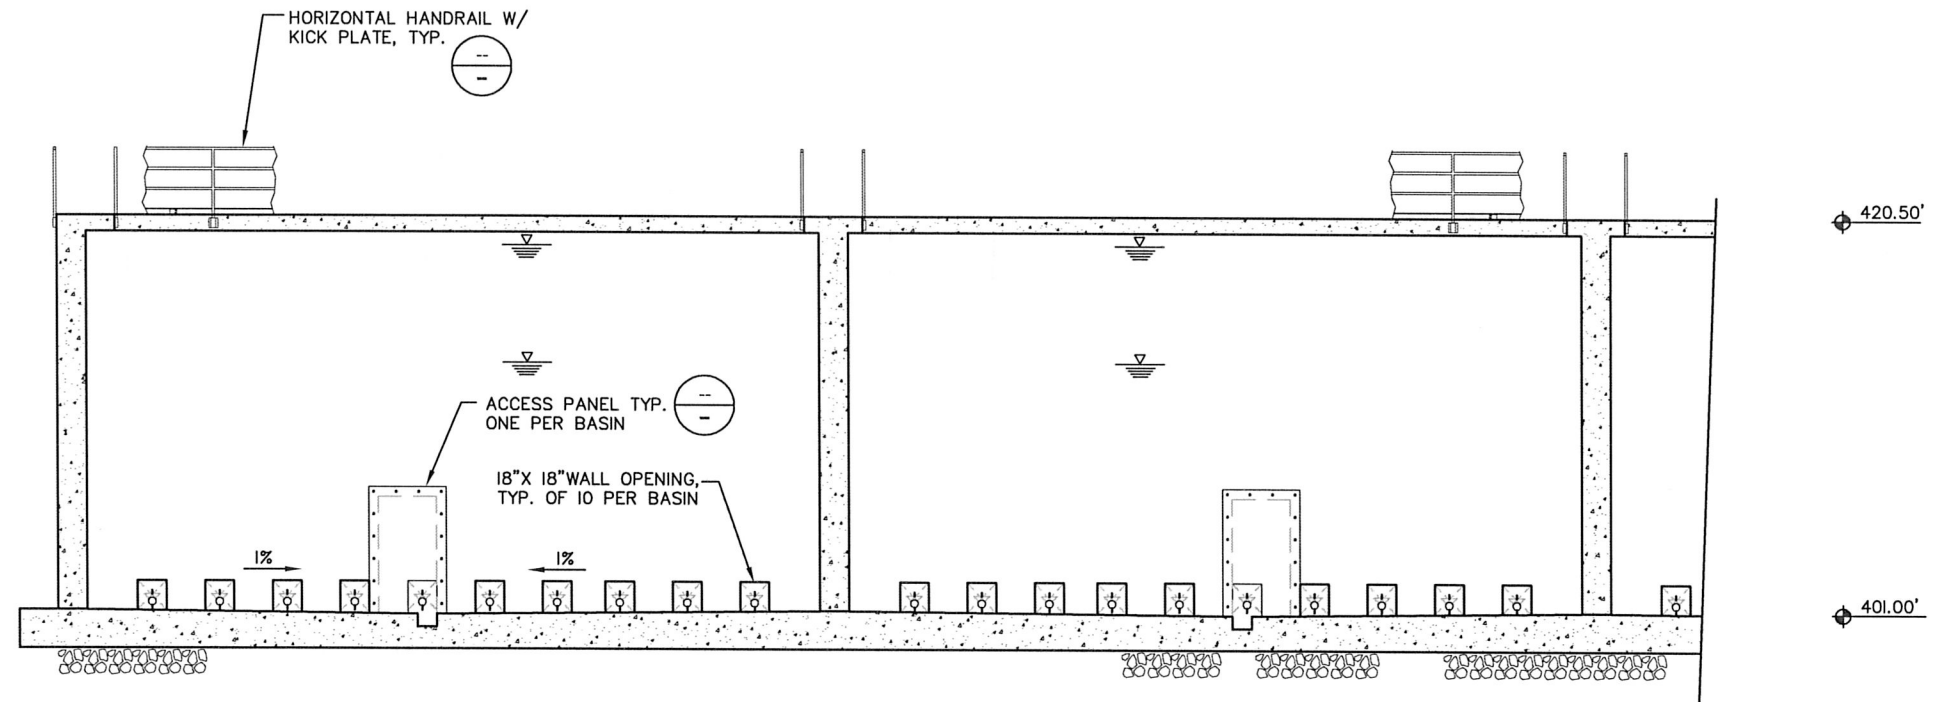

SBR-TYPICAL SECTION
SCALE: 1" = 10'-0"



SUBMITTED BY:	DATE:	REVISIONS					DESIGNED:
		REVISED	DESCRIPTION	SUBMIT	APPR'D	DATE	AJS
APPROVED BY:	DATE:						DRAWN:
							DLS
							CHECKED:
							AJS
							APPROVED:
							SBM




THE DYER PARTNERSHIP
ENGINEERS & PLANNERS, INC.
1330 TEAKWOOD AVENUE
COOS BAY, OREGON 97420
TELEPHONE: (541) 269-0732
www.dyerpart.com

LINE IS 1 INCH
AT FULL SCALE
IF NOT 1-INCH - SCALE ACCORDINGLY


WASTEWATER TREATMENT PLANT IMPROVEMENTS CITY OF SUTHERLIN		PROJECT NO. 146.38	DRAWING NO. M902
SBR MECHANICAL- SECTION		DATE MAY 2016	SHEET NO. 50 OF 70

\\dyer\dyer-part\A\Projects\46 Sutherlin\46.38 WWTF Pre-Design Report\dwg\PRE-DESIGN\PROCESS AREA 900 SBR\M900.dwg, 5/4/2016 3:37:55 PM PLOT DATE May 5, 2016

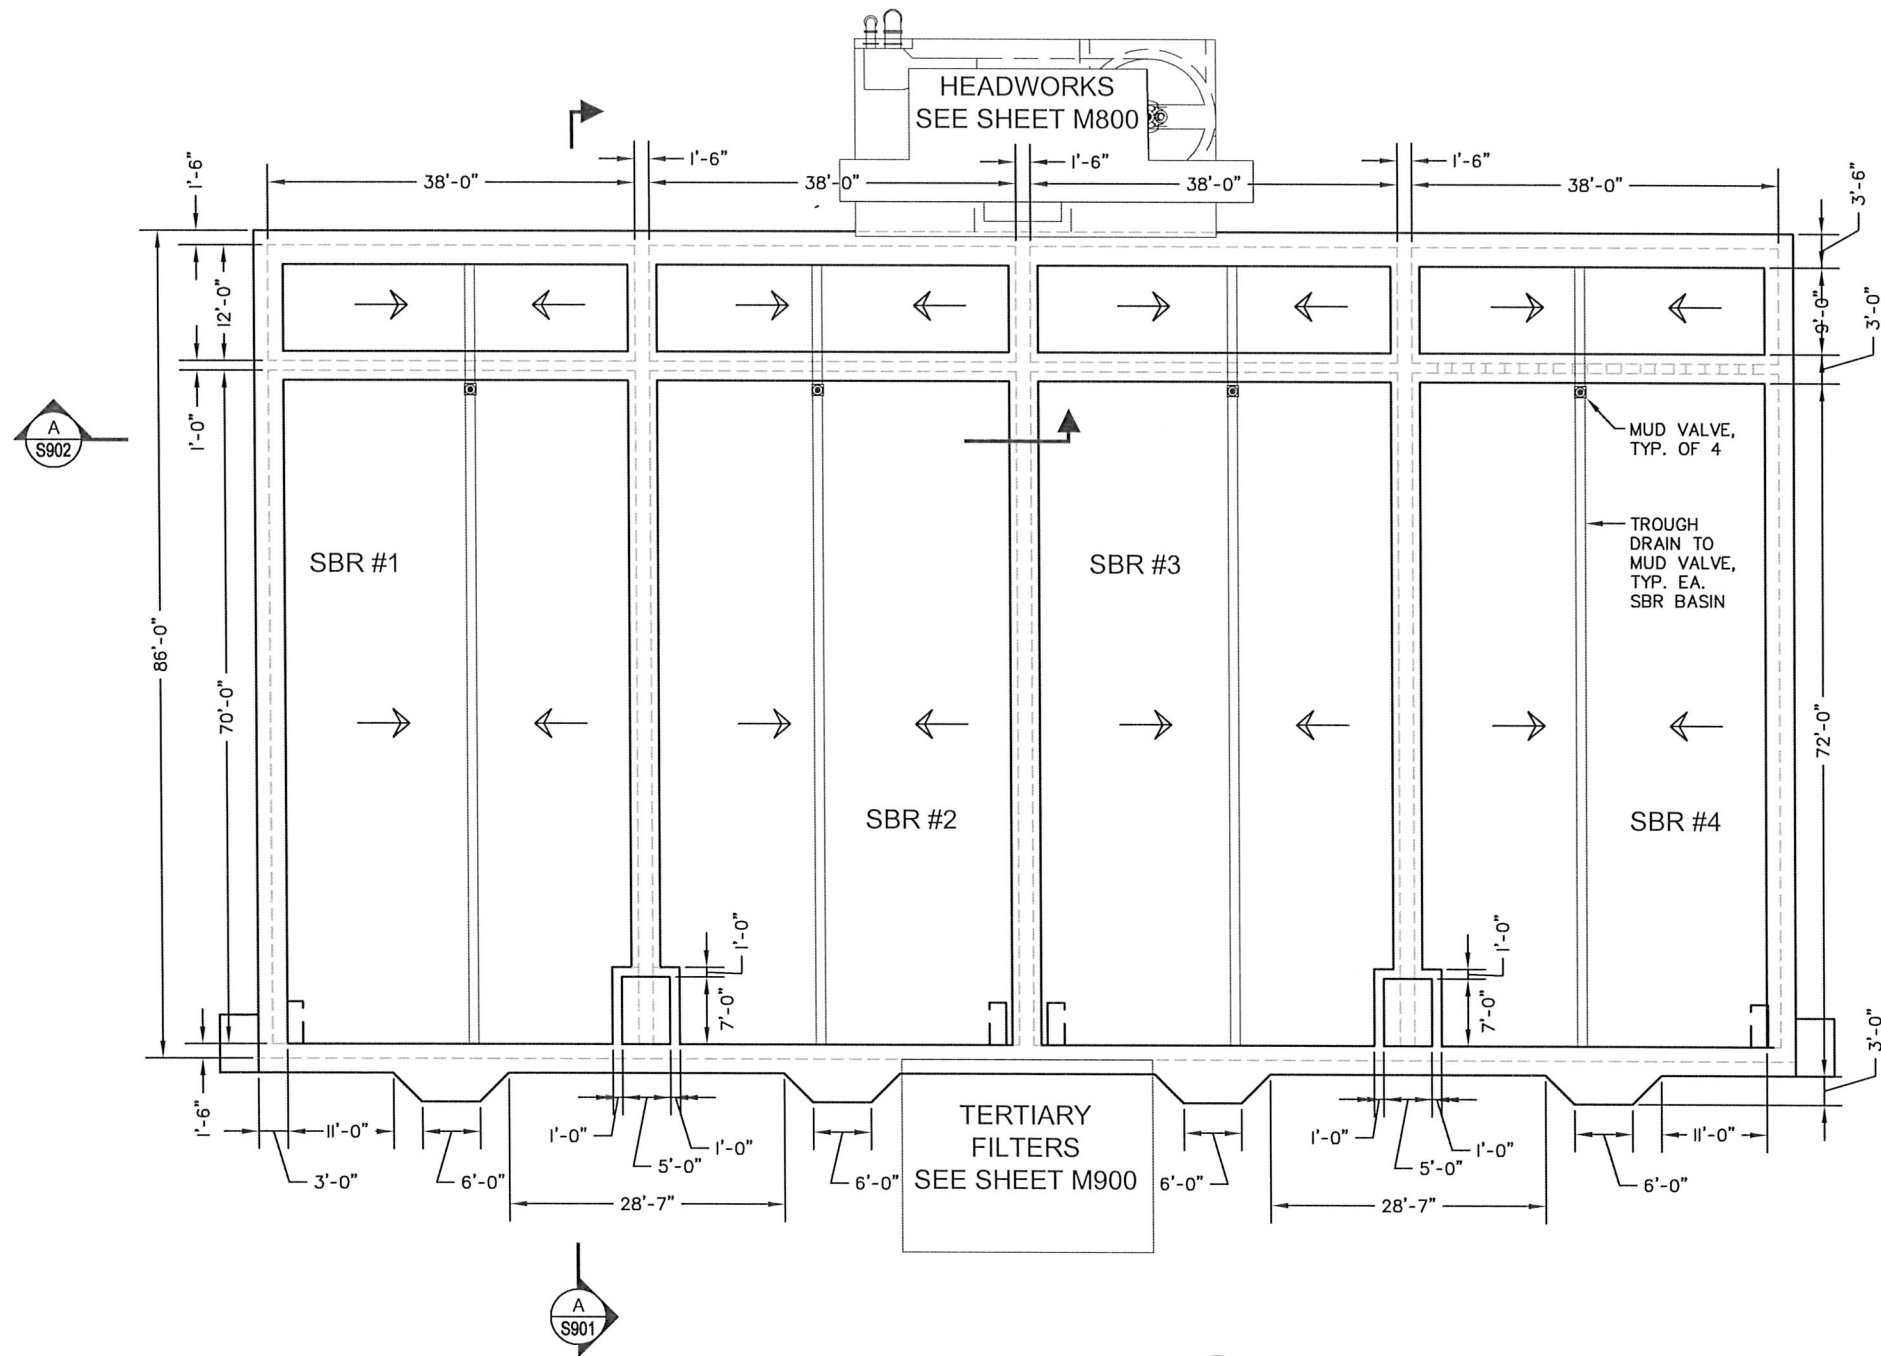

SBR- FOUNDATION PLAN
SCALE: 1" = 20'-0"

 1
S900



DESIGNED:
AJS

DRAWN:
DLS

APPROVED BY:
DATE:

REVISIONS				
REVISED	DESCRIPTION	SUBMIT.	APPR'D.	DATE



THE DYER PARTNERSHIP
ENGINEERS & PLANNERS, INC.
1330 TEAKWOOD AVENUE
COOS BAY, OREGON 97420
TELEPHONE: (541) 269-0732
www.dyerpart.com


LINE IS 1 INCH
AT FULL SCALE
IF NOT 1-INCH - SCALE ACCORDINGLY

WASTEWATER TREATMENT PLANT IMPROVEMENTS
CITY OF SUTHERLIN

SBR
STRUCTURAL- PLAN VIEW

PROJECT NO. 146.38	DRAWING NO. S900
DATE MAY 2016	SHEET NO. 51 OF 70

\\dye\dyer-part\A\projects\146 Sutherlin\146.38 WWTF Pre-Design Report\dwg\PRE-DESIGN\PROCESS AREA 900 SBR\1M900.dwg, 5/4/2016 3:37:55 PM PLOT DATE May 5, 2016

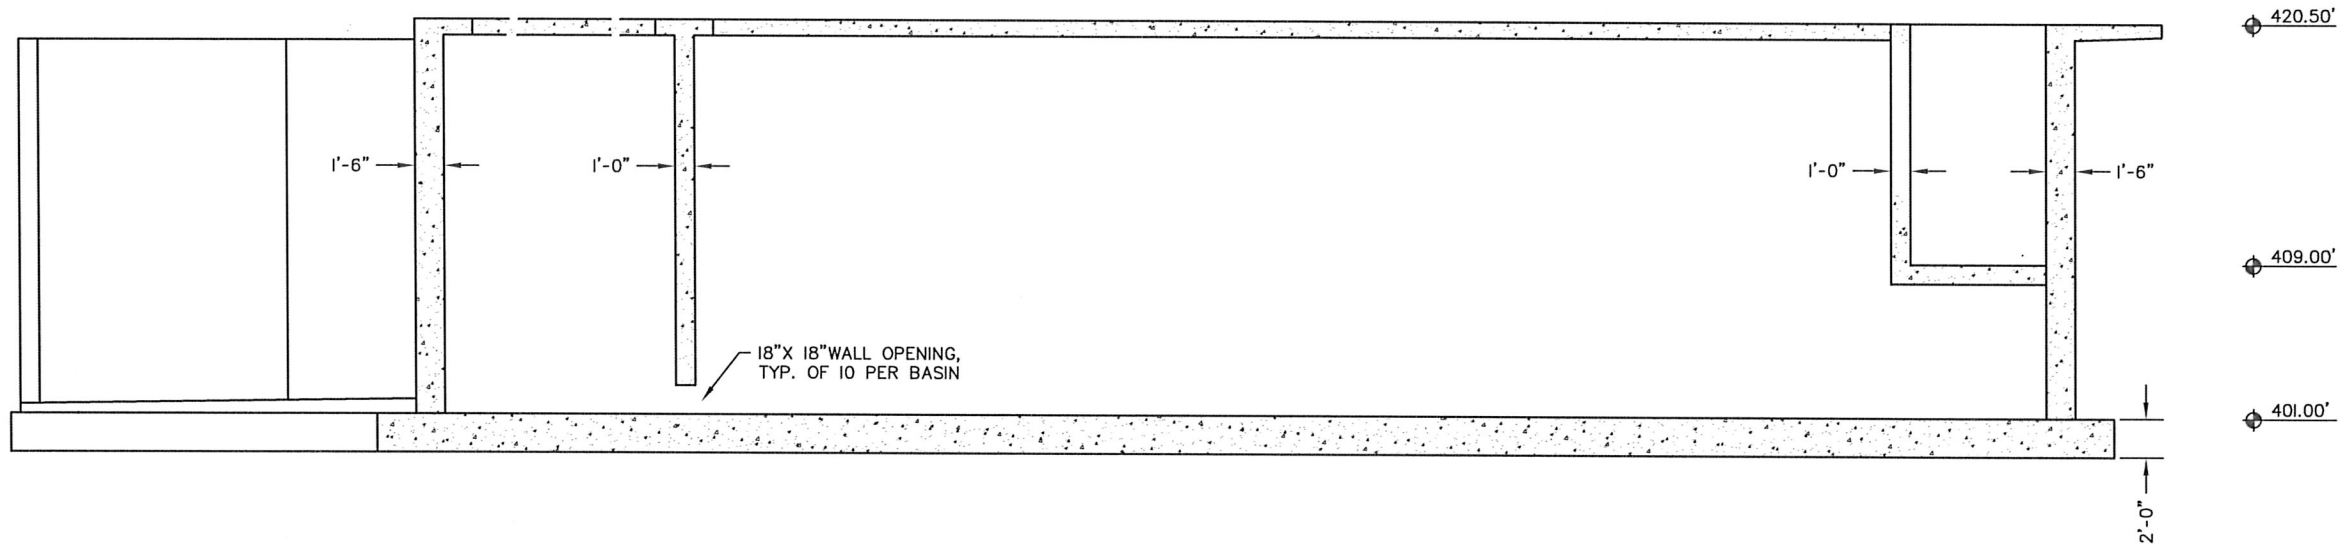

SBR- TYPICAL SECTION
SCALE: 1" = 10'-0"
A
S901



DESIGNED: AJS	DRAWN: DLS	REVISIONS			
APPROVED BY: DATE:		REVISED	DESCRIPTION	SUBMIT.	APPR'D.
					DATE




THE DYER PARTNERSHIP
ENGINEERS & PLANNERS, INC.
1330 TEAKWOOD AVENUE
COOS BAY, OREGON 97420
TELEPHONE: (541) 269-0732
www.dyerpart.com

LINE IS 1 INCH
AT FULL SCALE
IF NOT 1-INCH - SCALE ACCORDINGLY

WASTEWATER TREATMENT PLANT IMPROVEMENTS CITY OF SUTHERLIN SBR STRUCTURAL- SECTION	PROJECT NO. 146.38	DRAWING NO. S901
	DATE MAY 2016	SHEET NO. 52 OF 70

\\dyer\dyer-part\A\Projects\146 Sutherlin\146.38 WWT Pre-Design Report\dwg\PRE-DESIGN\PROCESS AREA 900 SBR\M900.dwg, 5/4/2016 3:37:55 PM PLOT DATE May 5, 2016

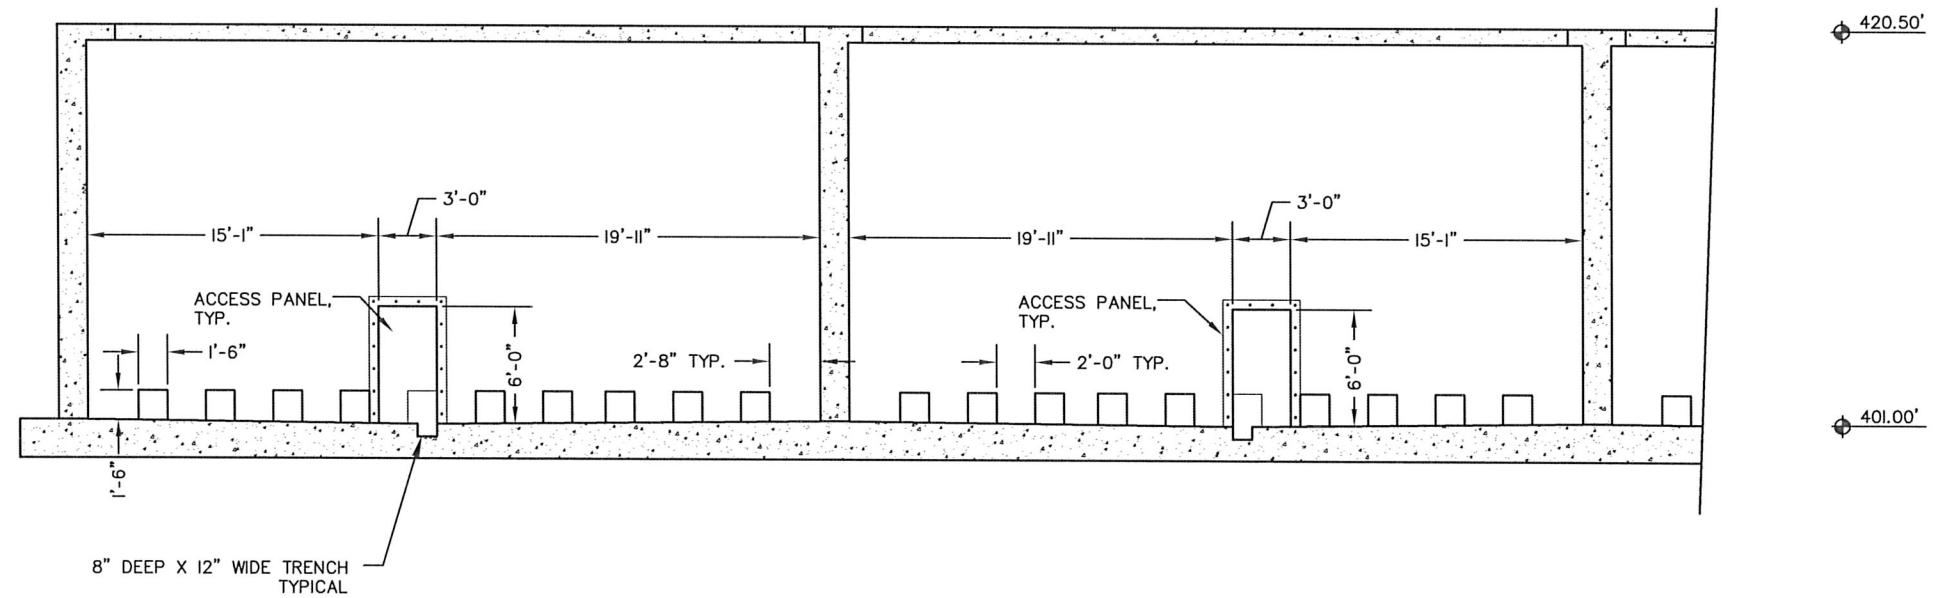

SBR-TYPICAL SECTION
SCALE: 1" = 10'-0"



DESIGNED: AJS	DRAWN: DLS	REVISIONS			
APPROVED BY:		REVISED	DESCRIPTION	SUBMIT.	APPR'D. DATE
DATE:					



THE DYER PARTNERSHIP
ENGINEERS & PLANNERS, INC.
1330 TEAKWOOD AVENUE
COOS BAY, OREGON 97420
TELEPHONE: (541) 269-0732
www.dyerpart.com


LINE IS 1 INCH
AT FULL SCALE
IF NOT 1-INCH - SCALE ACCORDINGLY

WASTEWATER TREATMENT PLANT IMPROVEMENTS
CITY OF SUTHERLIN

SBR
STRUCTURAL- SECTION

PROJECT NO. 146.38	DRAWING NO. S902
DATE MAY 2016	SHEET NO. 53 OF 70

\\dye\dyer-part\A\projects\146 Sutherlin\146.38 WWTF Pre-Design Report\dwg\PRE-DESIGN\PROCESS AREA 1000 TERTIARY FILTERS\M1000.dwg, 5/5/2016 3:09:05 PM PLOT DATE May 5, 2016

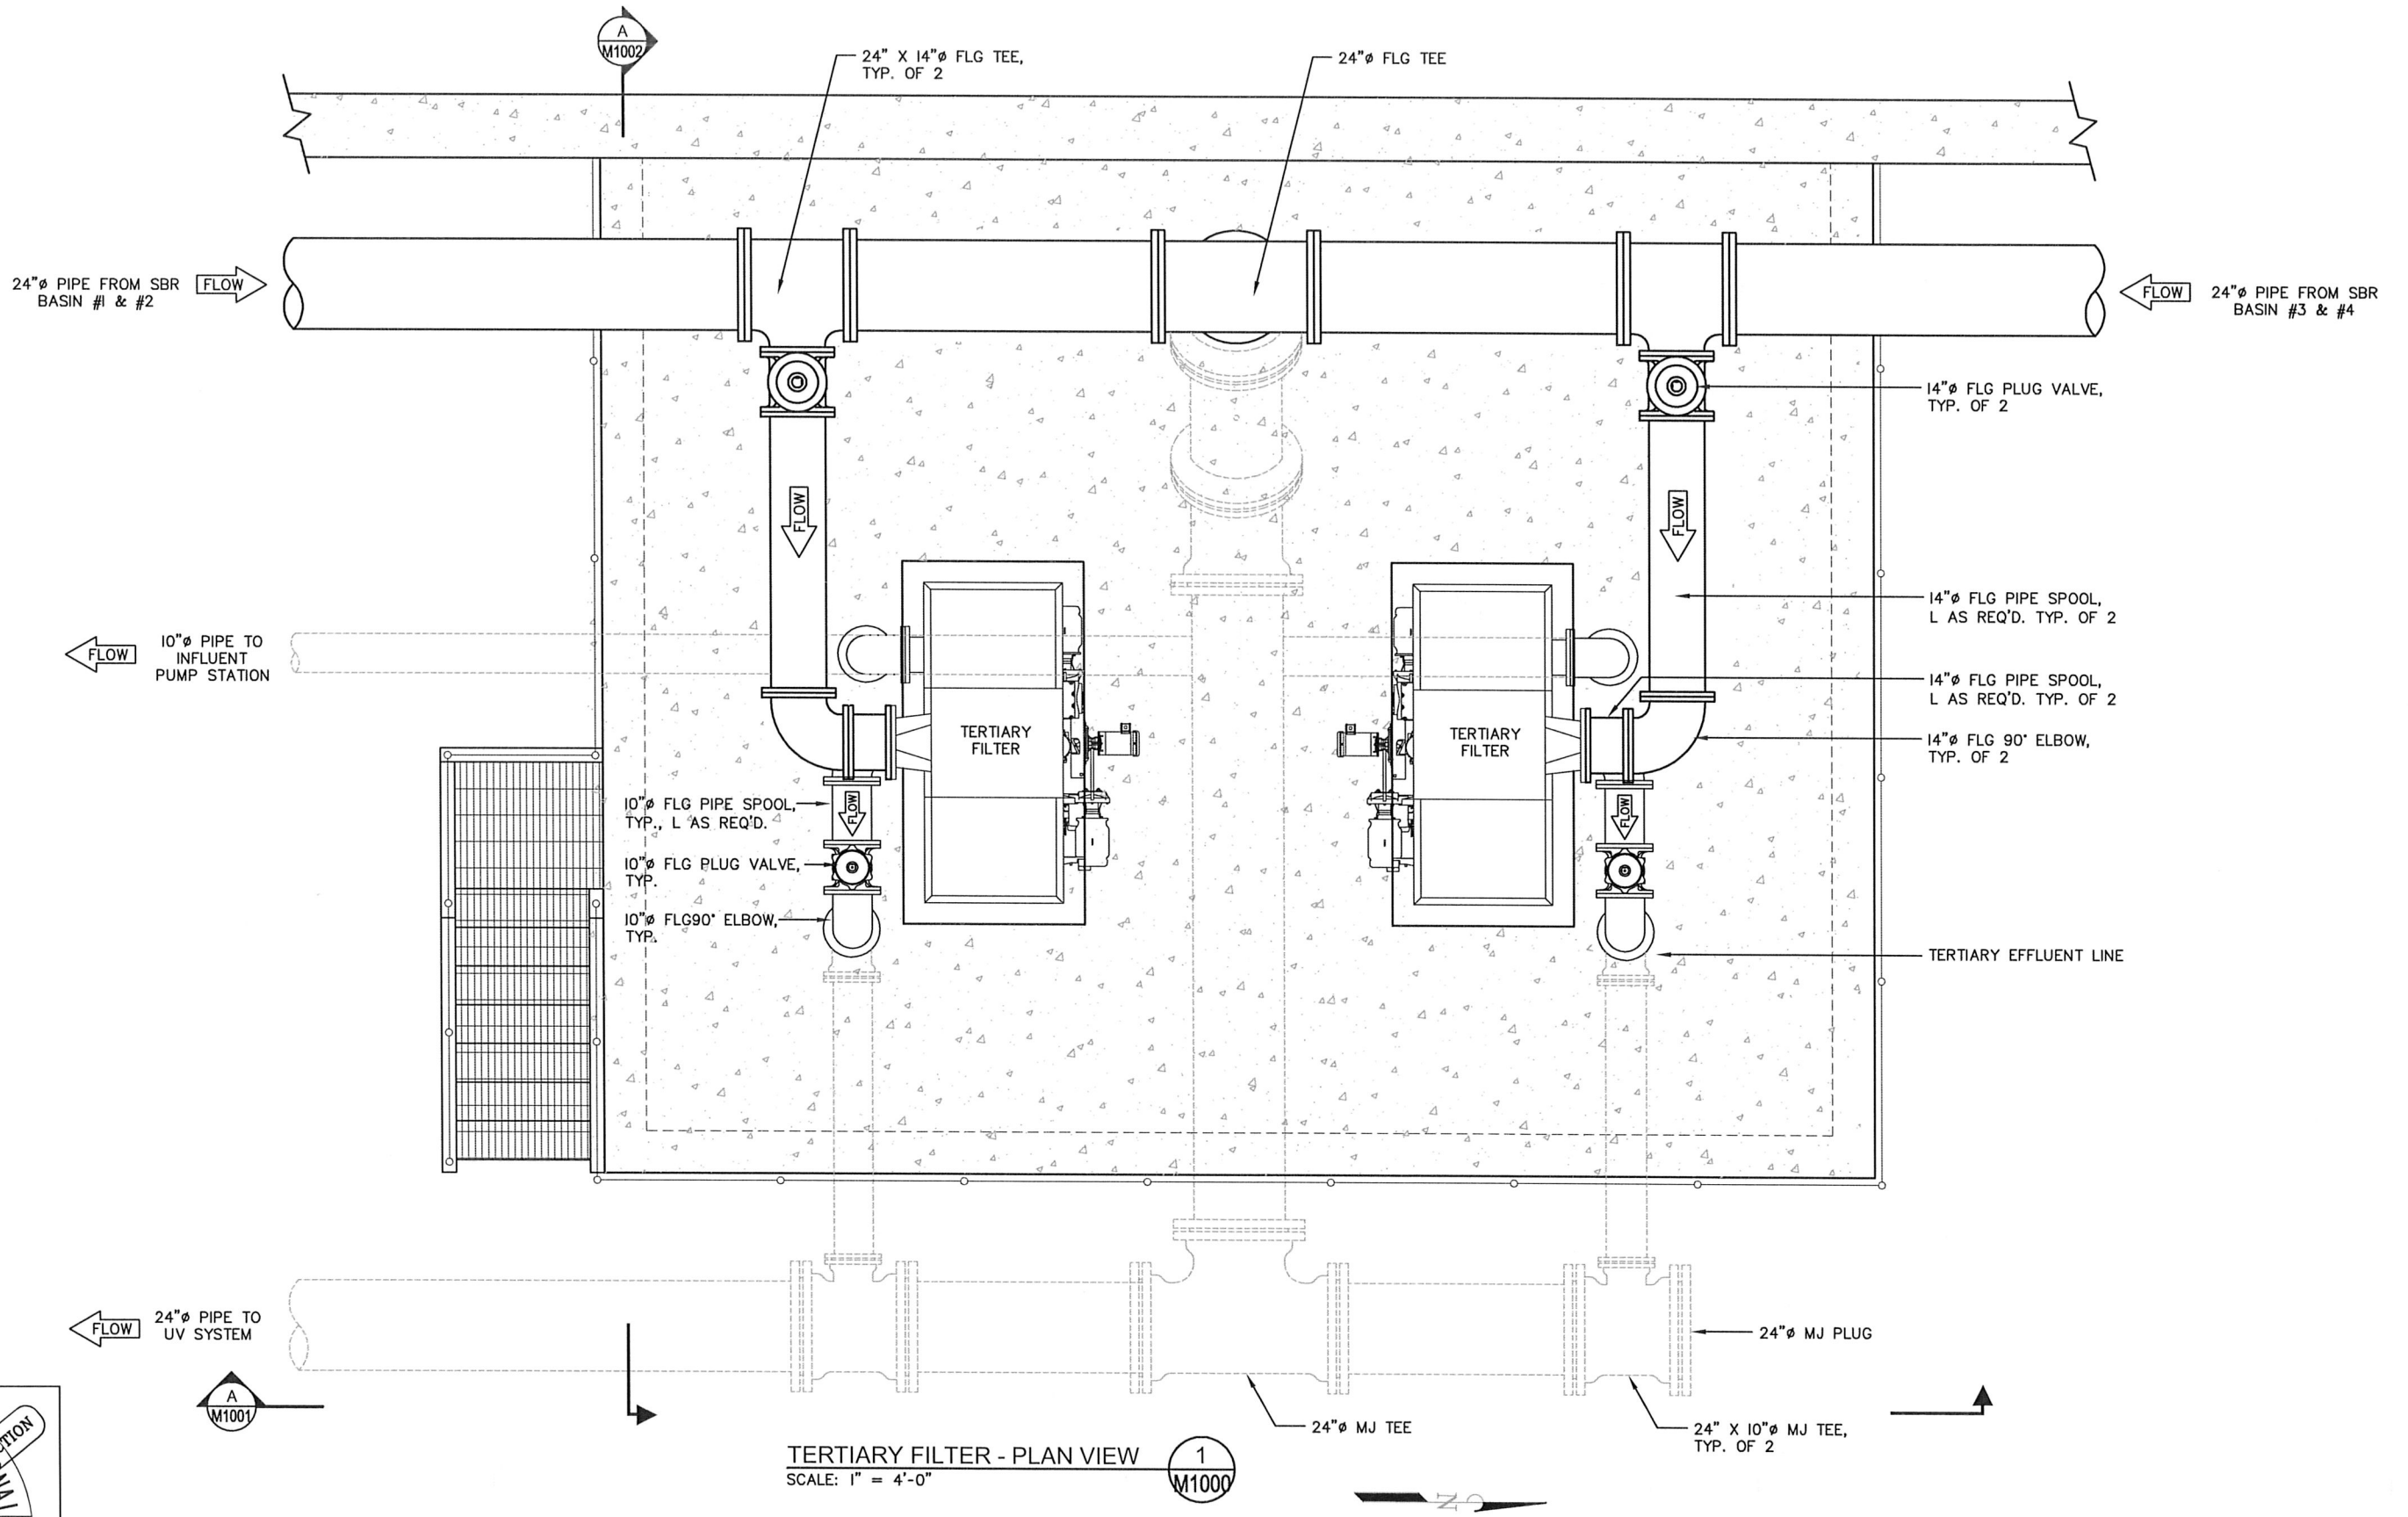

TERTIARY FILTER - PLAN VIEW
SCALE: 1" = 4'-0"

1
M1000



DESIGNED: AJS
DRAWN: DLS
APPROVED BY: _____
DATE: _____

REVISIONS				
REVISED	DESCRIPTION	SUBMIT.	APPR'D.	DATE




THE DYER PARTNERSHIP
ENGINEERS & PLANNERS, INC.
1330 TEAKWOOD AVENUE
COOS BAY, OREGON 97420
TELEPHONE: (541) 269-0732
www.dyerpart.com

LINE IS 1 INCH
AT FULL SCALE
IF NOT 1-INCH - SCALE ACCORDINGLY

**WASTEWATER TREATMENT PLANT IMPROVEMENTS
CITY OF SUTHERLIN**

**TERTIARY FILTER
MECHANICAL- PLAN VIEW**

PROJECT NO. 146.38	DRAWING NO. M1000
DATE MAY 2016	SHEET NO. 54 OF 70

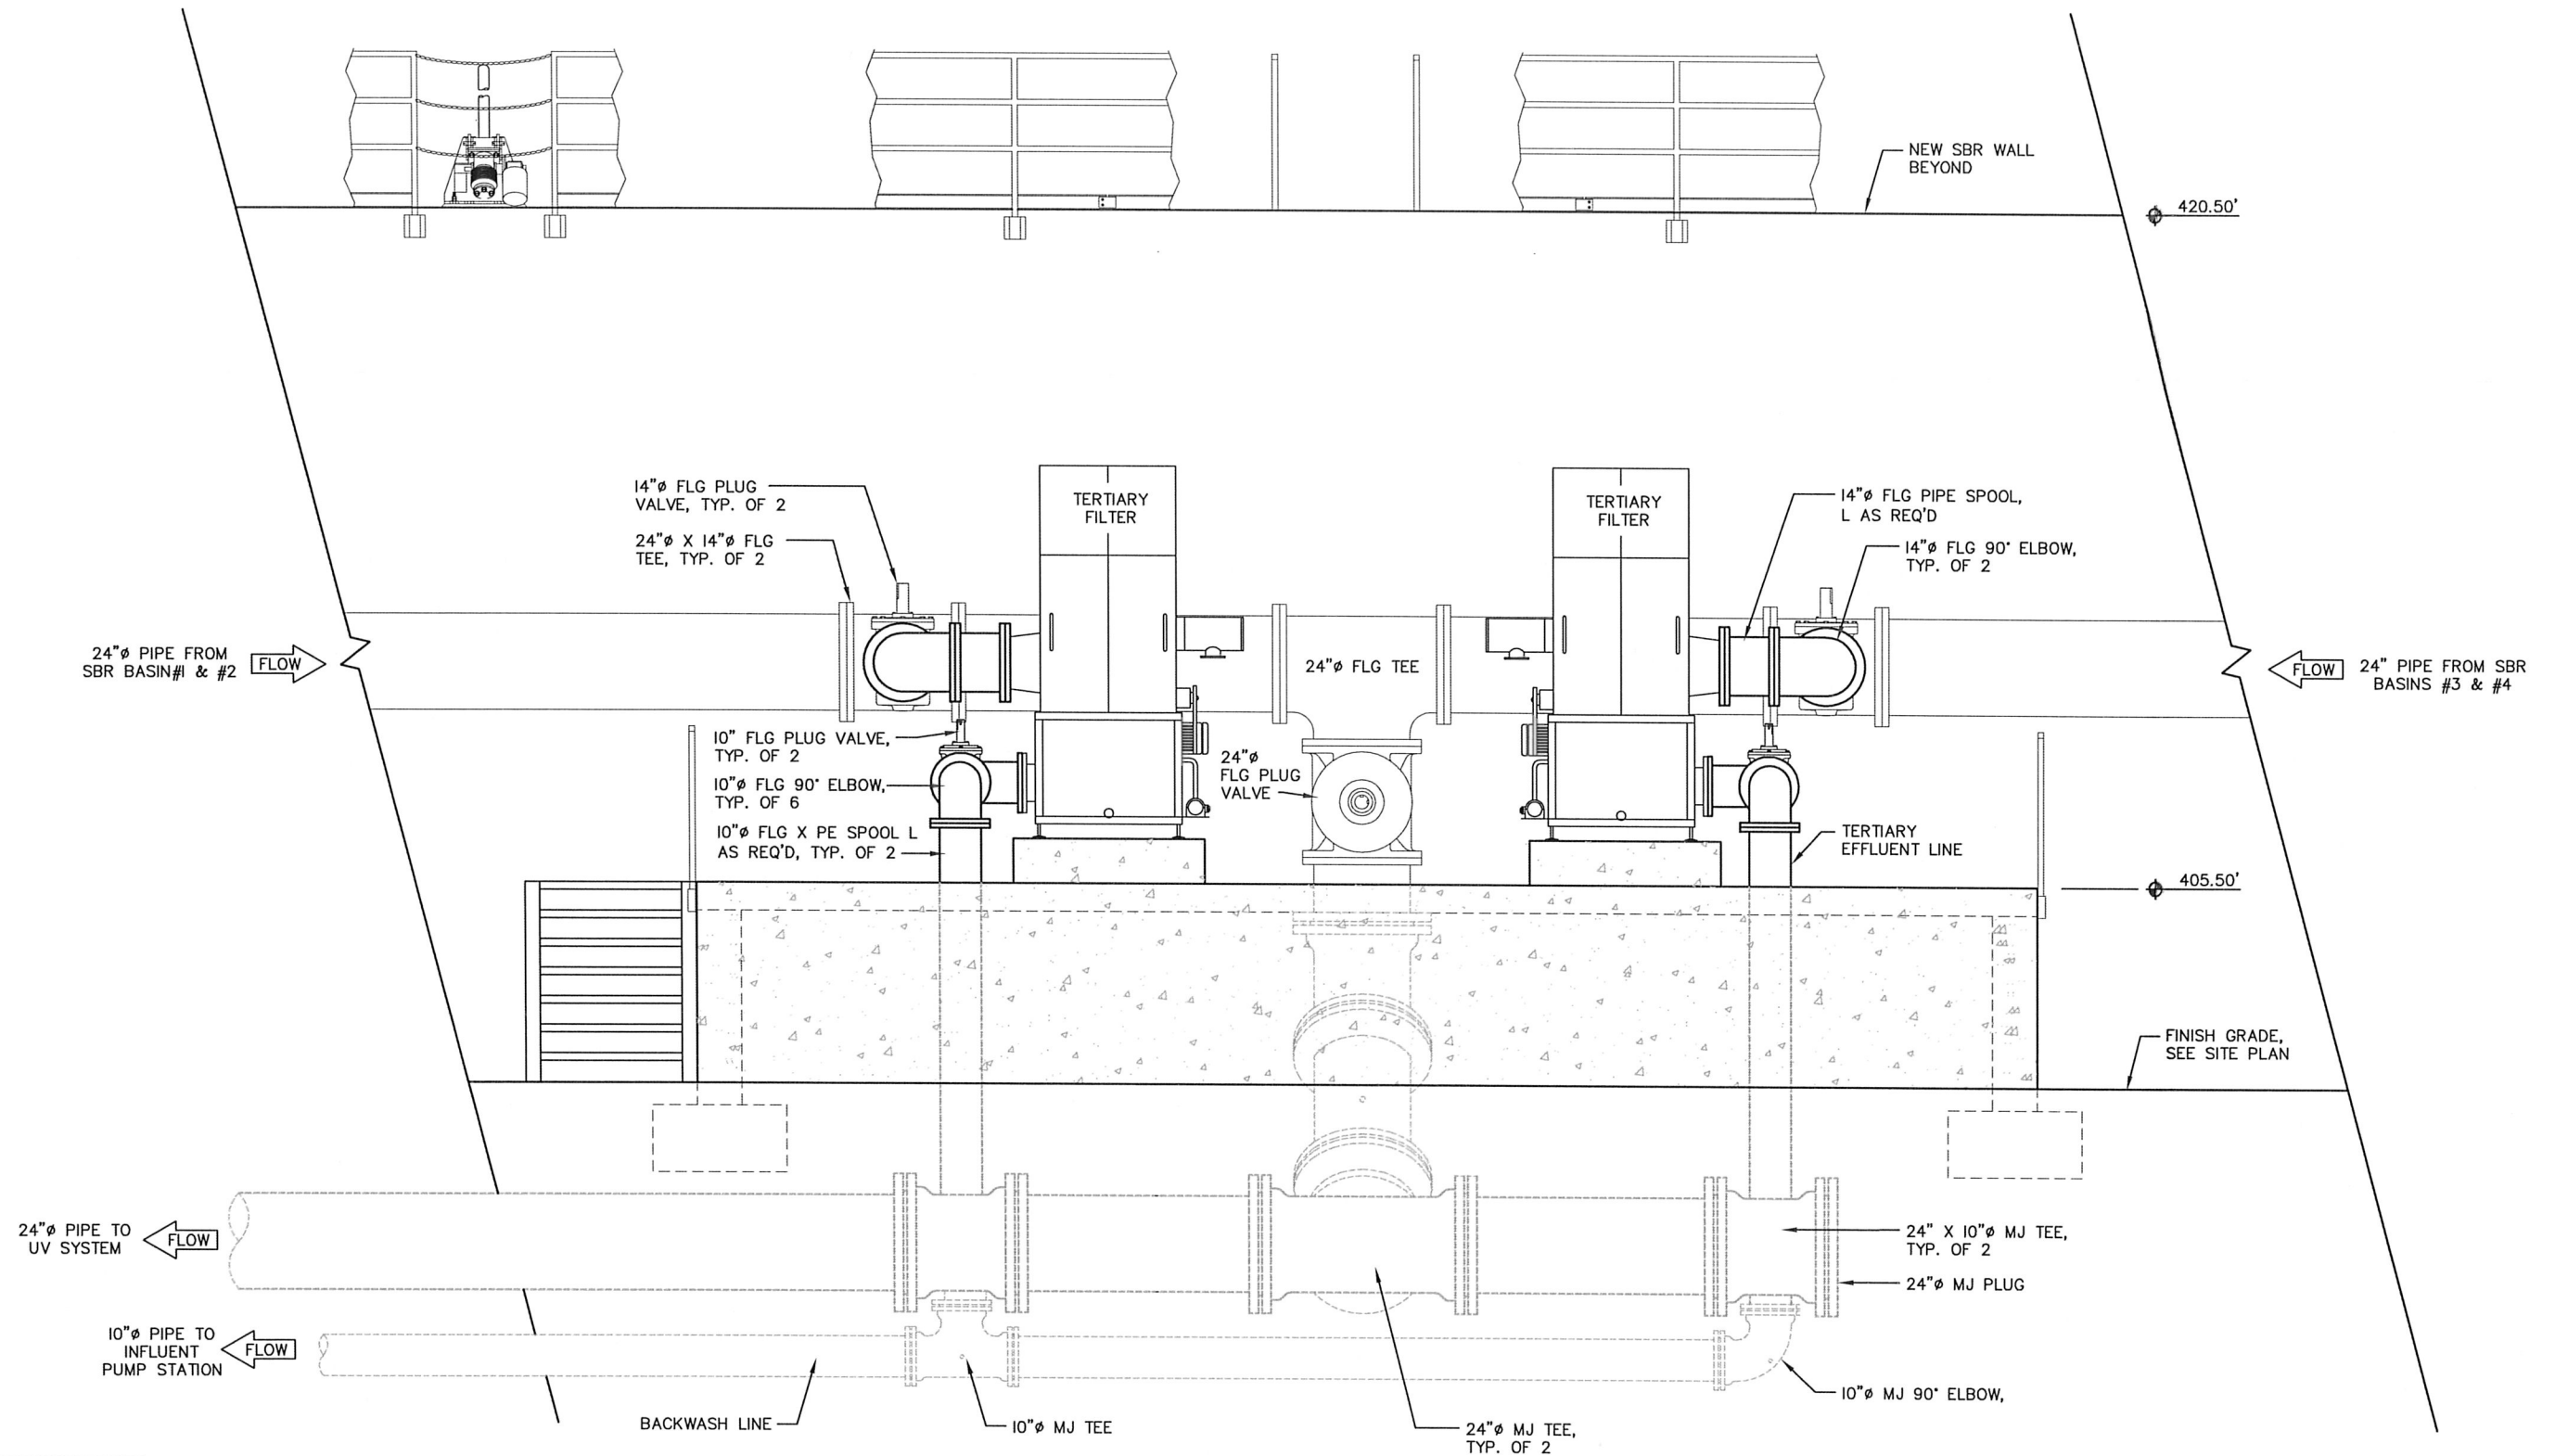

TERTIARY FILTER - SECTION
SCALE: 1" = 4'-0"



DESIGNED:
AJS

DRAWN:
DLS

APPROVED BY:
DATE:

REVISIONS				
REVISED	DESCRIPTION	SUBMIT.	APPR'D.	DATE


D THE DYER PARTNERSHIP
ENGINEERS & PLANNERS, INC.
1330 TEAKWOOD AVENUE
COOS BAY, OREGON 97420
TELEPHONE: (541) 269-0732
www.dyerpart.com

LINE IS 1 INCH
AT FULL SCALE
IF NOT 1-INCH - SCALE ACCORDINGLY

WASTEWATER TREATMENT PLANT IMPROVEMENTS
CITY OF SUTHERLIN

TERTIARY FILTER
MECHANICAL- SECTION

PROJECT NO. 146.38	DRAWING NO. M1001
DATE MAY 2016	SHEET NO. 55 OF 70

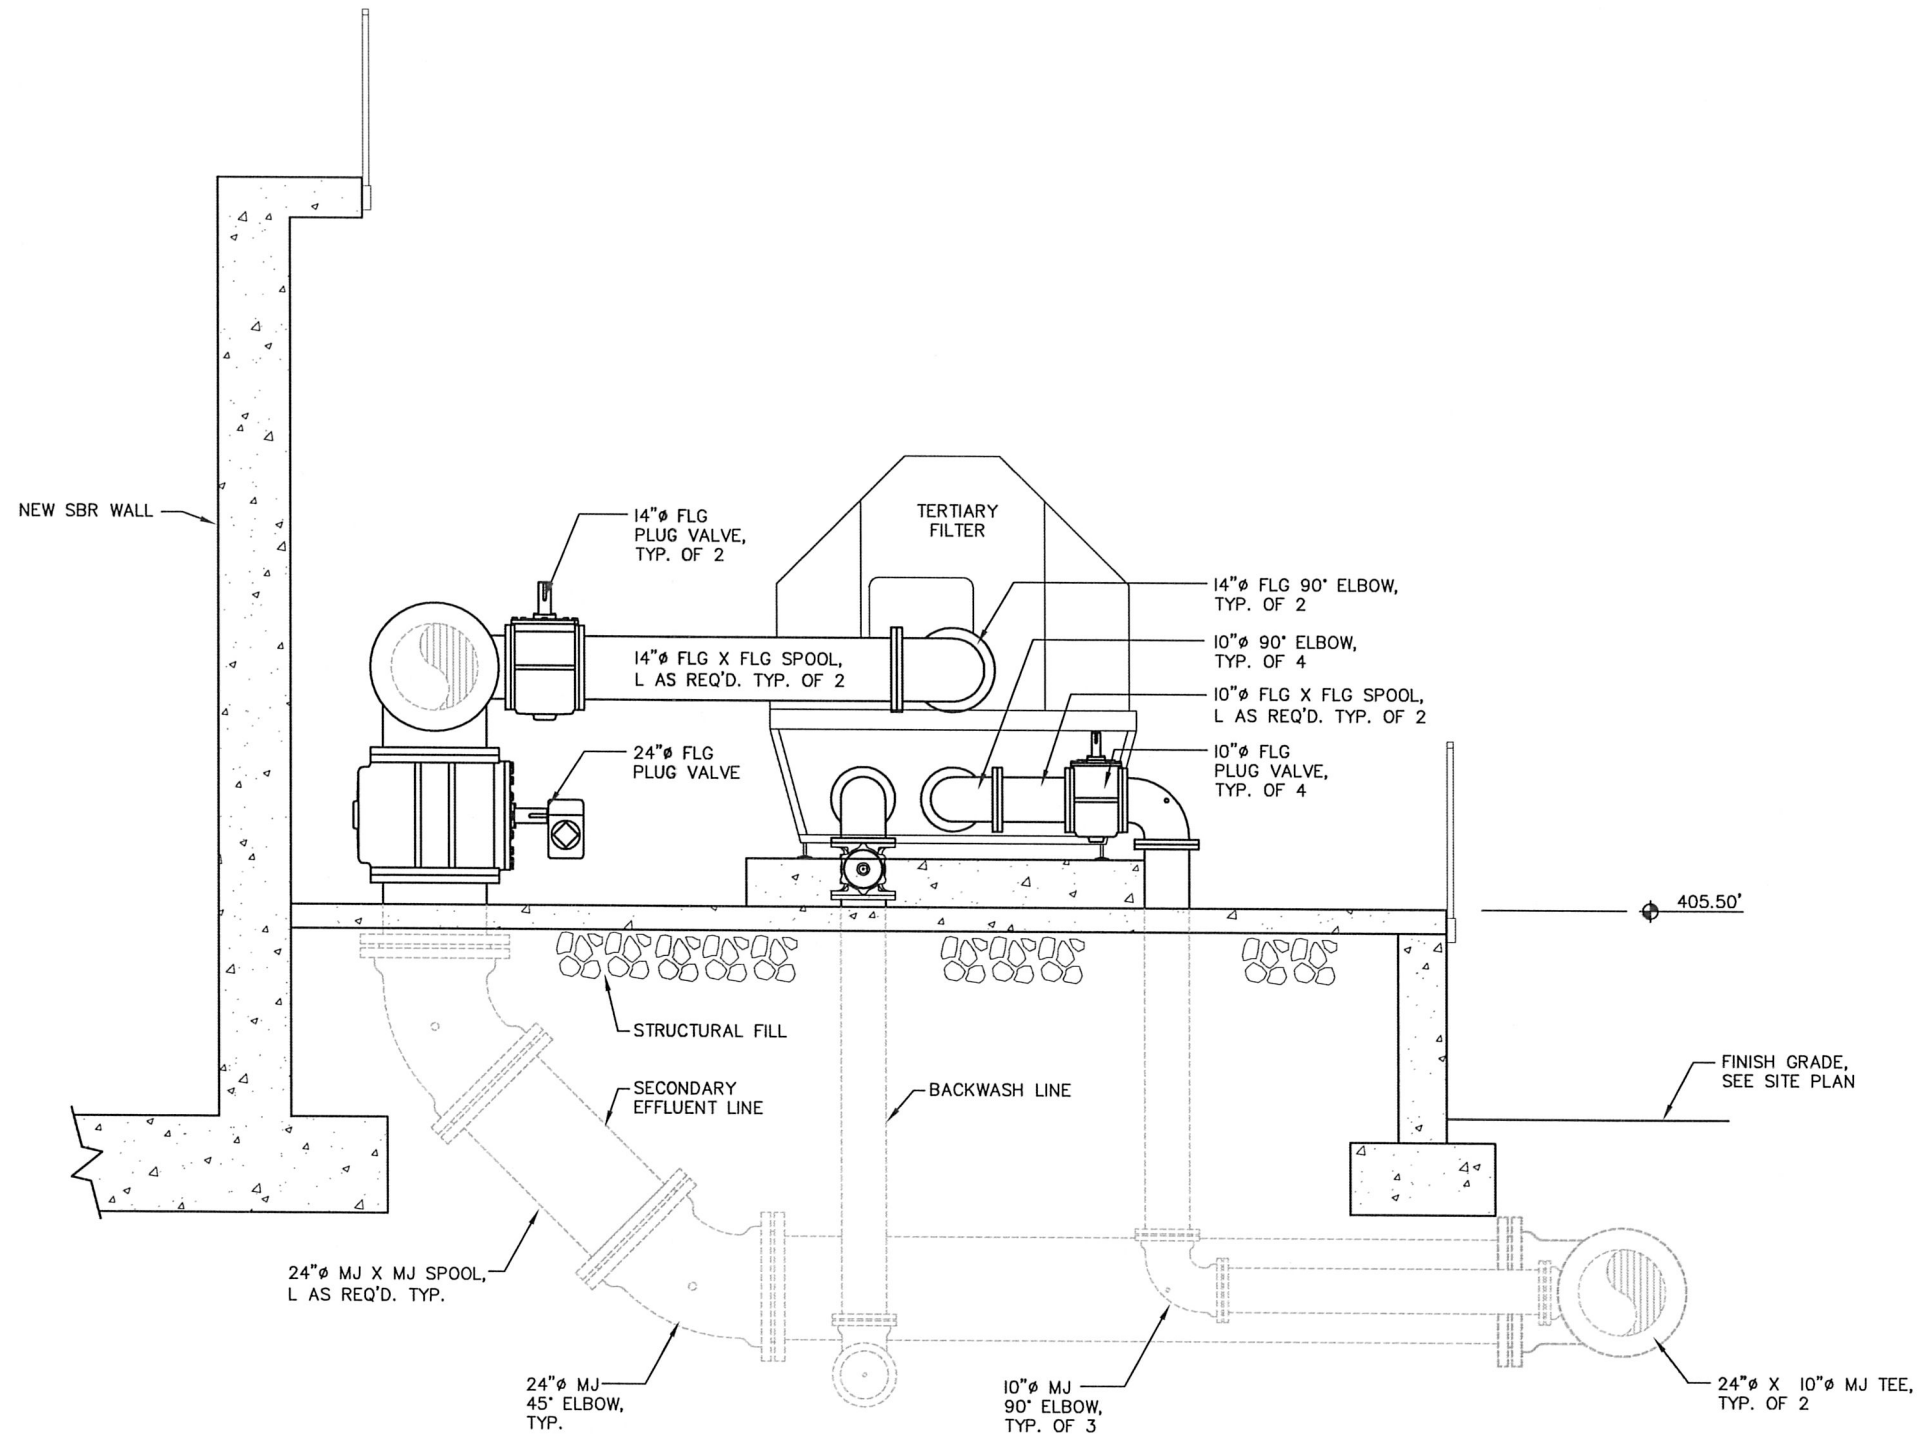

TERTIARY FILTER - SECTION
SCALE: 1" = 4'-0"




DESIGNED: AJS	DRAWN: DLS	REVISIONS			
APPROVED BY:		REVISED	DESCRIPTION	SUBMIT.	APPR'D. DATE
DATE:					



THE DYER PARTNERSHIP
ENGINEERS & PLANNERS, INC.
1330 TEAKWOOD AVENUE
COOS BAY, OREGON 97420
TELEPHONE: (541) 269-0732
www.dyerpart.com

LINE IS 1 INCH
AT FULL SCALE
IF NOT 1-INCH - SCALE ACCORDINGLY

WASTEWATER TREATMENT PLANT IMPROVEMENTS CITY OF SUTHERLIN		PROJECT NO. 146.38	DRAWING NO. M1002
TERTIARY FILTER MECHANICAL- SECTION		DATE MAY 2016	SHEET NO. 56 OF 70

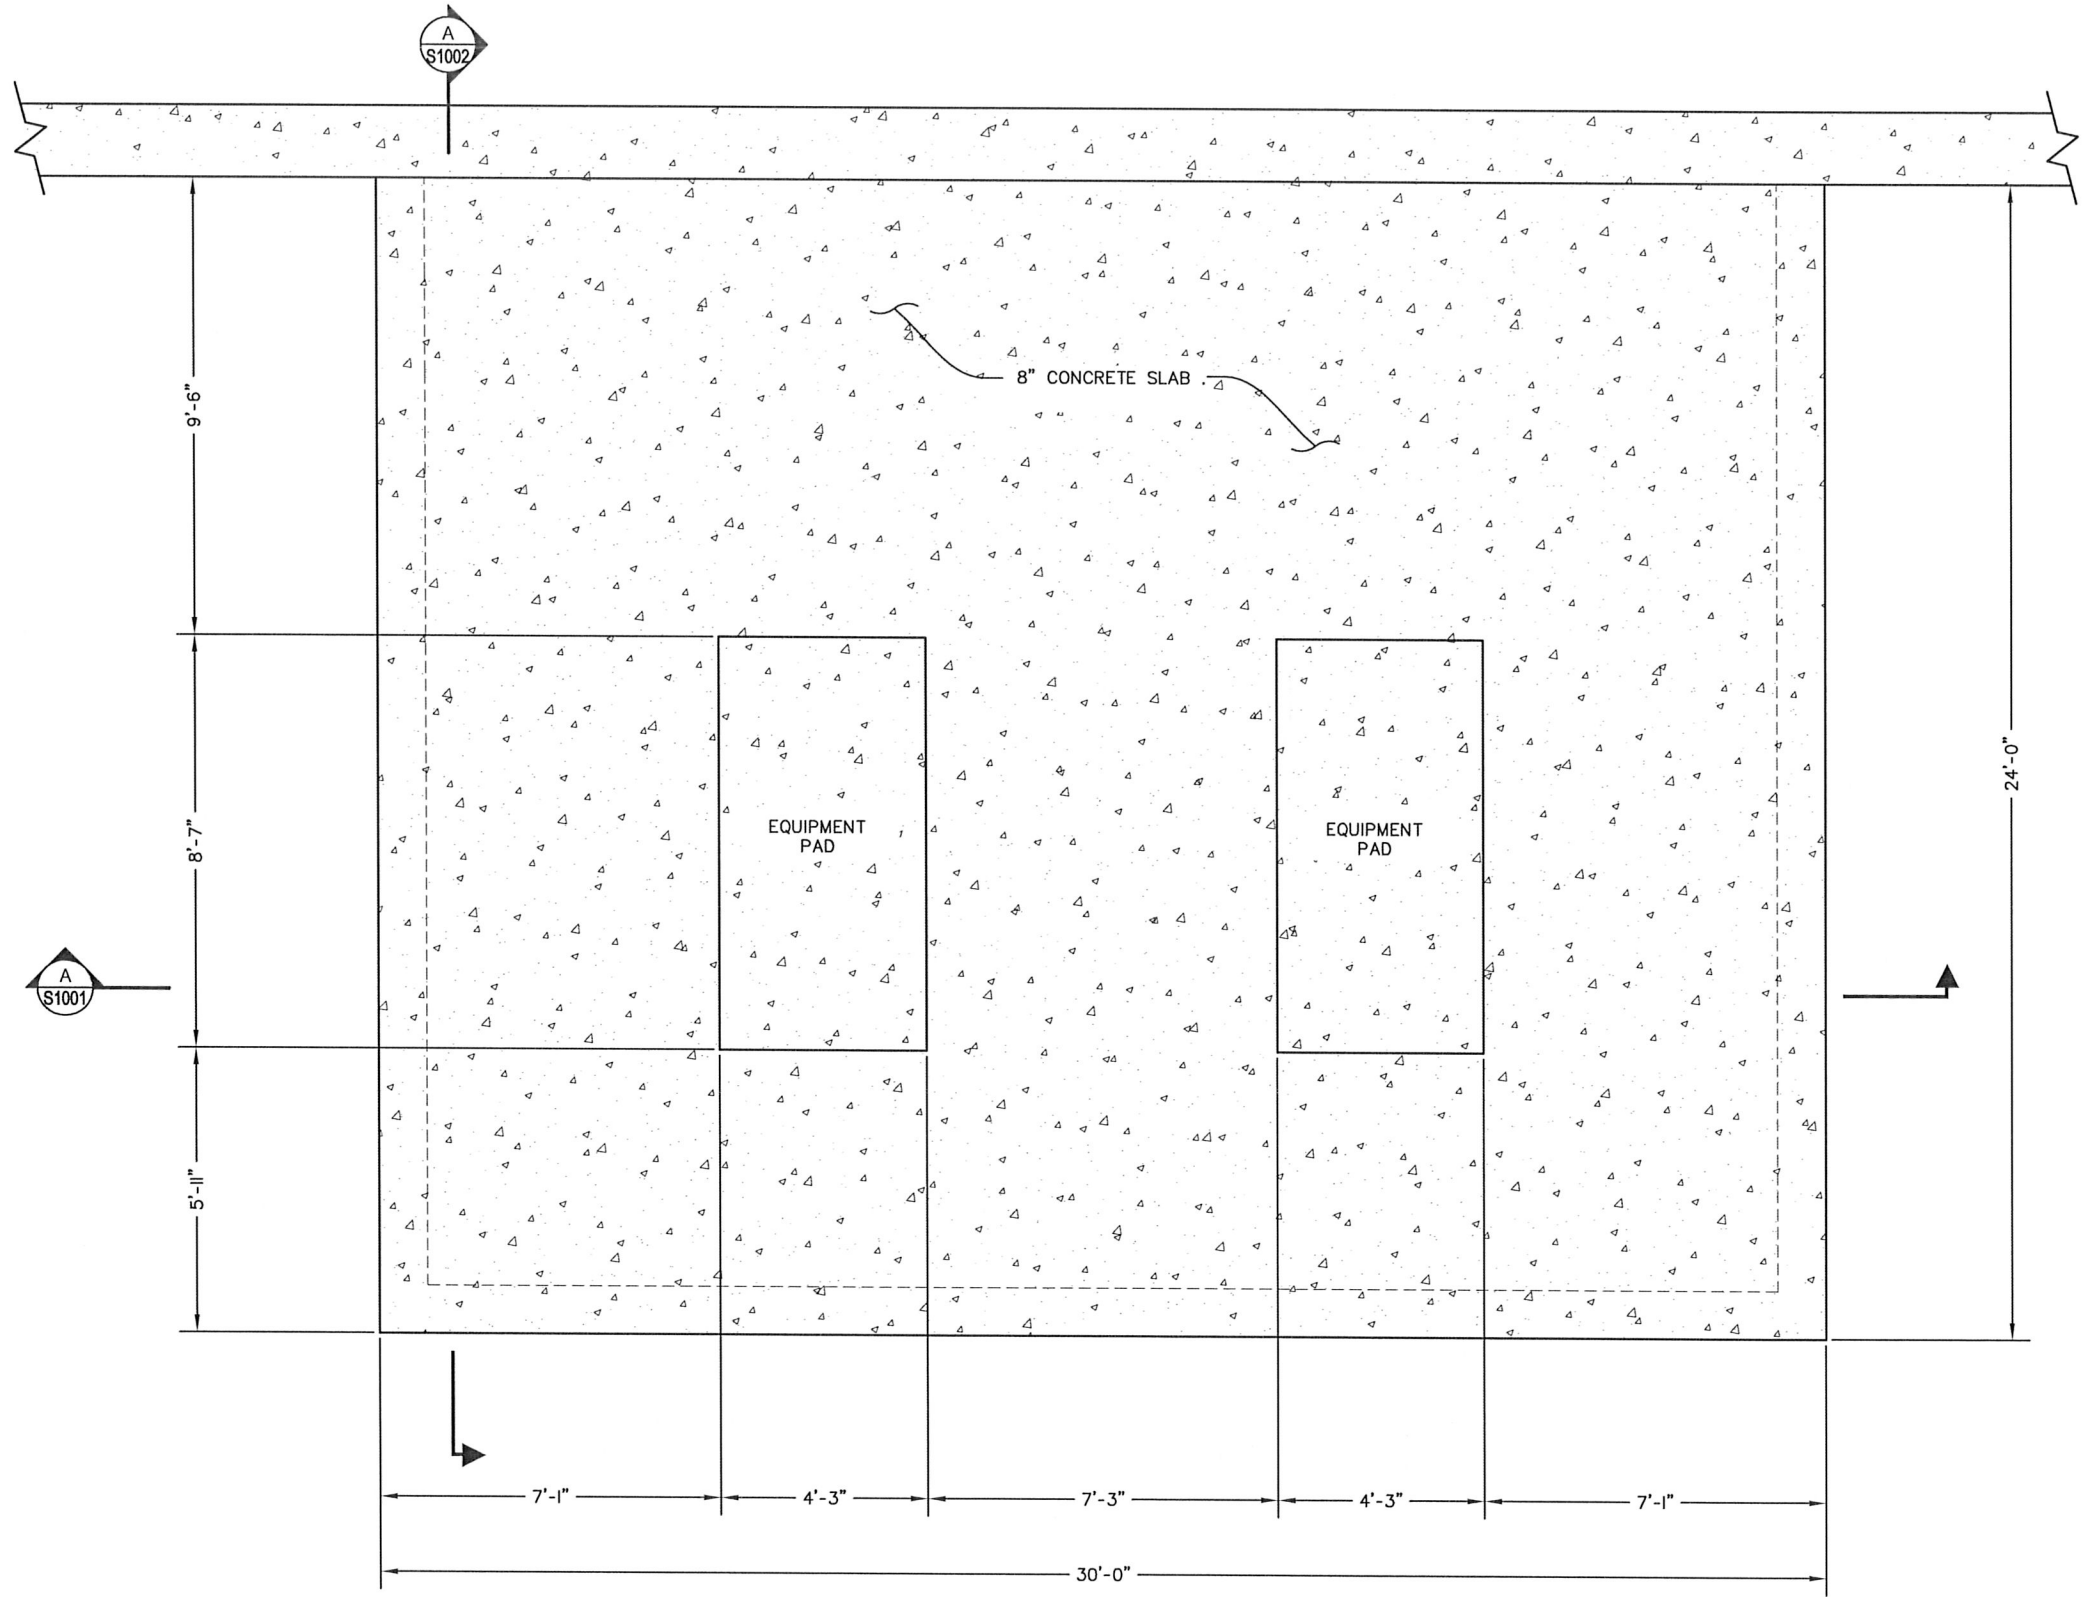

TERTIARY FILTER - PLAN VIEW
SCALE: 1" = 4'-0"

1
S1000




DESIGNED: AJS	DRAWN: DLS	REVISIONS			
APPROVED BY:		REVISED	DESCRIPTION	SUBMIT.	APPR'D.
DATE:					

D

THE DYER PARTNERSHIP
ENGINEERS & PLANNERS, INC.
1330 TEAKWOOD AVENUE
COOS BAY, OREGON 97420
TELEPHONE: (541) 269-0732
www.dyerpart.com

LINE IS 1 INCH
AT FULL SCALE
IF NOT 1-INCH - SCALE ACCORDINGLY

WASTEWATER TREATMENT PLANT IMPROVEMENTS CITY OF SUTHERLIN		PROJECT NO. 146.38	DRAWING NO. S1000
TERTIARY FILTER STRUCTURAL- PLAN VIEW		DATE MAY 2016	SHEET NO. 57 OF 70

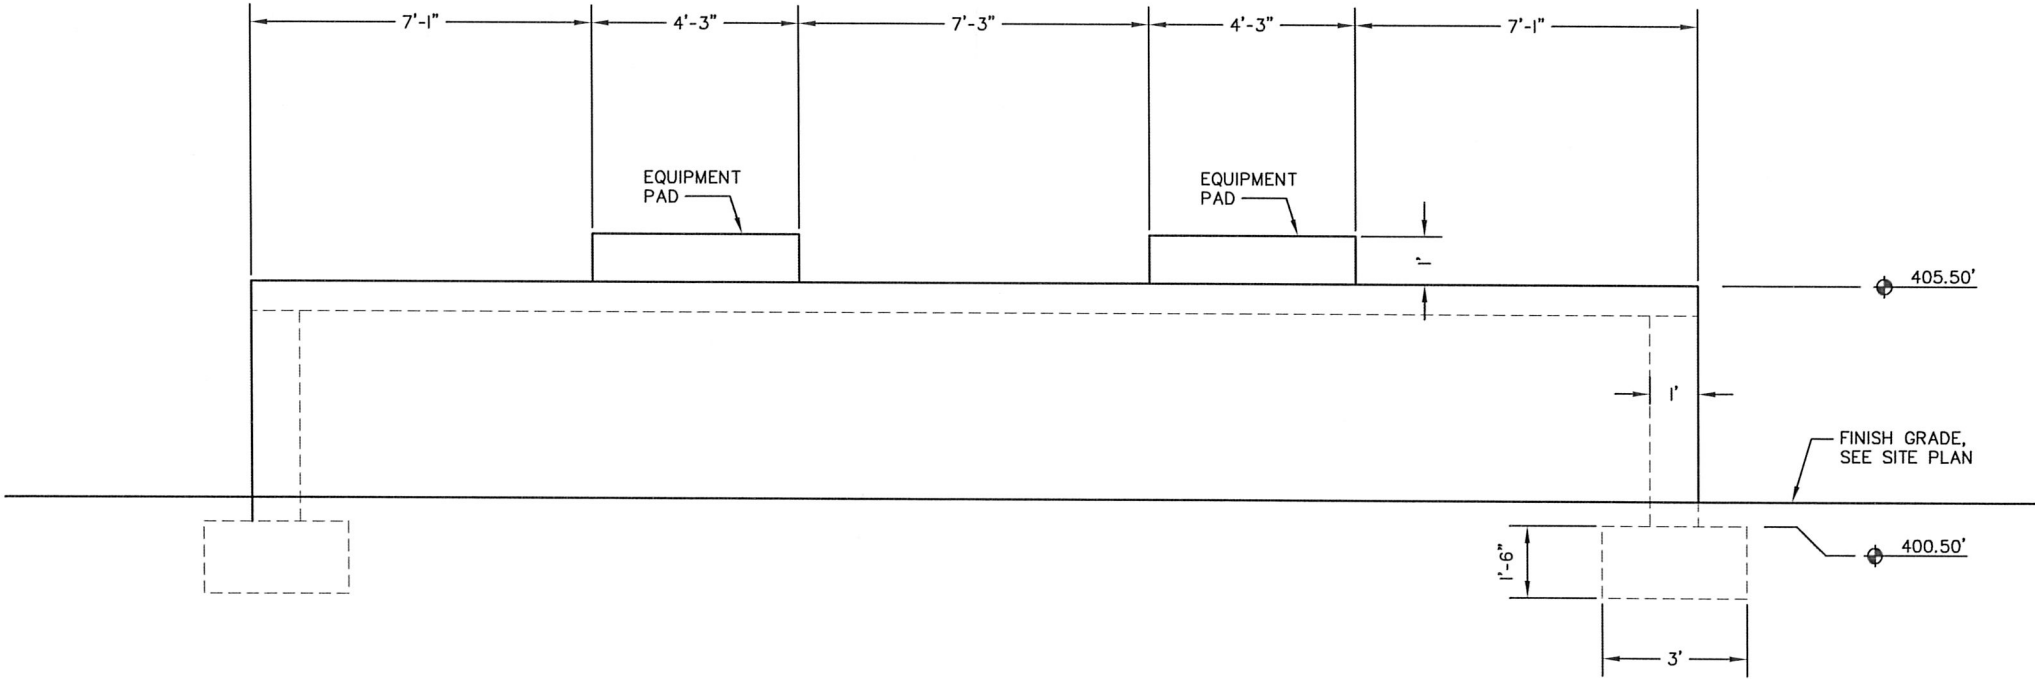

TERTIARY FILTER - SECTION
SCALE: 1" = 4'-0"



DESIGNED: AJS	DRAWN: DLS
APPROVED BY: DATE:	

REVISIONS				
REVISED	DESCRIPTION	SUBMIT.	APPR'D.	DATE




THE DYER PARTNERSHIP
ENGINEERS & PLANNERS, INC.
1330 TEAKWOOD AVENUE
COOS BAY, OREGON 97420
TELEPHONE: (541) 269-0732
www.dyerpart.com

LINE IS 1 INCH
AT FULL SCALE
IF NOT 1-INCH - SCALE ACCORDINGLY

**WASTEWATER TREATMENT PLANT IMPROVEMENTS
CITY OF SUTHERLIN**

**TERTIARY FILTER
STRUCTURAL- SECTION**

PROJECT NO. 146.38	DRAWING NO. S1001
DATE MAY 2016	SHEET NO. 58 OF 70

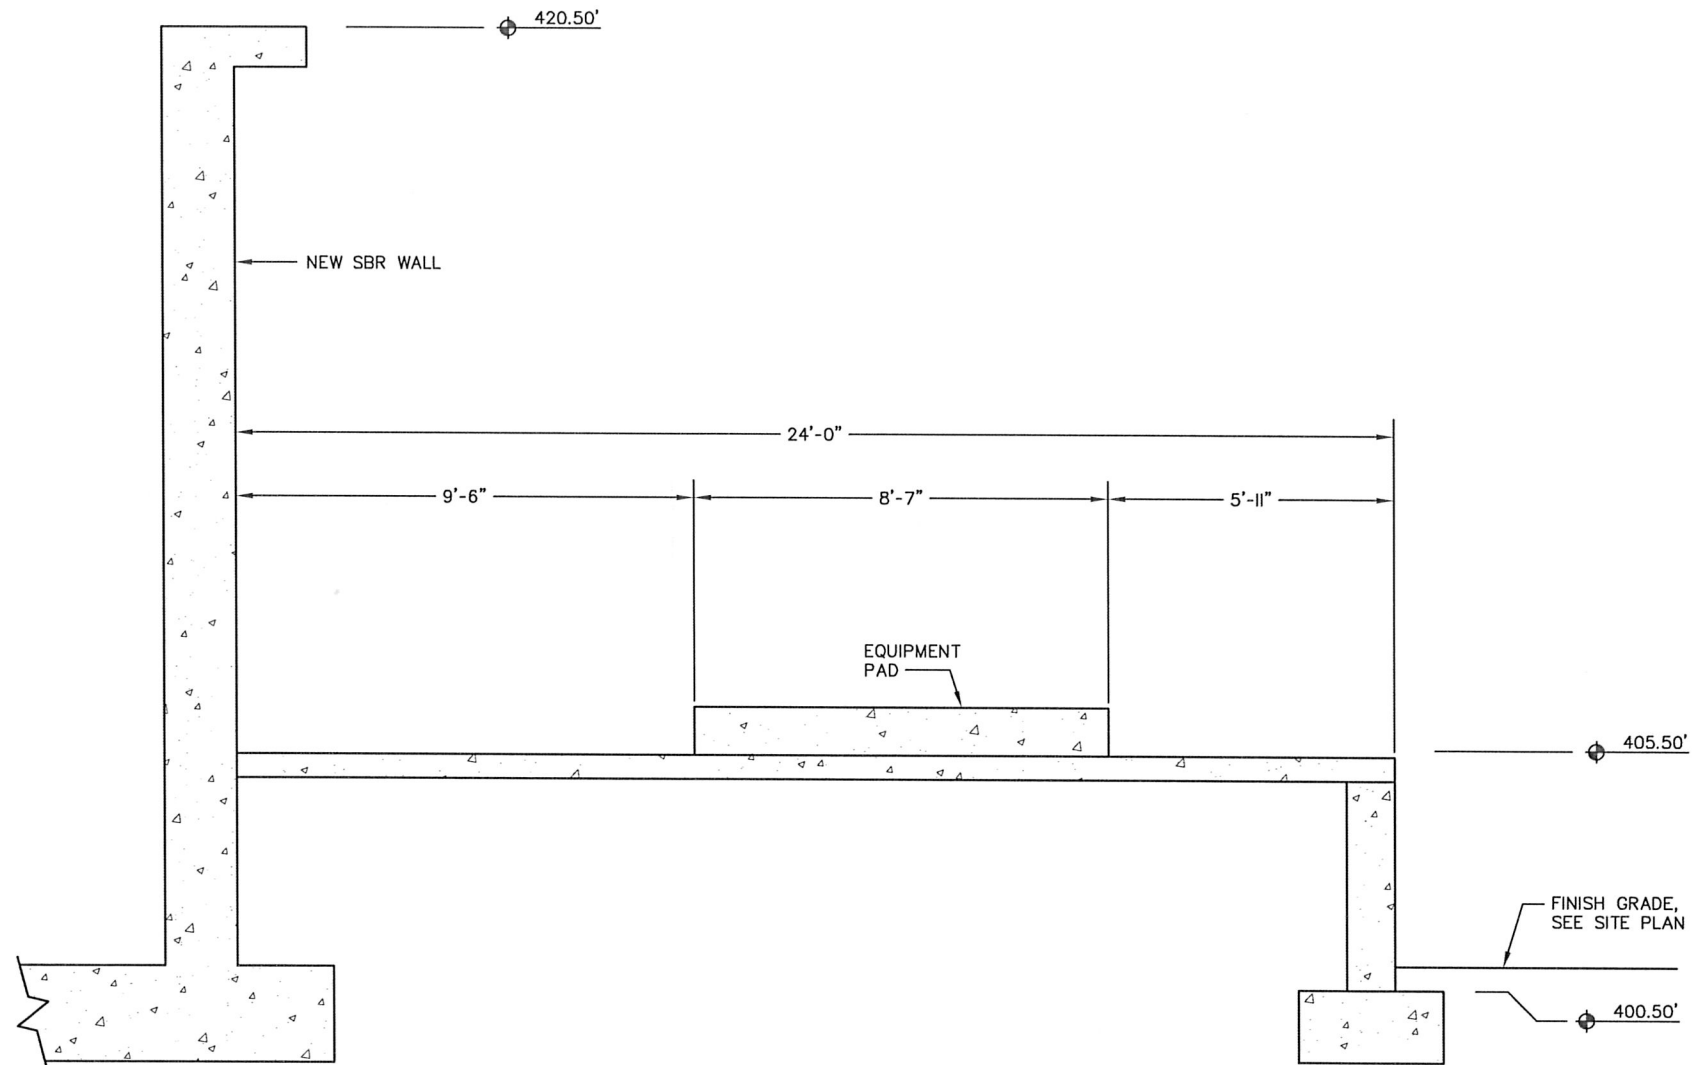

TERTIARY FILTER - SECTION
SCALE: 1" = 4'-0"



DESIGNED:
AJS

DRAWN:
DLS

APPROVED BY:
DATE:

REVISIONS				
REVISED	DESCRIPTION	SUBMIT.	APPR'D.	DATE




THE DYER PARTNERSHIP
ENGINEERS & PLANNERS, INC.
1330 TEAKWOOD AVENUE
COOS BAY, OREGON 97420
TELEPHONE: (541) 269-0732
www.dyerpart.com

LINE IS 1 INCH
AT FULL SCALE
IF NOT 1-INCH - SCALE ACCORDINGLY

WASTEWATER TREATMENT PLANT IMPROVEMENTS
CITY OF SUTHERLIN

TERTIARY FILTER
STRUCTURAL- SECTION

PROJECT NO. 146.38	DRAWING NO. S1002
DATE MAY 2016	SHEET NO. 59 OF 70

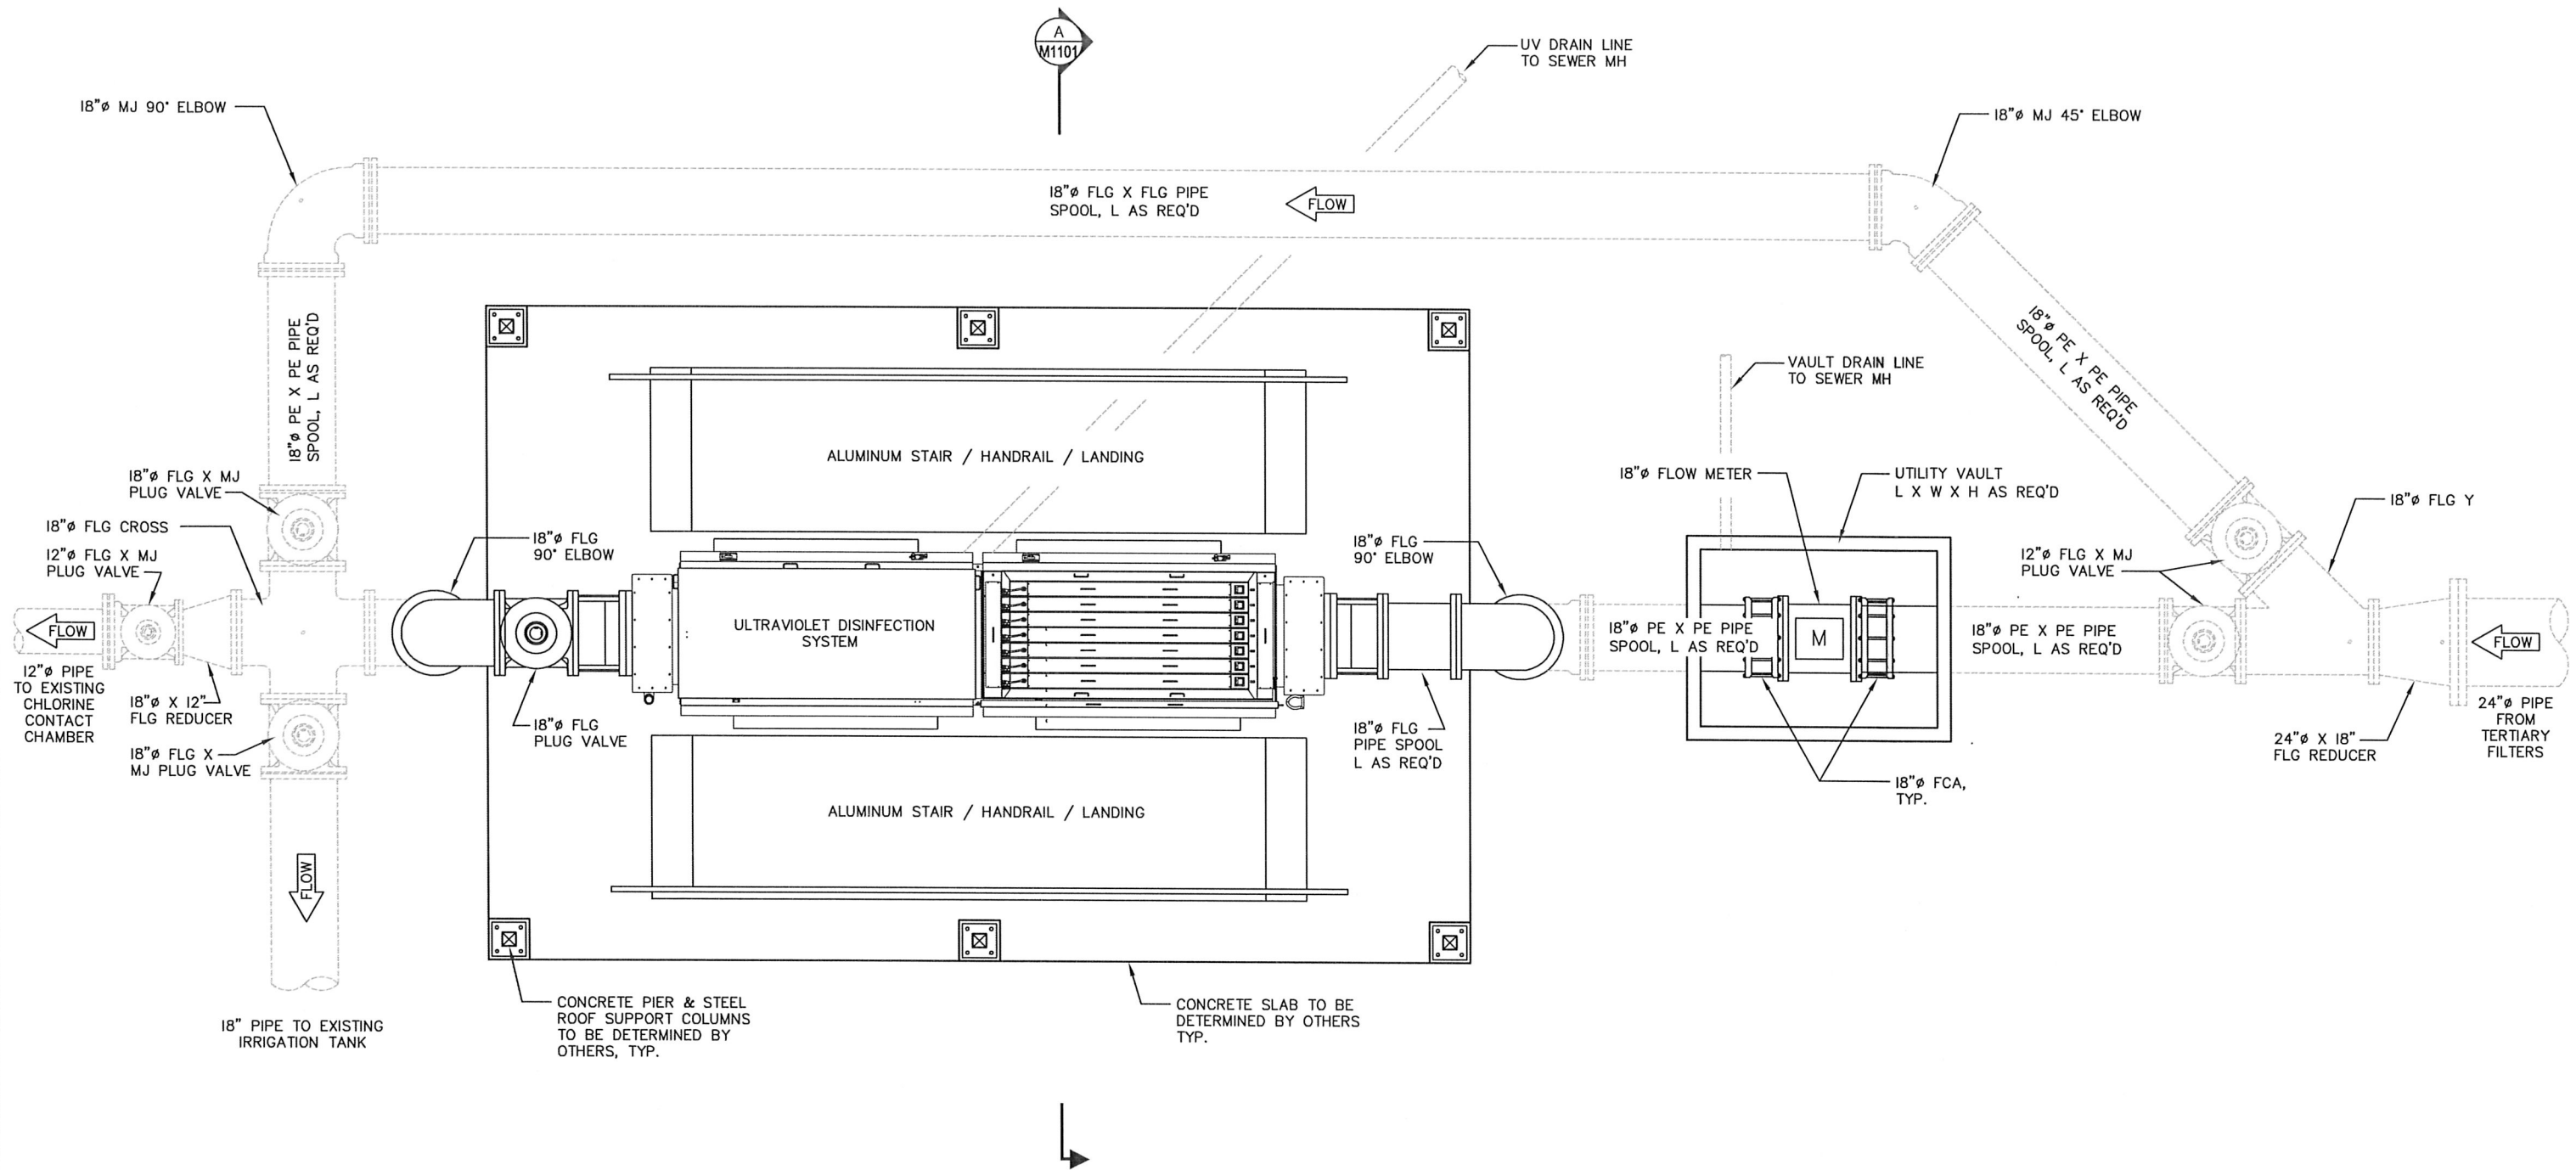

UV DISINFECTION - PLAN VIEW
 SCALE: 1" = 4'-0"

1
 M1100



DESIGNED:	DRAWN:
---	---
APPROVED BY:	DATE:
---	---

REVISIONS				
REVISED	DESCRIPTION	SUBMIT.	APPR'D.	DATE

THE DYER PARTNERSHIP
 ENGINEERS & PLANNERS, INC.
 1330 TEAKWOOD AVENUE
 COOS BAY, OREGON 97420
 TELEPHONE: (541) 269-0732
 www.dyerpart.com

LINE IS 1 INCH
 AT FULL SCALE
 IF NOT 1-INCH - SCALE ACCORDINGLY

WASTEWATER TREATMENT PLANT IMPROVEMENTS CITY OF SUTHERLIN UV DISINFECTION MECHANICAL - PLAN VIEW		PROJECT NO.	DRAWING NO.
		146.38	M1100
		DATE	SHEET NO.
		MAY 2016	60 OF 70




DESIGNED:	DRAWN:
---	---
APPROVED BY:	
_____ DATE: _____	

REVISIONS					
REVISED	DESCRIPTION	SUBMIT.	APPR'D.	DATE	



THE DYER PARTNERSHIP
ENGINEERS & PLANNERS, INC.
1330 TEAKWOOD AVENUE
COOS BAY, OREGON 97420
TELEPHONE: (541) 269-0732
www.dyerpart.com

LINE IS 1 INCH
AT FULL SCALE
IF NOT 1-INCH - SCALE ACCORDINGLY

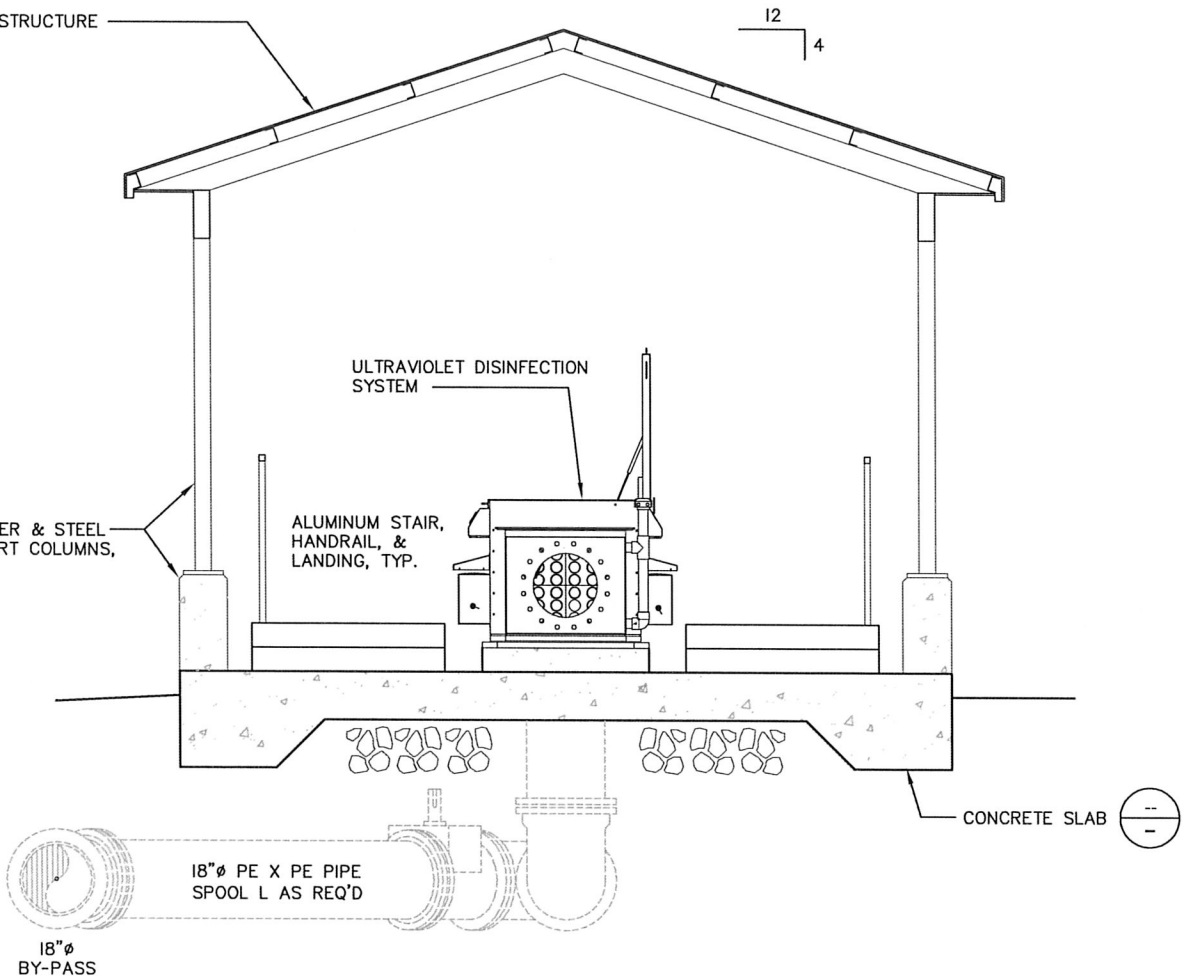


UV DISINFECTION - SECTION
SCALE: 1" = 4'-0"



WASTEWATER TREATMENT PLANT IMPROVEMENTS
CITY OF SUTHERLIN

UV DISIFECTION
MECHANICAL - TYPICAL SECTION

PROJECT NO.	DRAWING NO.
146.38	M1101
DATE	SHEET NO.
MAY 2016	61 OF 70

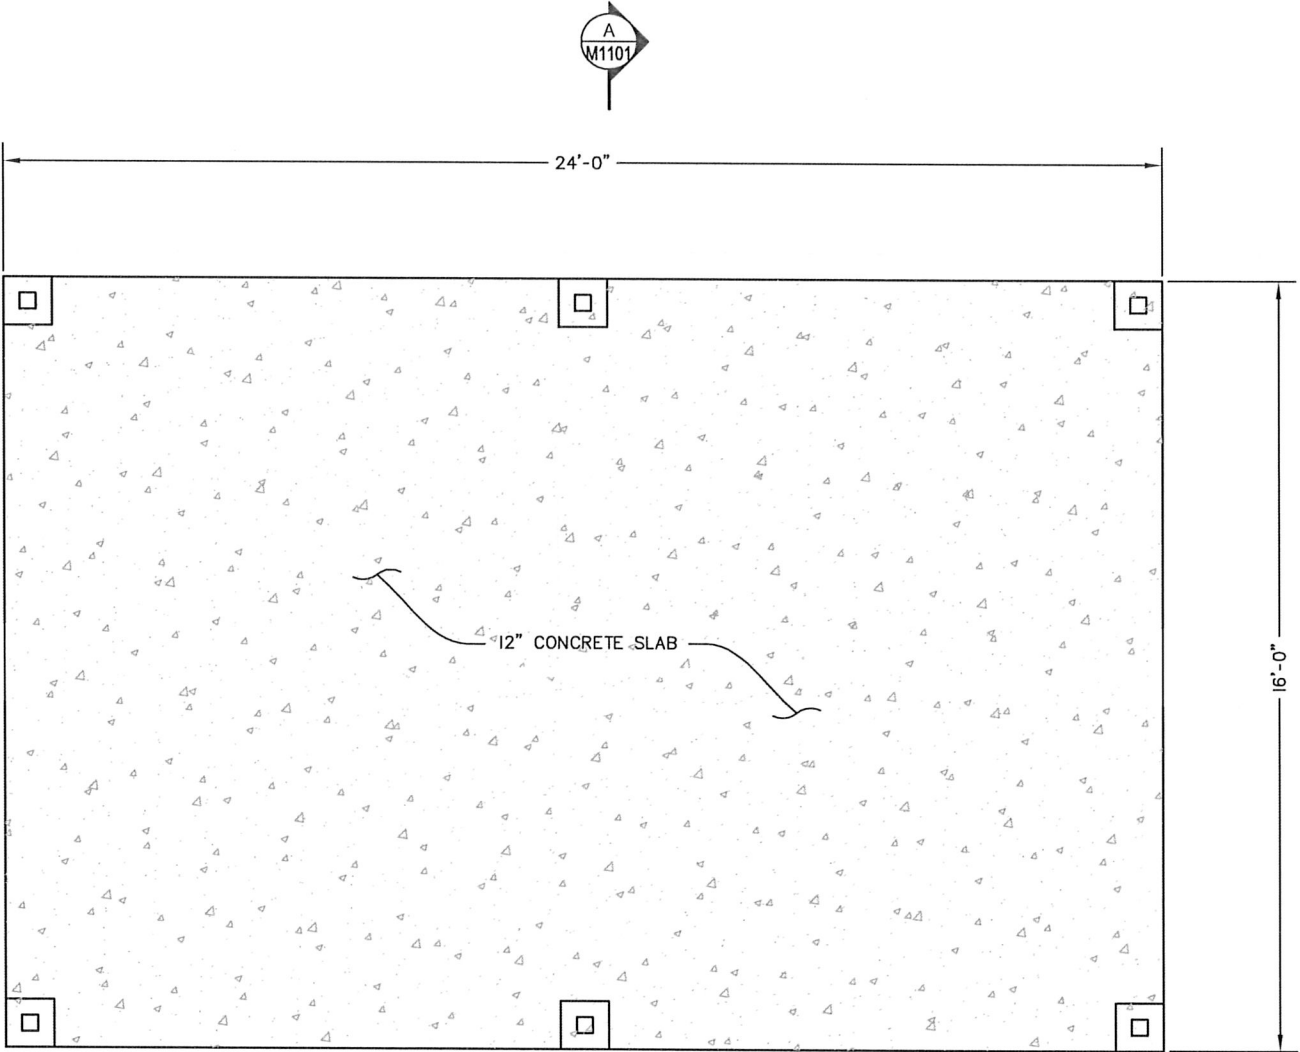

NOTE:
SLOPE TOP OF SLAB TO
ULTRAVIOLET DISINFECTION
EQUIPMENT DRAIN LOCATION



UV DISINFECTION - PLAN VIEW
SCALE: 1" = 4'-0"

1
S1100



DESIGNED:

DRAWN:

APPROVED BY:

DATE: _____

REVISIONS				
REVISED	DESCRIPTION	SUBMIT.	APPR'D.	DATE



THE DYER PARTNERSHIP
ENGINEERS & PLANNERS, INC.
1330 TEAKWOOD AVENUE
COOS BAY, OREGON 97420
TELEPHONE: (541) 269-0732
www.dyerpart.com

LINE IS 1 INCH
AT FULL SCALE
IF NOT 1-INCH - SCALE ACCORDINGLY

WASTEWATER TREATMENT PLANT IMPROVEMENTS
CITY OF SUTHERLIN

UV DISIFECTION
STRUCTURAL - PLAN VIEW

PROJECT NO. 146.38	DRAWING NO. S1100
DATE MAY 2016	SHEET NO. 62 OF 70

\\dye\dyer-part\A\Projects\146 Sutherlin\146.38 WWTF Pre-Design Report\dwg\PRE-DESIGN\PROCESS AREA 1300 SLUDGE HOLDING\NEW DIGESTER TANKS.dwg, 11/30/2015 2:12:49 PM PLOT DATE May 10, 2016

TO DEWATERING
FACILITY IN
EXISTING
FILTER
BUILDING

TO NEW
INFLUENT
PUMP STATION

EXISTING 18" IRRIGATION LINE TO
GOLF COARSE / FORDS POND

EXISTING 27" OUTFALL LINE

EXISTING 18" IRRIGATION LINE
TO FARM

CHLORINE CONTACT CHAMBER

IRRIGATION CHAMBER

TANK 1S

TANK 1N

TANK 4S

TANK 4N

TANK 2S

TANK 2N

TANK 3S

TANK 3N

SEE B/M1301

 
SEE A/M1301

SEE
SHEET
M1302

SEE
SHEET
M1303


KEY NOTES

- 1 NEW 3" WAS FROM SBR STRUCTURE
- 2 NEW 3" MJ 90° ELBOW, TYP. OF 9
- 3 NEW 6" MJ 90° ELBOW, TYP. OF 13
- 4 NEW 4" MJ 11.25' ELBOW, TYP. OF 4
- 5 NEW 8" MJ 90° ELBOW
- 6 NEW 8" X 4" MJ TEE, TYP OF 7
- 7 NEW 3" MJ TEE, TYP OF 7
- 8 NEW 6" MJ TEE, TYP OF 6
- 9 NEW 6" TRANSFER SLUDGE PIPING
- 10 NEW 3" MJ 45° ELBOW, TYP OF 4
- 11 NEW 6" MJ 45° ELBOW, TYP OF 4
- 12 NEW 8" MJ 45° ELBOW, TYP OF 4
- 13 NEW 8" DECANT DRAIN TO NEW INFLUENT PUMP STATION
- 14 NEW 6" FLG X MJ PLUG VALVE TYP. OF 4
- 15 NEW 6" FLG TEE, TYP. OF 4
- 16 NEW 6" FCA, TYP. OF 2
- 17 NEW 6" PIPE SPOOL, LENGTH AS REQUIRED
- 18 NEW 3" FLG 90° ELBOW, TYP. OF 16
- 19 NEW 6" FLG 90° ELBOW, TYP. OF 24
- 20 NEW 4" TELESCOPING VALVE, TYP. OF 8
- 21 NEW 8" FLG PLUG VALVE TYP. OF 10
- 22 NEW 8" FLG 11.25' ELBOW, TYP. OF 20
- 23 NEW 8" FLG 90° ELBOW, TYP. OF 4
- 24 NEW 8" FLG TEE, TYP. OF 8
- 25 NEW 8" FLG PIPE SPOOL, LENGTH AS REQUIRED
- 26 NEW BIOSOLIDS TRANSFER PUMP
- 27 NEW 4" MJ 45° ELBOW, TYP OF 2
- 28 NEW 8" X 4" MJ REDUCER
- 29 NEW BIOSOLIDS TRANSFER PUMP



PLAN VIEW

 1
M1300



DESIGNED:

DRAWN:

REVISIONS

REVISED	DESCRIPTION	SUBMIT.	APPR'D.	DATE



THE DYER PARTNERSHIP
ENGINEERS & PLANNERS, INC.
1330 TEAKWOOD AVENUE
COOS BAY, OREGON 97420
TELEPHONE: (541) 269-0732
www.dyerpart.com

LINE IS 1 INCH
AT FULL SCALE
IF NOT 1-INCH - SCALE ACCORDINGLY

WASTEWATER TREATMENT PLANT IMPROVEMENTS CITY OF SUTHERLIN

BIOSOLIDS TREATMENT EXISTING DIGESTER - REHABILITATION

PROJECT NO.

146.38

DRAWING NO.

M1300


DATE

MAY 2016

SHEET NO.

63 OF 70


LOT DATE
11/30/2015 4:41:18 PMP
\\dye-er-part\A\Projects\146 Sutherlin\146.38 WWTF Pre-Design Report\dwg\PRE-DESIGN\PROCESS AREA 1300 SLUDGE HOLDING\SECTIONS.dwg

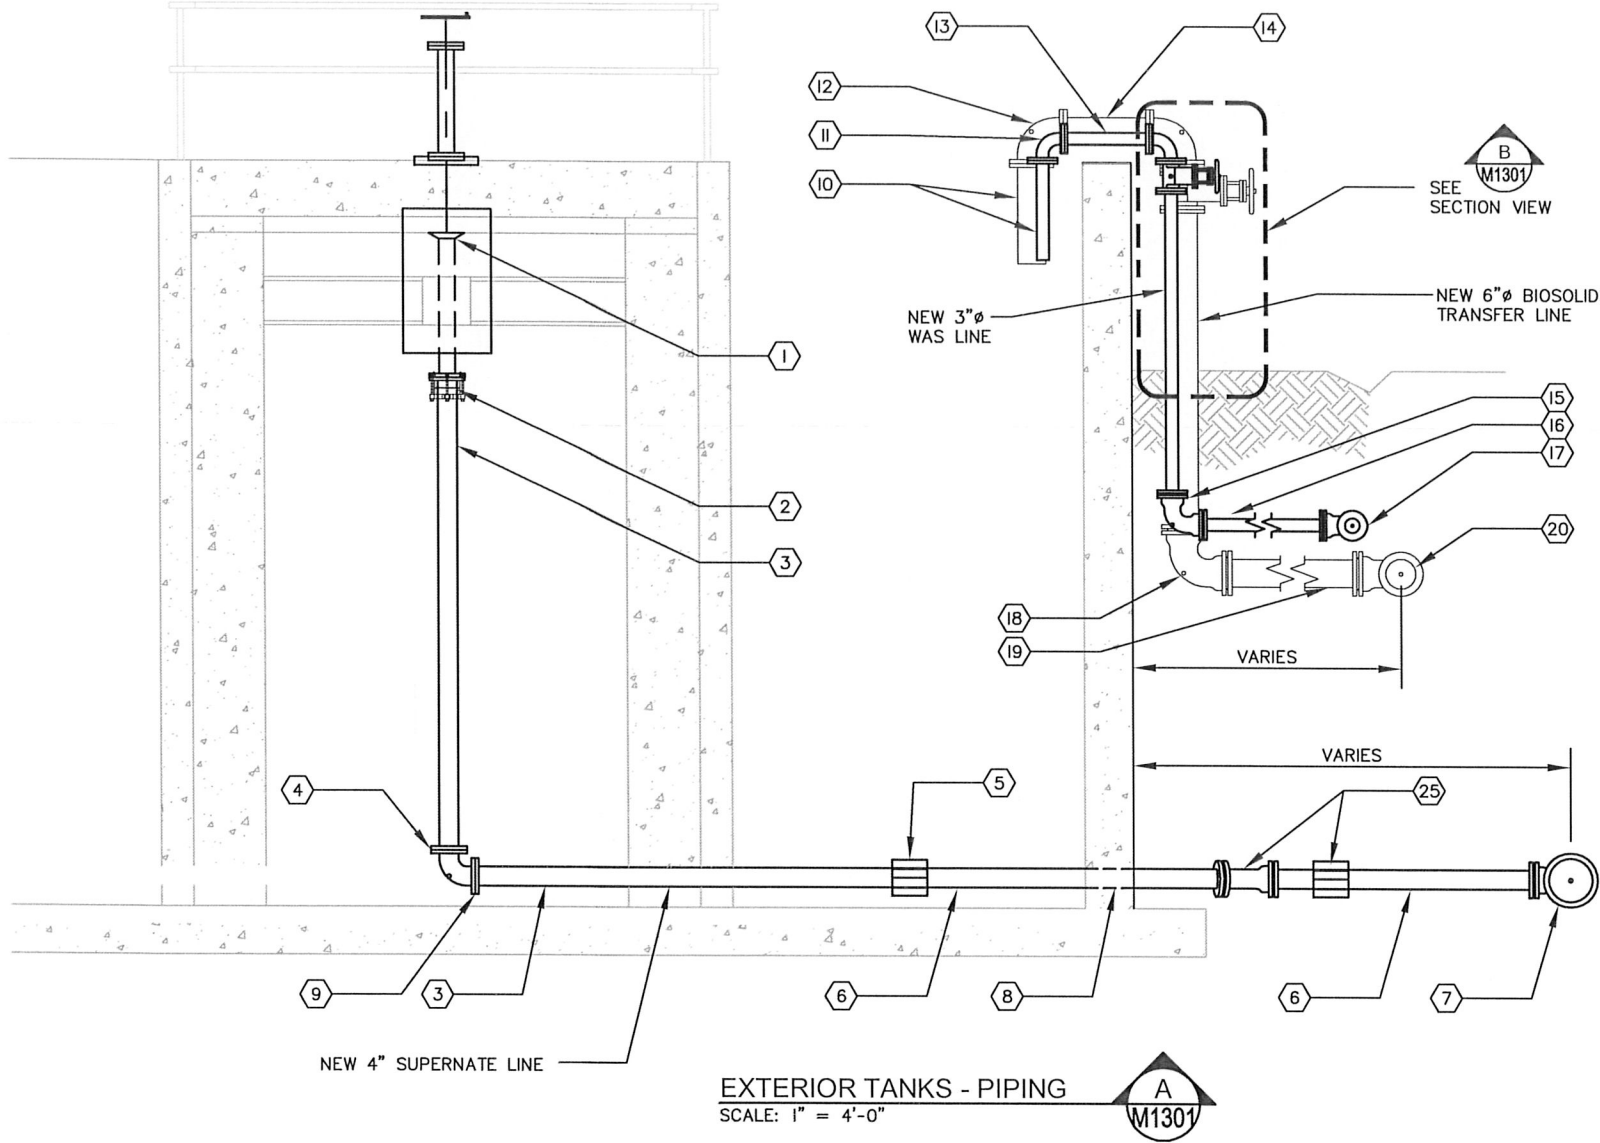

404.50'± TOP OF BASIN WALL

400.00'± EXISTING FINISH GRADE

389.00'± TOP OF BOTTOM BASIN SLAB

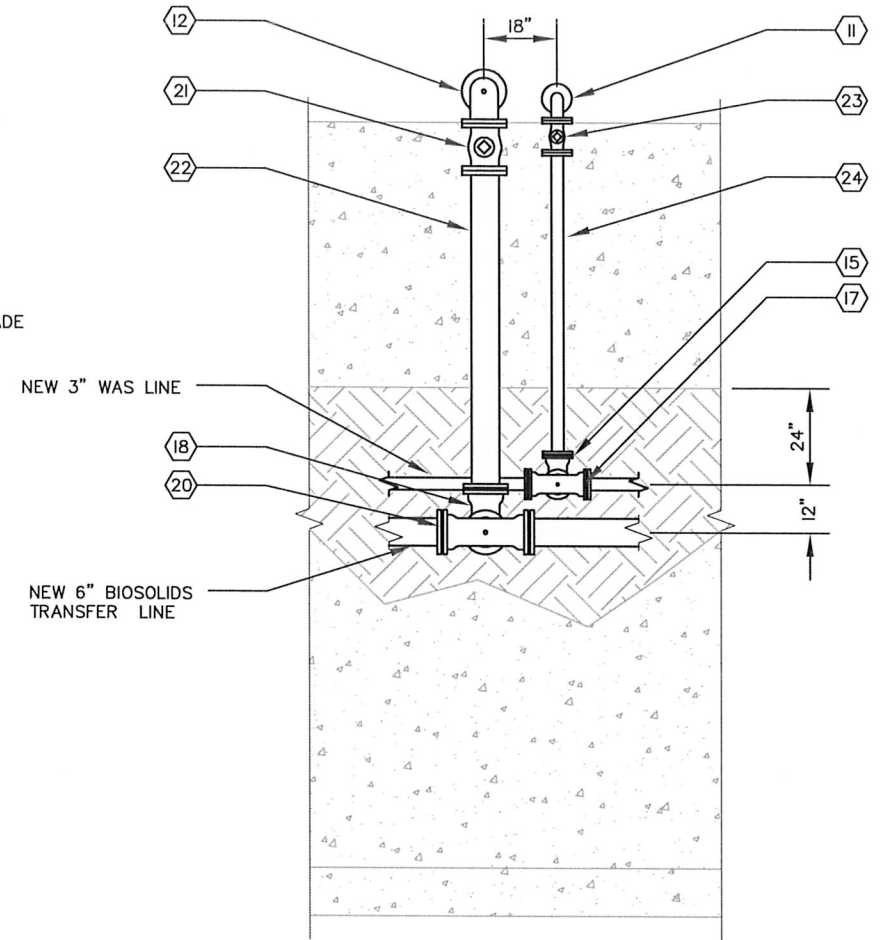

EXTERIOR TANKS - PIPING
SCALE: 1" = 4'-0"

KEY NOTES

- 1 NEW 4" TELESCOPING VALVE
- 2 NEW 4" FCA
- 3 NEW 4" FLG X PE PIPE SPOOL, LENGTH AS REQUIRED
- 4 NEW 4" FLG 90° ELBOW
- 5 NEW 4" RFCA
- 6 NEW 4" PIPE SPOOL, LENGTH AS REQUIRED
- 7 NEW 8" X 4" MJ TEE, EXCEPT FOR TANK 1N, SEE DETAIL
- 8 NEW PIPE PENETRATION, SEE DETAIL
- 9 NEW PIPE SUPPORTS
- 10 NEW 3" FLG X PE PIPE SPOOL, L = 2'-0"

- 11 NEW 3" FLG 90° ELBOW
- 12 NEW 6" FLG 90° ELBOW
- 13 NEW 3" PIPE SPOOL, LENGTH AS REQUIRED
- 14 NEW 6" PIPE SPOOL, LENGTH AS REQUIRED
- 15 NEW 3" MJ 90° ELBOW
- 16 NEW 3" PIPE SPOOL, LENGTH AS REQUIRED
- 17 NEW 3" MJ TEE OR 90° ELBOW, REFER TO PLAN VIEW, SEE SHEET M1300
- 18 NEW 6" MJ 90° ELBOW
- 19 NEW 6" PIPE SPOOL, LENGTH AS REQUIRED
- 20 NEW 6" MJ TEE OR 90° ELBOW, REFER TO PLAN VIEW. SEE SHEET M1300

- 21 NEW 6" FLG PLUG VALVE
- 22 NEW 6" FLG X PE PIPE SPOOL, LENGTH AS REQUIRED
- 23 NEW 3" FLG PLUG VALVE
- 24 NEW 3" FLG X PE PIPE SPOOL, LENGTH AS REQUIRED
- 25 NEW 4" MJ 11.25° ELBOW OR NEW 4" RFCA ON ALL OTHER DECANT PIPING, REFER TO THE PLAN VIEW ON SHEET M1300.



DESIGNED:	DRAWN:	REVISIONS			
----	CGP	REVISED	DESCRIPTION	SUBMIT.	APPR'D. DATE
APPROVED BY:					
DATE:					

THE DYER PARTNERSHIP
ENGINEERS & PLANNERS, INC.
1330 TEAKWOOD AVENUE
COOS BAY, OREGON 97420
TELEPHONE: (541) 269-0732
www.dyerpart.com


LINE IS 1 INCH
AT FULL SCALE
IF NOT 1-INCH - SCALE ACCORDINGLY

WASTEWATER TREATMENT PLANT IMPROVEMENTS CITY OF SUTHERLIN

BIOSOLIDS TREATMENT OUTER TANKS - SECTION VIEWS

PROJECT NO.	DRAWING NO.
146.38	M1301
DATE	SHEET NO.
MAY 2016	64 OF 70

\\dye\dyer-part\A\projects\146 Sutherlin\146.38 WWTF Pre-Design Report\dwg\PRE-DESIGN\PROCESS AREA 1300 SLUDGE HOLDING\SECTIONS.dwg, 11/30/2015 4:41:18 PM PLOT DATE May 5, 2016

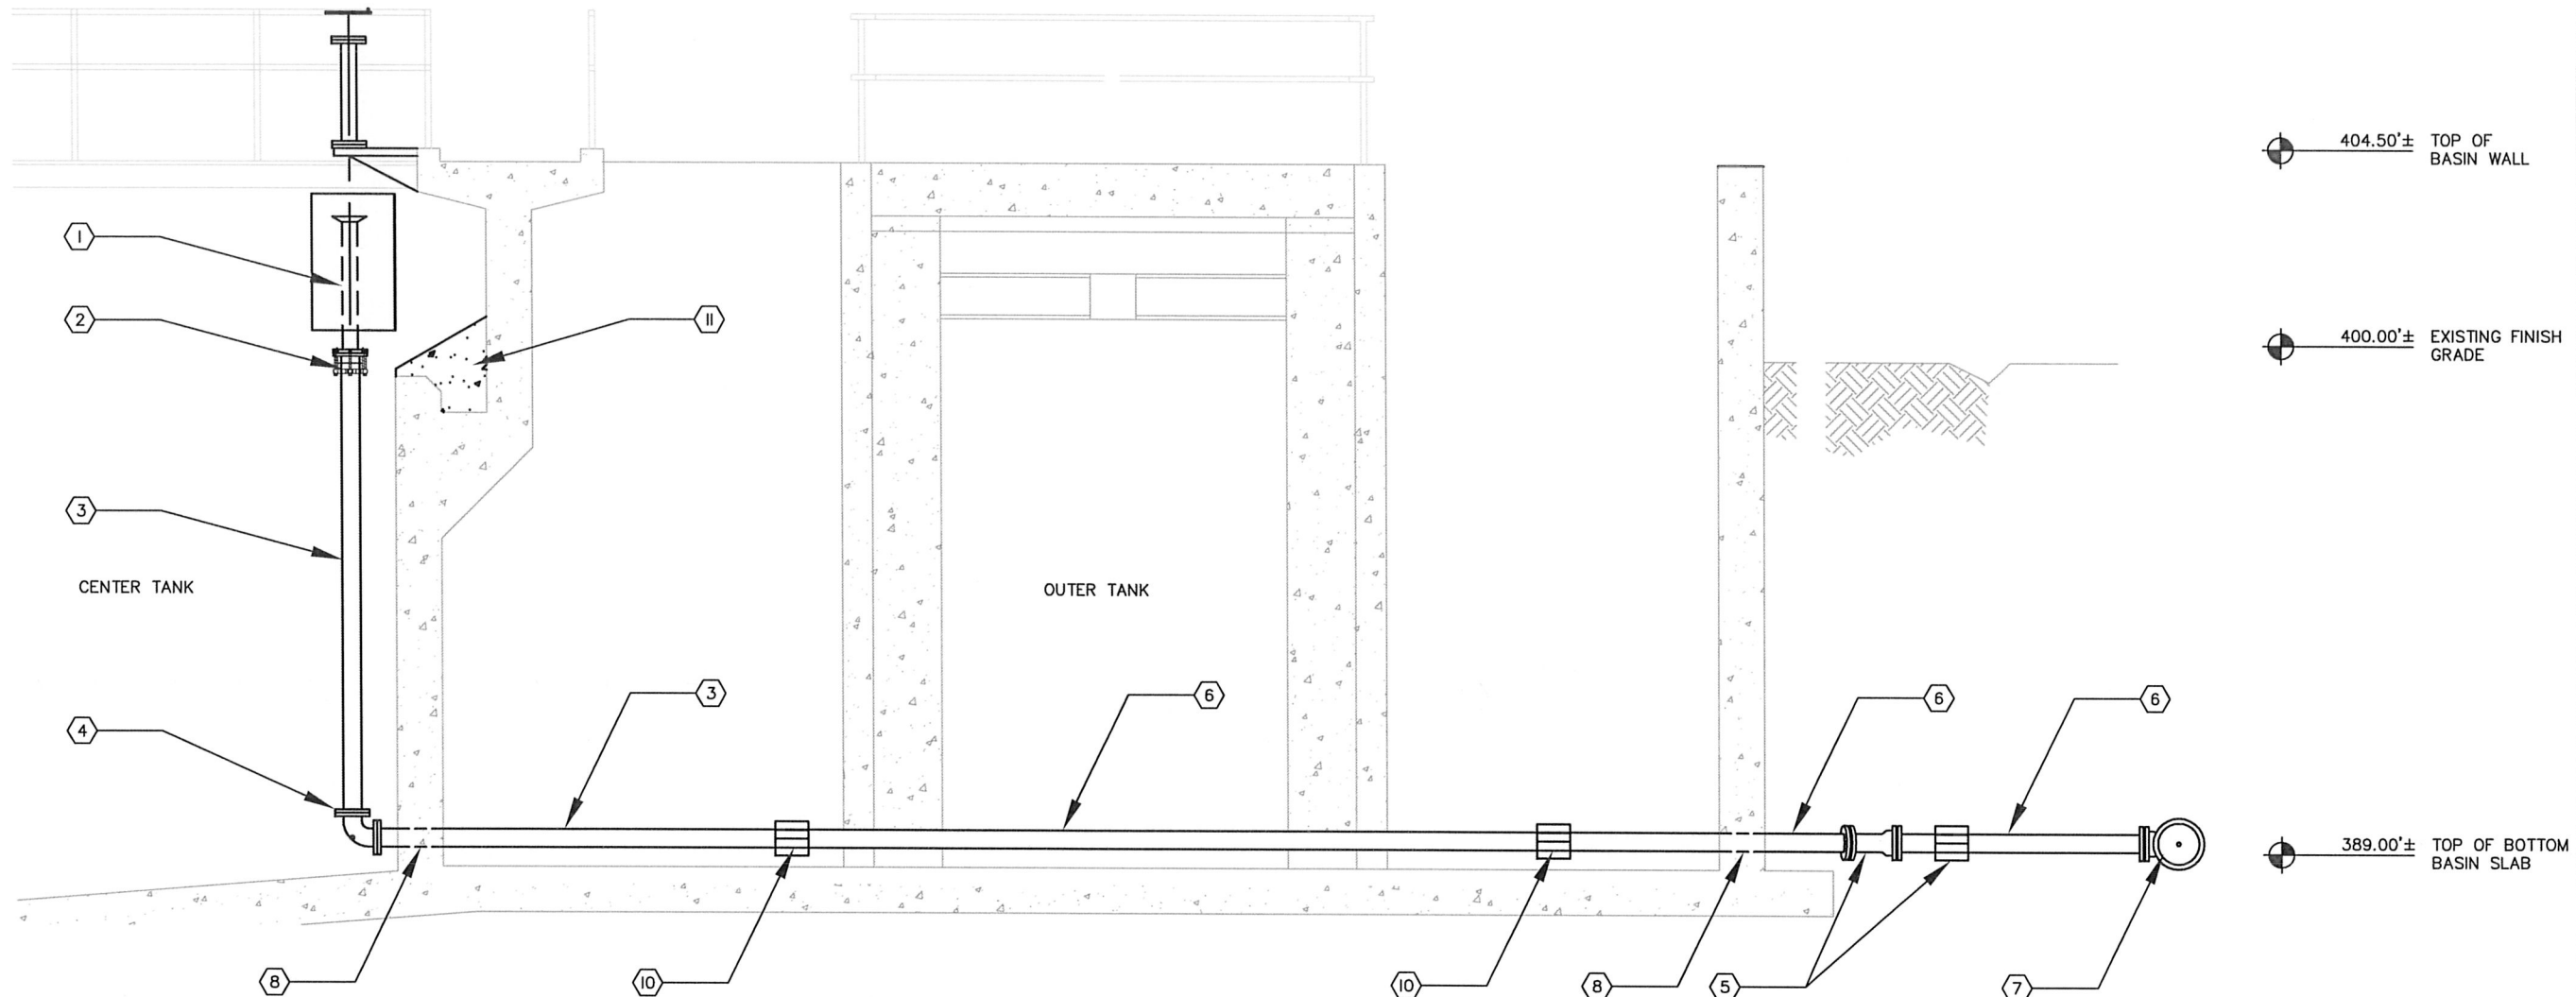

KEY NOTES

- 1 NEW 4" TELESCOPING VALVE
- 2 NEW 4" FCA
- 3 NEW 4" FLG X PE PIPE SPOOL, LENGTH AS REQUIRED
- 4 NEW 4" FLG 90° ELBOW
- 5 NEW 4" MJ 11.25' ELBOW OR NEW 4" RFCA ON ALL OTHER DECANT PIPING, REFER TO THE PLAN VIEW ON SHEET M1300.
- 6 NEW 4" PIPE SPOOL, LENGTH AS REQUIRED
- 7 NEW 8" X 4" MJ TEE OR TEE, REFER TO PLAN SEE SHEET M1300
- 8 NEW PIPE PENETRATION, SEE DETAIL 
- 9 NEW PIPE SUPPORTS 
- 10 NEW 4" FCA
- II GROUT FILL EXISTING CLARIFIER TROUGH

CENTER TANK - SUPERNATE PIPING
SCALE: 1" = 4'-0"



DESIGNED:	DRAWN:
---	---
APPROVED BY:	
DATE:	

REVISIONS				
REVISED	DESCRIPTION	SUBMIT	APPR'D	DATE




THE DYER PARTNERSHIP
ENGINEERS & PLANNERS, INC.
1330 TEAKWOOD AVENUE
COOS BAY, OREGON 97420
TELEPHONE: (541) 269-0732
www.dyerpart.com

LINE IS 1 INCH
AT FULL SCALE
IF NOT 1-INCH - SCALE ACCORDINGLY

WASTEWATER TREATMENT PLANT IMPROVEMENTS CITY OF SUTHERLIN		PROJECT NO. 146.38	DRAWING NO. M1302
BIOSOLIDS TREATMENT CENTER TANK SECTION VIEWS		DATE MAY 2016	SHEET NO. 65 OF 70

\\dye\dyer-part\A\Projects\146 Sutherlin\146.38 WWTF Pre-Design Report\dwg\PRE-DESIGN\PROCESS AREA 1300 SLUDGE HOLDING\SECTIONS.dwg, 11/30/2015 4:41:18 PM PLOT DATE May 5, 2016

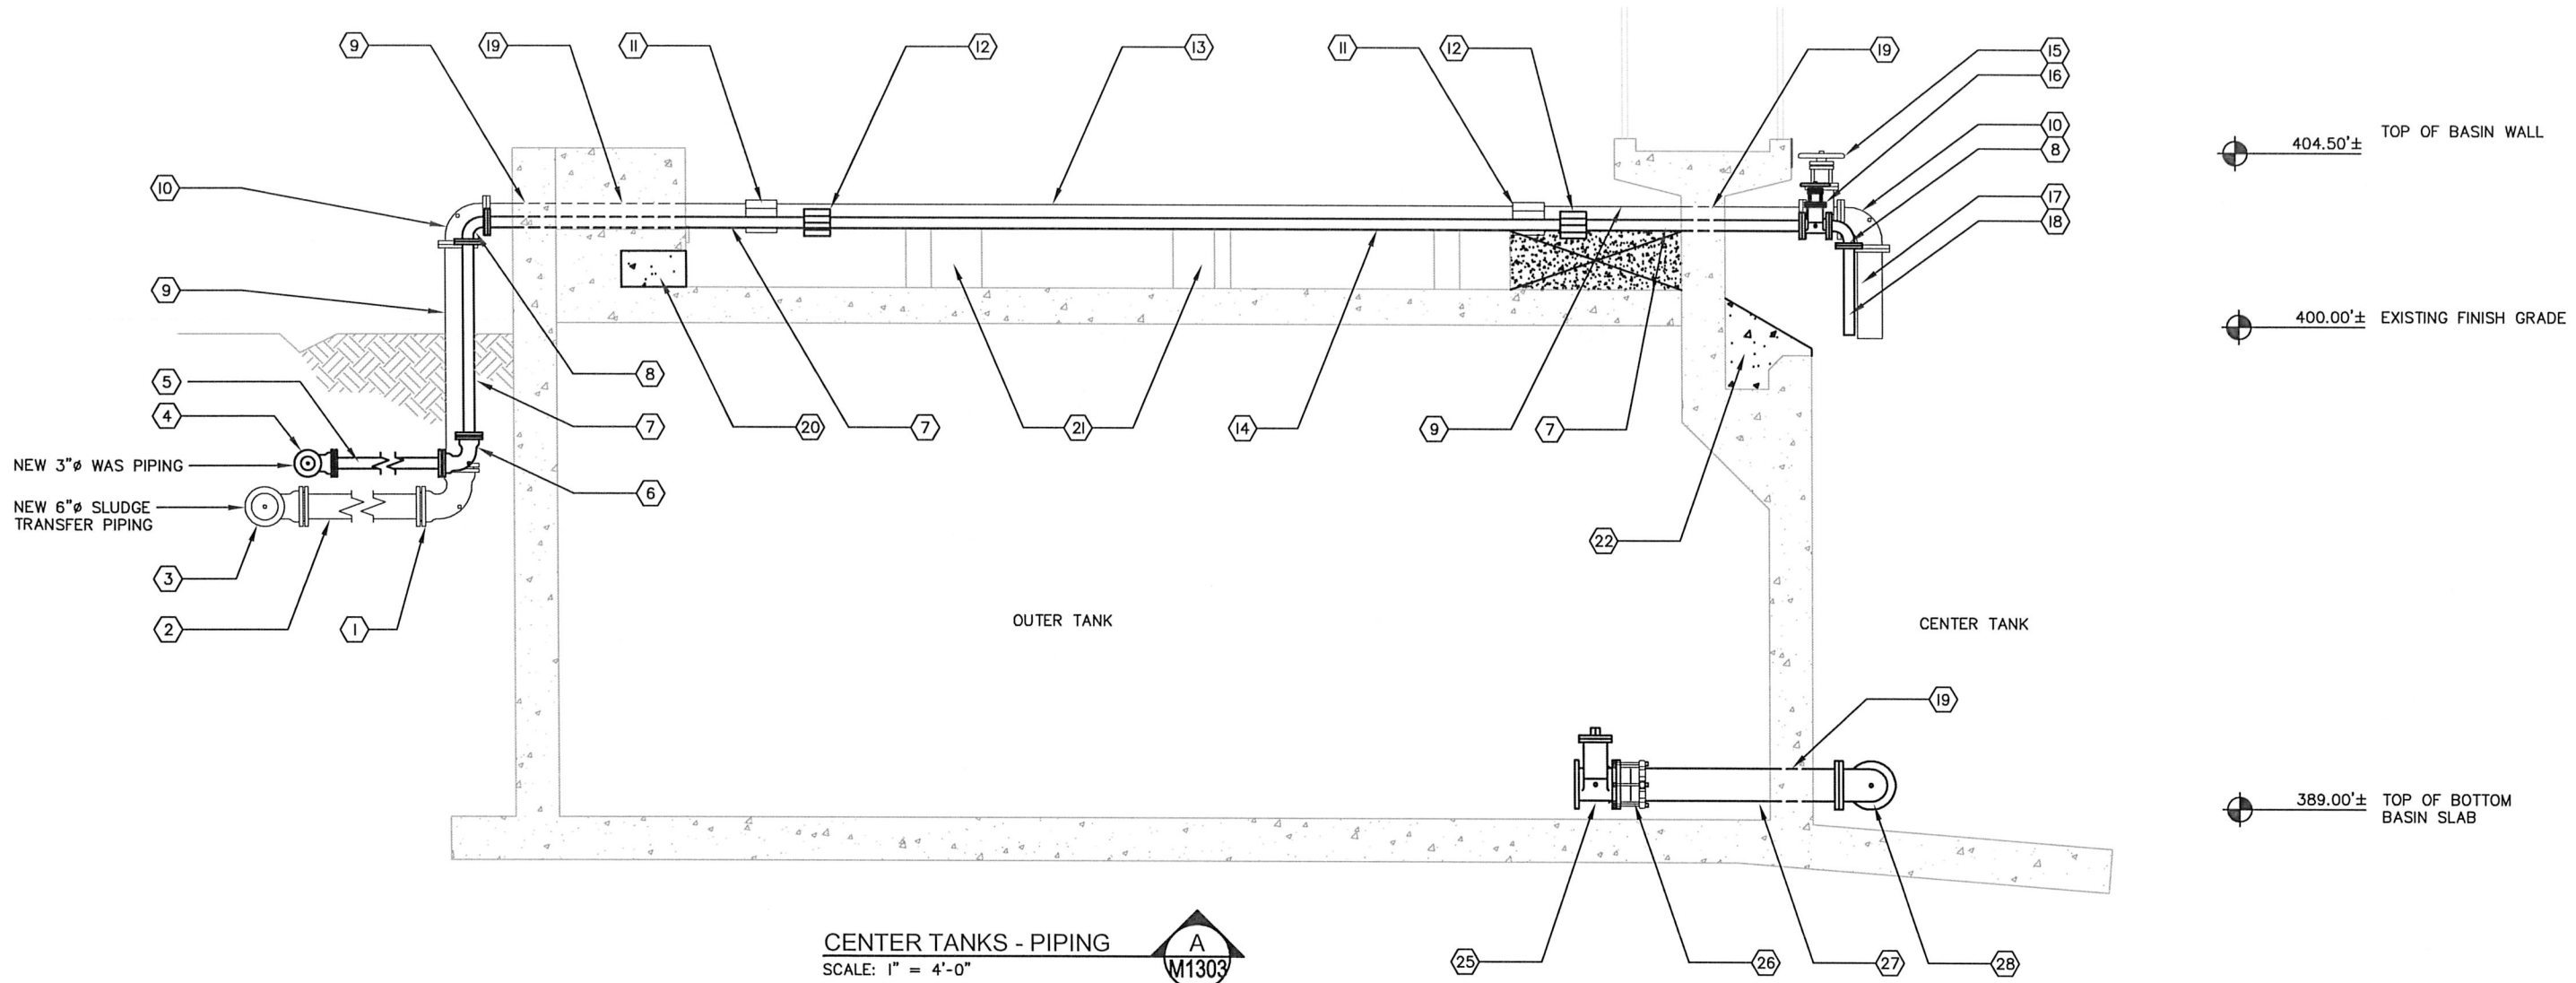

KEY NOTES

- 1 NEW 6" MJ 90° ELBOW

2 NEW 6" PIPE SPOOL, LENGTH AS REQUIRED

3 NEW 6" MJ TEE

4 NEW 3" MJ TEE

5 NEW 3" PIPE SPOOL, LENGTH AS REQUIRED

6 NEW 3" MJ 90° ELBOW

7 NEW 3" FLG X PE PIPE SPOOL, LENGTH AS REQUIRED

8 NEW 3" FLG 90° ELBOW

9 NEW 6" FLG X PE PIPE SPOOL, LENGTH AS REQUIRED

10 NEW 6" FLG 90° ELBOW
- 11 NEW 6" FCA

12 NEW 3" FCA

13 NEW 6" PIPE SPOOL, LENGTH AS REQUIRED

14 NEW 3" PIPE SPOOL, LENGTH AS REQUIRED

15 NEW 6" FLG PLUG VALVE

16 NEW 3" FLG PLUG VALVE

17 NEW 6" FLG X PE PIPE SPOOL, L = 2'-0"

18 NEW 3" FLG X PE PIPE SPOOL, L = 2'-0"

19 NEW PIPE PENETRATION, SEE DETAIL

20 PLUG EXISTING CONTACT CHAMBER OUTLET.
- 21 MODIFY EXISTING CONCRETE BAFFLES AS REQUIRED TO UTILIZES AS PIPE SUPPORTS

22 GROUT FILL EXISTING CLARIFIER TROUGH

23 REMOVE EXISTING WEIRS AND FILL BLOCKOUT WITH CONCRETE.


24 NEW PIPE SUPPORTS $\frac{X}{XX}$

25 NEW 8" PLUG VALVE

26 NEW 8" FCA

27 NEW 8" FLG X PE PIPE SPOOL, LENGTH AS REQUIRED

28 NEW 8" ELBOW OR TEE, REFER TO PLAN VIEW ON SHEET M1300

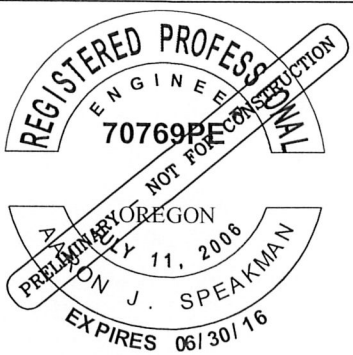

DESIGNED:	DRAWN:
---	CGP
APPROVED BY:	DATE:
---	---

REVISIONS				
REVISED	DESCRIPTION	SUBMIT.	APPR'D.	DATE



THE DYER PARTNERSHIP
ENGINEERS & PLANNERS, INC.
1330 TEAKWOOD AVENUE
COOS BAY, OREGON 97420
TELEPHONE: (541) 269-0732
www.dyerpart.com


LINE IS 1 INCH
AT FULL SCALE
IF NOT 1-INCH - SCALE ACCORDINGLY

WASTEWATER TREATMENT PLANT IMPROVEMENTS
CITY OF SUTHERLIN

BIOSOLIDS TREATMENT
CENTER TANK - SECTION VIEW

PROJECT NO.	DRAWING NO.
146.38	M1303
DATE	SHEET NO.
MAY 2016	66 OF 70

\\dye\dyer-part\A\projects\146 Sutherlin\146.38 WWTF Pre-Design Report\dwg\PRE-DESIGN\PROCESS AREA 1300 SLUDGE HOLDING\EXISTING FILTER BLDG.dwg, 11/30/2015 3:45:03 PM PLOT DATE May 5, 2016

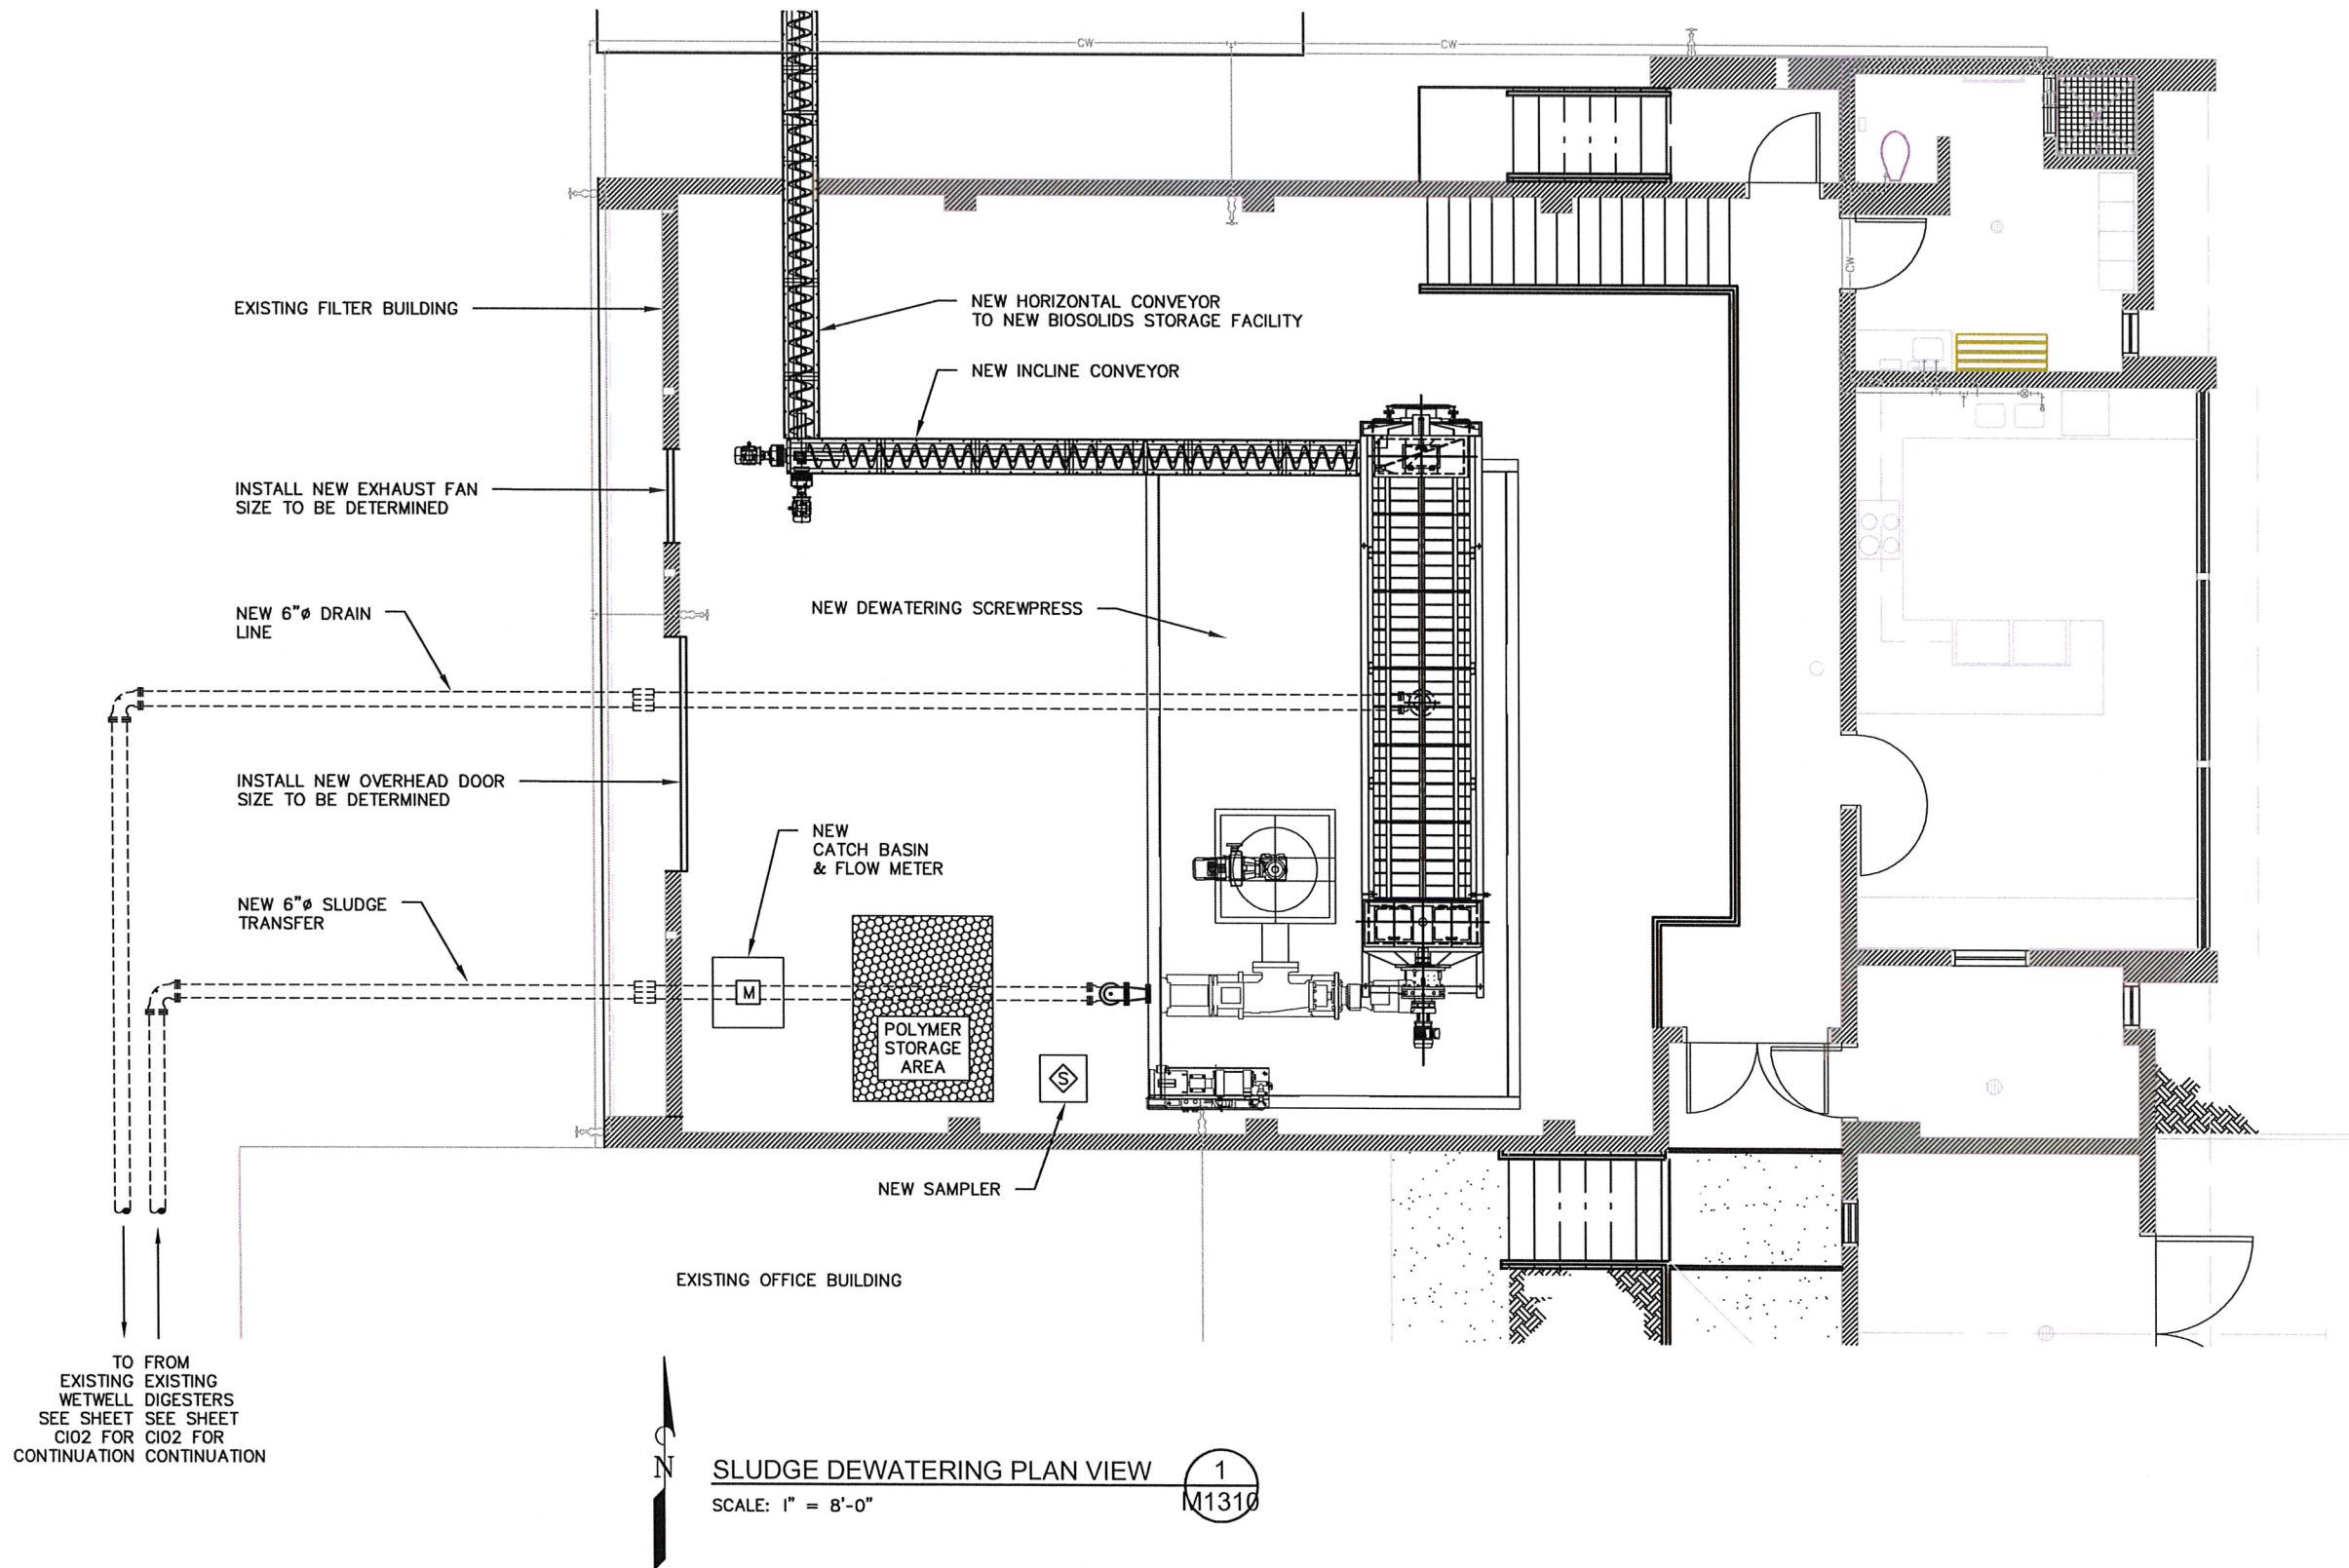

DESIGNED: _____
DRAWN: _____
APPROVED BY: _____
DATE: _____

REVISIONS				
REVISED	DESCRIPTION	SUBMIT	APPR'D	DATE

D THE DYER PARTNERSHIP
ENGINEERS & PLANNERS, INC.
1330 TEAKWOOD AVENUE
COOS BAY, OREGON 97420
TELEPHONE: (541) 269-0732
www.dyerpart.com

LINE IS 1 INCH
AT FULL SCALE
IF NOT 1-INCH - SCALE ACCORDINGLY

**WASTEWATER TREATMENT PLANT IMPROVEMENTS
CITY OF SUTHERLIN**

**BIOSOLIDS TREATMENT
SLUDGE DEWATERING - PLAN VIEW**


PROJECT NO.	DRAWING NO.
146.38	M1310
DATE	SHEET NO.
MAY 2016	67 OF 70

KEYED NOTES:

- 1 EXISTING PUMP STATION BUILDING.
- 2 EXISTING PUMPS - TO BE REMOVED UPON COMPLETION OF NEW PUMP STATION.
- 3 EXISTING WETWELL ACCESS. WETWELL TO BE SLURRY FILLED UPON COMPLETION OF NEW PUMP STATION.
- 4 EXISTING FLOW METER AND VAULT. EXISTING PIPING TO BE ABANDON IN PLACE AFTER METER RELOCATION. EXISTING VAULT TO BE REMOVED.
- 5 EXISTING GENERATOR.
- 6 EXISTING 18"Ø SANITARY SEWER LINE. ABANDON IN PLACE AFTER COMPLETION OF NEW PUMP STATION.
- 7 EXISTING GRINDER MANHOLE. RE-CHANNEL TO NEW 18" OUTLET.
- 8 EXISTING 48"Ø MANHOLE.
- 9 EXISTING 48"Ø MANHOLE.
- 10 EXISTING CHANNEL FOR 18"Ø STUB-OUT. REMOVE EXISTING CDF FILL.
- 11 EXISTING 14"Ø WATER LINE, PROTECT IN PLACE.
- 12 EXISTING CHAIN LINK FENCING TO BE REMOVED.
- 13 NEW 18"Ø GRAVITY SEWER LINE.
- 14 NEW 48"Ø MANHOLE.
- 15 NEW 10'Ø WETWELL.
- 16 NEW SUBMERSIBLE PUMPS TYPICAL OF 3, SEE M1400 & M1401.
- 17 NEW EFFLUENT PIPING AND VALVE VAULT, SEE M1400 & M1401.
- 18 NEW 12"Ø DUCTILE IRON EFFLUENT FORCE MAIN.
- 19 RELOCATE EXISTING 10"Ø FLOW METER TO NEW VAULT.
- 20 CONNECT NEW 12"Ø FORCE MAIN TO EXISTING 10"Ø FORCE MAIN IN ALLEY.
- 21 EXISTING POWER POLE, PROTECT IN PLACE.
- 22 NEW POWER CONDUIT FROM POWER POLE TO NEW CONTROL PANEL.
- 23 NEW CHAIN LINK FENCING TO ENCLOSE NEW PUMP STATION AS SHOWN.

NOTES:

1. FACILITIES LOCATED OUTSIDE 100YR FLOOD PLAIN.
2. EXISTING PHONE LINE WILL NOT BE LOCATED BY UTILITY COMPANY

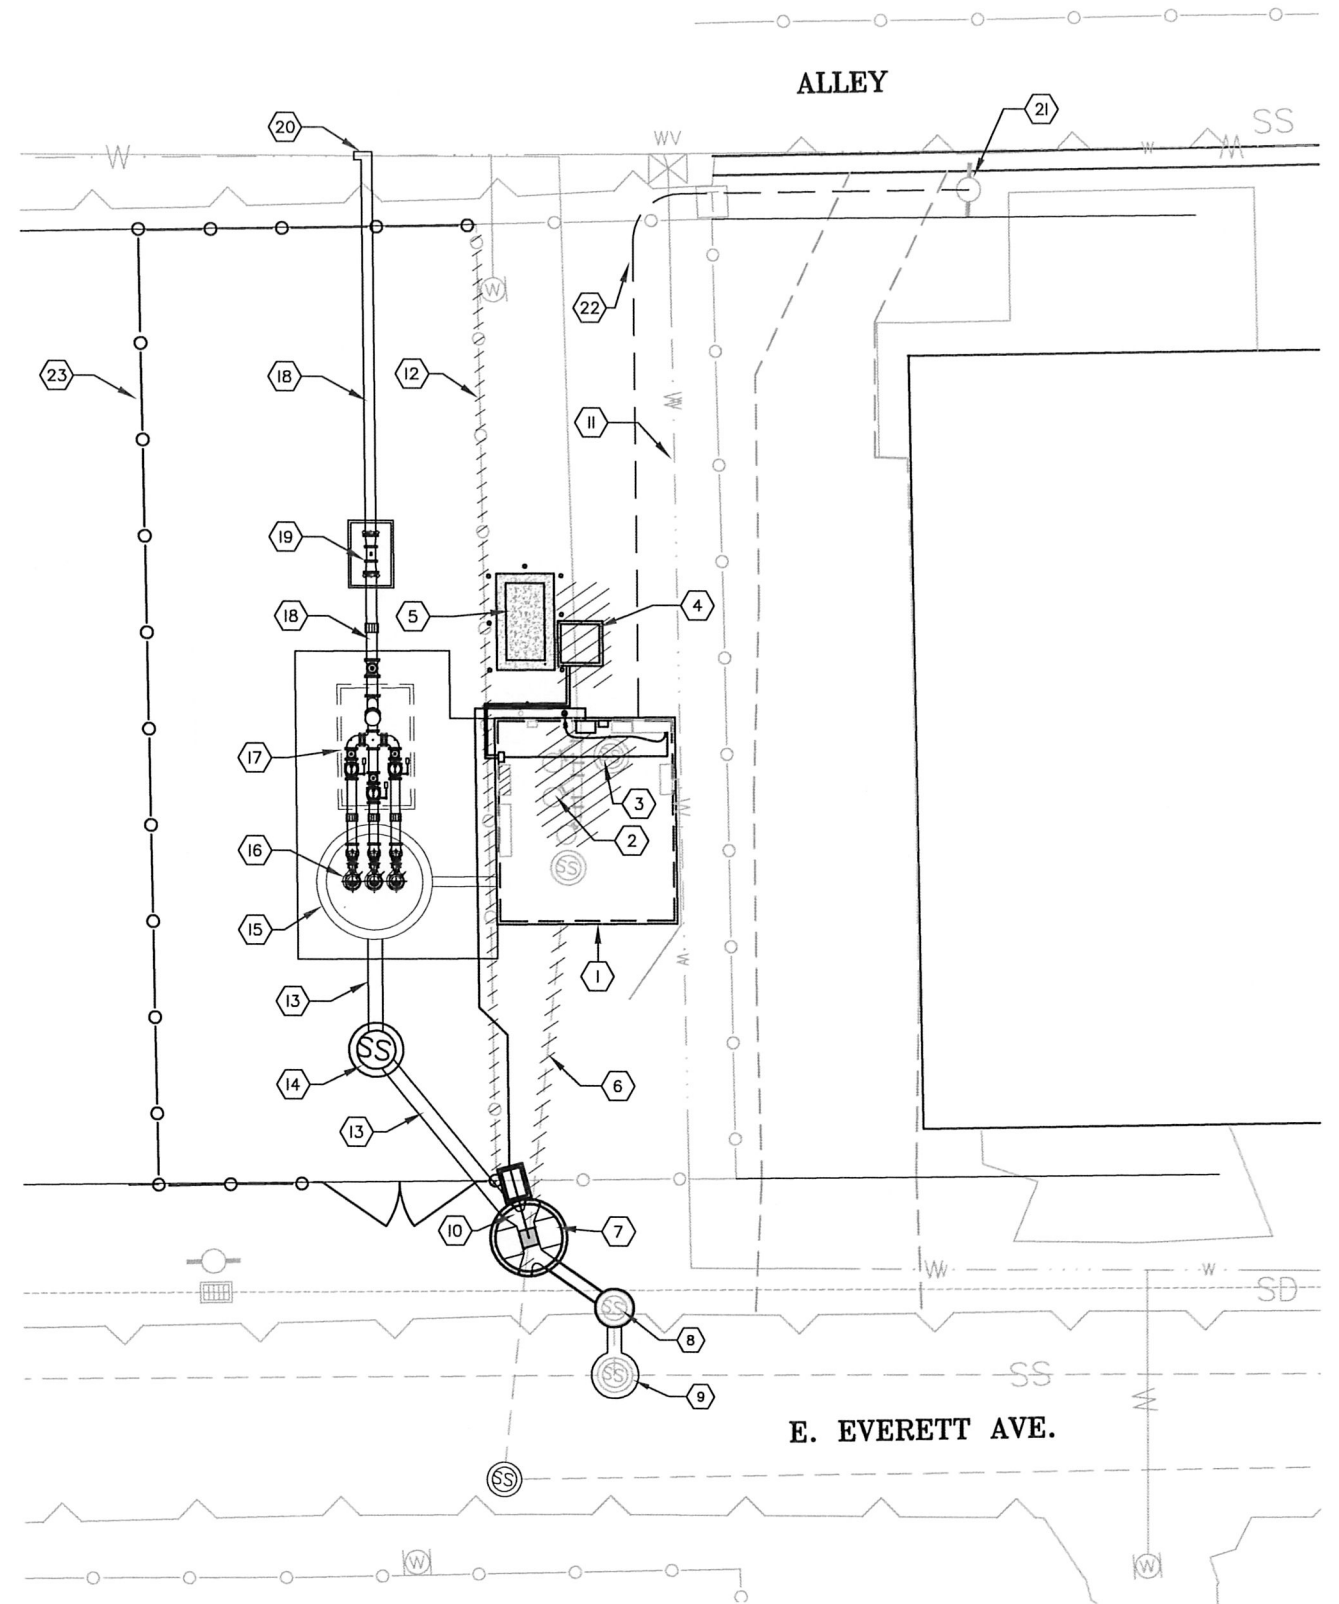

EVERETT AVE. PUMP STATION PLAN VIEW

SCALE : 1" = 20'
NOTE: NOT ALL PIPING SHOWN FOR CLARITY

1
D1400



DESIGNED: SBM	DRAWN: DLS	REVISIONS			
APPROVED BY:		REVISED	DESCRIPTION	SUBMIT.	APPR'D. DATE
DATE:					

D THE DYER PARTNERSHIP
ENGINEERS & PLANNERS, INC.
1330 TEAKWOOD AVENUE
COOS BAY, OREGON 97420
TELEPHONE: (541) 269-0732
www.dyerpart.com


LINE IS 1 INCH
AT FULL SCALE
IF NOT 1-INCH - SCALE ACCORDINGLY

WASTEWATER TREATMENT PLANT IMPROVEMENTS
CITY OF SUTHERLIN


EVERETT AVE. PUMP STATION
DEMOLITION- PLAN VIEW

PROJECT NO. 146.38	DRAWING NO. D1400
DATE MAY 2016	SHEET NO. 68 OF 70

\\dyer\dyer-part\AA\projects\146 Sutherlin\146.38 WWTF Pre-Design Report\dwg\PRE-DESIGN\PROCESS AREA 1400 EVERETT AVE PS\M1400.dwg, 3/22/2016 9:23:03 AM May 5, 2016 PLOT DATE

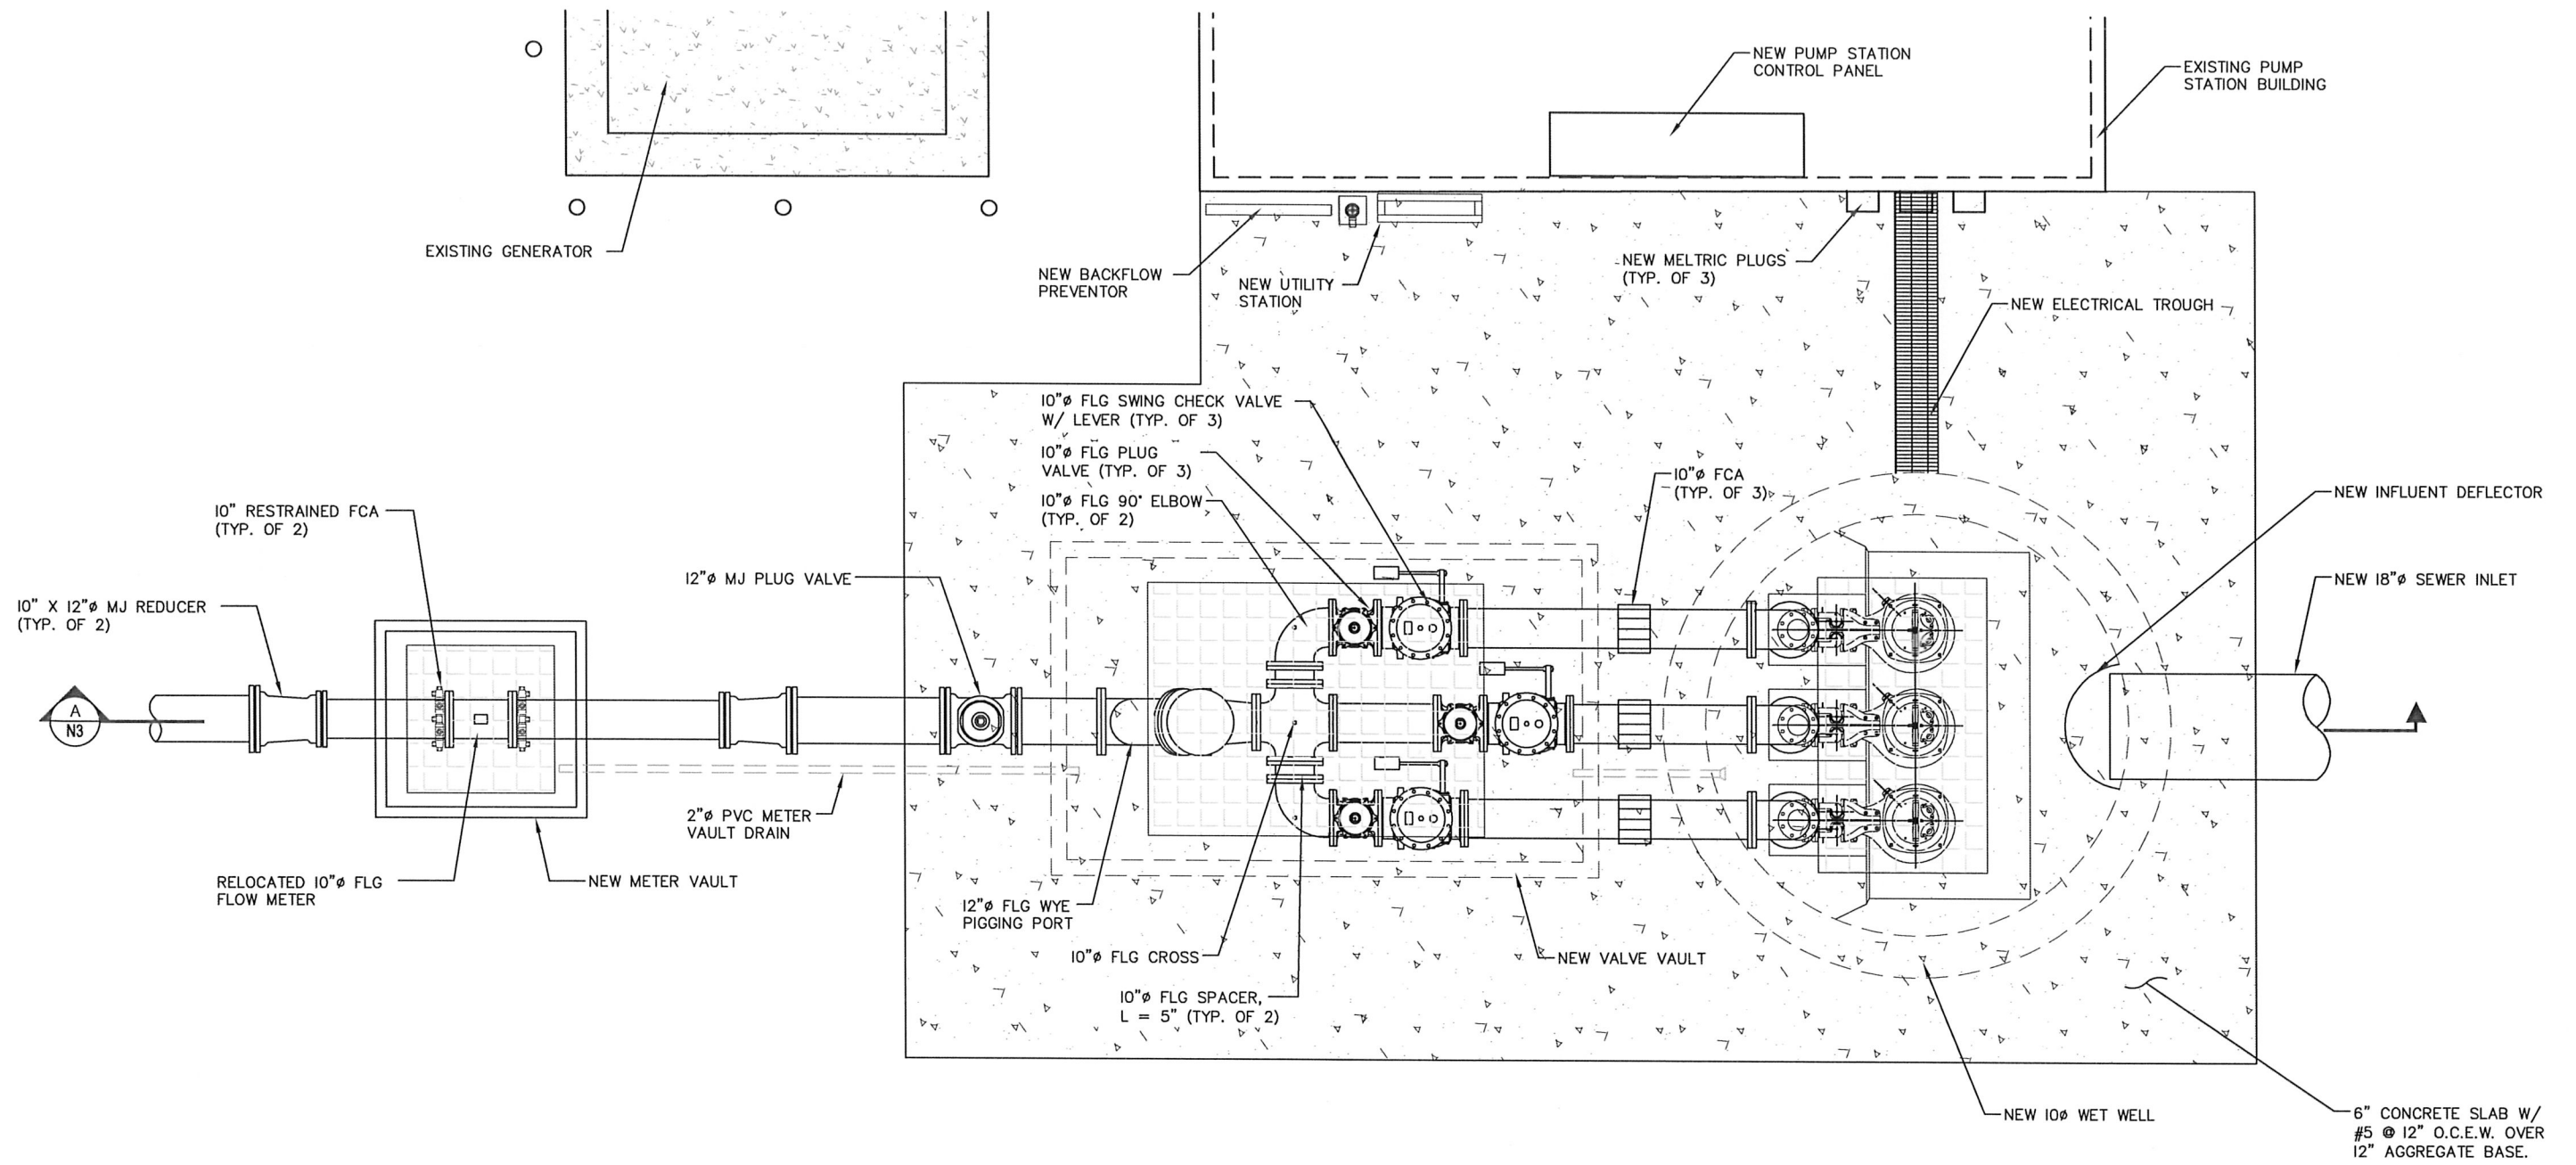

PLAN VIEW- EVERETT AVENUE PUMP STATION
SCALE : 1" = 4'-0"

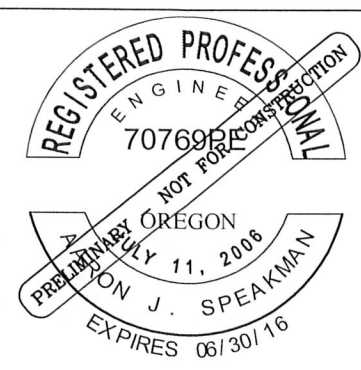


DESIGNED: SBM	DRAWN: DLS	REVISIONS			
APPROVED BY:		REVISED	DESCRIPTION	SUBMIT.	APPR'D. DATE
DATE:					

D

THE DYER PARTNERSHIP
ENGINEERS & PLANNERS, INC.
1330 TEAKWOOD AVENUE
COOS BAY, OREGON 97420
TELEPHONE: (541) 269-0732
www.dyerpart.com

LINE IS 1 INCH
AT FULL SCALE
IF NOT 1-INCH - SCALE ACCORDINGLY

WASTEWATER TREATMENT PLANT IMPROVEMENTS CITY OF SUTHERLIN		PROJECT NO. 146.38	DRAWING NO. M1400
EVERETT AVE. PUMP STATION MECHANICAL- PLAN VIEW		DATE MAY 2016	SHEET NO. 69 OF 70

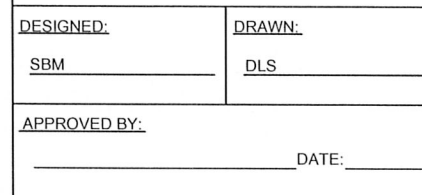[illegible]

LINE IS 1 INCH
AT FULL SCALE

IF NOT 1-INCH - SCALE ACCORDINGLY

PROJECT NO. 146.38	DRAWING NO. M1401
DATE MAY 2016	SHEET NO. 70 OF 70